
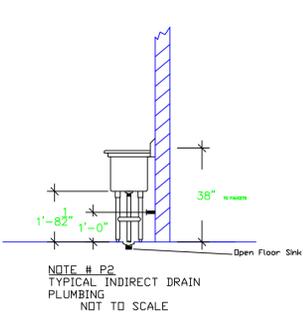
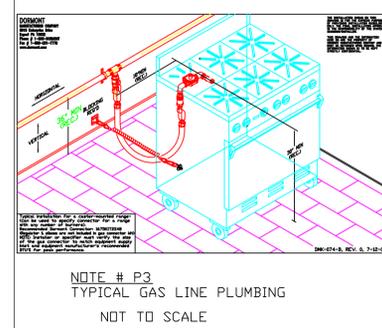
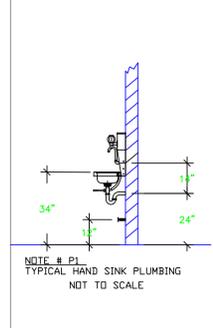


PLUMBING SCHEDULE												
ITEM NO.	DESCRIPTION	COLD WATER SIZE	HOT WATER SIZE	H&C Rough-In	DIRECT WASTE	INDIRECT WASTE	INDIRECT WASTE AFF.	INDIRECT WASTE SIZE	GAS SIZE(IN)	GAS METU	QTY	PLUMBING REMARKS
3	Soda Ice & Beverage Dispenser	3/8"		12"				3/4"			1	Owner to Verify Existing Equipment
4	Floor Trough				4"	0"					1	Floor Trough, Installed by Plumber
11	Rear Serving Counter							1-1/2"			1	Waste to Floor Sink
11.3	Hot Food Wall Unit, Drop-In, Electric	1/4"		Floor				1"			1	Waste to Floor Sink
11.4	Deck Mount Faucet	1/2"	1/2"	Floor							1	Waste to Floor Sink
31	Gas Floor Fryer								1/2"	120.0	3	
33	Hotplate, Countertop, Gas								3/4"	198.0	1	
34	Kettle, Gas, Tilling	3/8"	3/8"	12"					3/4"	43.0	1	See Note P3
35	Floor Trough				4"	0"					1	Floor Trough, Installed by Plumber
36	Combi Oven, Electric	3/4"		n/a				1-1/2"			1	Incoming Water from Filter 36.1
36.1	Water Filtration System, for Steam Equipment	3/8"		12"							1	
41	Work Table, Stainless Steel Top										1	
41.1	Sink							1-1/2"			1	Waste to Floor Sink
41.1	Deck Mount Faucet	1/2"	1/2"	12"							1	
45	Hand Sink	1/2"	1/2"		1-1/2"	24"					1	(1) set of 1" faucet holes, 4" OC, splash mount
46	Three (3) Compartment Sink							(3) 1-1/2"			1	(1) set of 1/2" faucet holes, 8" OC
46.1	Wall / Splash Mount Faucet	1/2"	1/2"	12"							1	
48	Mop Sink Cabinet				2"	0"					1	Mop Sink, Installed by Plumber
48.1	Service Faucet	1/2"	1/2"	36"							1	
51	Enclosed Hose Reel	1/2"	1/2"	36"							1	
52	Ice Cuber	1/2"		n/a				3/4"			1	Incoming water from Filter 52.2
52	Ice Bin							3/4"			1	
52.2	Water Filtration System, for Ice Machines	3/4"		12"							1	
53	Floor Trough				4"	0"					1	Floor Trough, Installed by Plumber
61.1	Evaporator							1"			1	Condensate to floor drain
61.3	Evaporator							1"			1	Condensate to floor drain
2100	Floor Sink				4"	Floor					3	Floor Sink, Installed by Plumber

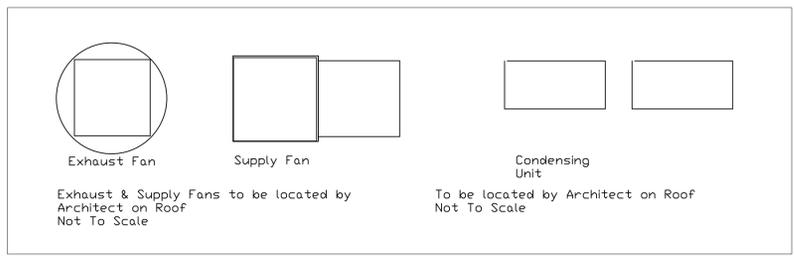

- LEGEND - PLUMBING CONNECTIONS**
- HW-HOT WATER, OR CW-COLD WATER
 - GAS
 - WASTE, DIRECT-CONNECTED
 - WASTE, INDIRECT TO Floor Sink
 - FLOOR DRAIN Josam 30000-A3
 - FUNNEL FLOOR DRAIN Josam 30000-E3
 - FLOOR SINK Zurn FD-2370-Y-PV4-F

NOTE # P4: ALL NATIONAL, STATE, AND LOCAL CODES SHALL APPLY

NOTE # P5: ALL PLUMBING CONNECTIONS TO BE EXTENDED AND INTERCONNECTED TO EQUIPMENT AND ALL HARDWARE REQUIRED TO BE PROVIDED BY PLUMBING CONTRACTOR

NOTE # P6: PLUMBING CONTRACTOR TO VERIFY THAT ALL EQUIPMENT IS INSTALLED WITH THE APPROPRIATE GAS PRESSURE AND REGULATORS

NOTE # P7: ALL WASTE LINES AND CONDENSATE LINES TO BE EXTEND FROM EQUIPMENT TO FLOOR DRAINS BY PLUMBING CONTRACTOR.

Equipment PLUMBING Service Requirements

All Dimensions to be verified on the job site. Actual locations for floor drains, and any ventilating equipment to be determined by Engineer. Mechanical, Plumbing & Electrical to be checked and verified by Customers MEP Engineer. Remote Condensing Units to be located by Architect. Exhaust & Supply fans to be located by Architect.

**Fish Pot - 4
Kitchen**
Portmore, Jamaica



2055 W 73rd Street, Miami, FL 33016
Ph:(305)826-8696 Fax:(305)826-9131

No.	Revision/Issue	Date
6	Updated From Owner Comments.	11-15-18
7	Updated From Owner Comments.	11-19-18
8	Added MEP Sheets	11-28-18
9	Updated Background	1-31-19

Date
Jan 31, 2019
Drawn By
Dayne Gauntlett
Scale
3/8" = 1'0"

Sheet
MK-4