


EQUIPMENT SCHEDULE					
ItemNo	Category	Mfr	Model	Quantity	Equipment Remarks
1	Work Counters, Millwork	Millwork	COUNTER	1	By Owner/Operator
2	POS Terminals	POS	POS	3	By Owner/Operator
3	Soda Ice & Beverage Dispenser	Servend	2706264	1	By Owner/Operator
4	Floor Trough	Emjac	FFTG-1236	1	
11	Rear Serving Counter	Emjac	COUNTER	1	
11.1	Overshelf	Emjac	OVERSHELF	1	
11.2	Hot Food Well Unit, Drop-In, Electric	Wells	SS-10TUI	2	
11.3	Hot Food Well Unit, Drop-In, Electric	Wells	MOD-400TDM/AF	1	
11.4	Deck Mount Faucet	Krowne	15-310L	1	
12	French Fry Warmer	Hatco	GRFHS-PT26	1	
13	Refrigerated Merchandiser	True	GDM-19T-HC-TSL01	1	By Owner/Operator
14	Display Case, Hot Food, Countertop	Vollrath	40733	1	
21	Sandwich / Salad Preparation Refrigerator	True	TSSU-60-12-HC	1	Existing
22	Microwave Oven	ACP	RCS10TS	1	Existing
22.1	Microwave Oven, Shelf	Advance Tabco	MS-18-24	1	Existing
23	Mobile Heated Cabinet	Alto-Shaam	1000-UP	1	Existing
26	Chef Table	Emjac	CHEF TABLE	1	
27	Undercounter Refrigerator	True	TUC-60-32	1	
28	Reach-In Undercounter Freezer	True	TUC-48F-HC	1	
29	Warming Drawer, Built-In	Wells	RW-26HD	1	
31	Gas Floor Fryer	Henny Penny	OFG341.0	3	Existing
32	Fryer Dump Station	Henny Penny	FDS100.01	1	Existing
33	Hotplate, Countertop, Gas	Southbend	HDO-36	1	
34	Kettle, Gas, Tilling	Market Forge	FT-12CG	1	
35	Floor Trough	Emjac	FFTG-1824	1	
36	Combi Oven, Electric	RATIONAL	B608106.19	1	By Owner/Operator
36.1	Water Filtration System, for Steam Equipment	Everpure	EV979750	1	
37	Rice / Grain Cooker	Hamilton Beach	37590	2	
37.1	Work Table, Stainless Steel Top	Emjac	KMS-423	1	
38	Main Hood	Captive-Aire	HOOD - MAIN	1	Existing
38.1	Exhaust Fan	Captive-Aire	E FAN - MAIN	1	Existing
38.2	Supply Fan	Captive-Aire	S FAN - MAIN	1	Existing
41	Work Table, Stainless Steel Top	Emjac	KMS-3010.5	1	
	Sink	Emjac	TA-11J	1	
41.1	Deck Mount Faucet	Krowne	15-310L	1	
41.2	Shelving, Wall Mounted	Emjac	WS-12-48	4	
42	Undercounter Refrigerator	True	TUC-27-LP-HC	1	
45	Hand Sink	Advance Tabco	7-PS-60	1	Existing
46	Three (3) Compartment Sink	Advance Tabco	FC-3-1818	1	Existing
46.1	Wall / Splash Mount Faucet	Krowne	14-814L	1	
46.2	Drain, Lever / Twist Waste	Krowne	22-204	3	Not in Drawing
47	Pot Rack	Emjac	SW-60	1	
48	Mop Sink Cabinet	Emjac	9-OPC-84DL	1	
48.1	Service Faucet	Krowne	16-127	1	
49	Wire Shelving	NEXEL	S1448N	4	
51	Enclosed Hose Reel	T&S Brass	B-1433	1	
52	Ice Cuber	Hoshizaki	KM-650MAH-E	1	Existing
	Ice Bin	Hoshizaki	B-300PF	1	Existing
52.2	Water Filtration System, for Ice Machines	Everpure	EV932421	1	
53	Floor Trough	Emjac	FFTG-1230	1	
61	Walk-In Combo	Arctic Industries	WALK-IN	1	By Owner/Operator
61.1	Evaporator	Arctic Industries	EVAP	1	By Owner/Operator
61.2	Condensing Unit	Arctic Industries	COND	1	By Owner/Operator
61.3	Evaporator	Arctic Industries	EVAP	1	By Owner/Operator
61.4	Condensing Unit	Arctic Industries	COND	1	By Owner/Operator
64	Wire Shelving Unit	NEXEL	18606N	1	
71	Desk & Chair	Owner	DESK	1	By Owner/Operator
73	Locker	NEXEL	PT123KD	3	
74	Wire Shelving Unit	NEXEL	18606N	1	

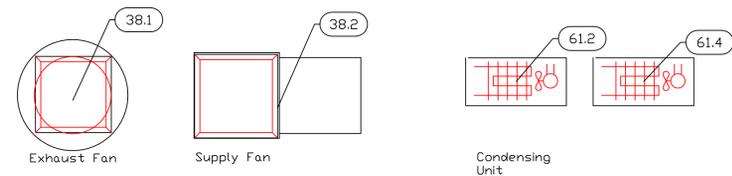

Exhaust & Supply Fans to be located by Architect on Roof Not To Scale

Condensing Unit To be located by Architect on Roof Not To Scale

# EQUIPMENT LAYOUT

All Dimensions to be verified on the job site. Actual locations for floor drains, and any ventilating equipment to be determined by Engineer. Mechanical, Plumbing & Electrical to be checked and verified by Customers MEP Engineer. Remote Condensing Units to be located by Architect. Exhaust & Supply fans to be located by Architect.

**Fish Pot - 4**  
**Kitchen**  
Portmore, Jamaica




2055 W 73rd Street, Miami, FL 33016  
Ph: (305)826-8696 Fax: (305)826-9131

No.	Revision/Issue	Date
6	Updated From Owner Comments.	11-15-18
7	Updated From Owner Comments.	11-19-18
8	Added MEP Sheets	11-28-18
9	Updated Background	1-31-19

Date  
**Jan 31, 2019**  
Drawn By  
**Dayne Gauntlett**  
Scale  
**3/8" = 1'0"**


Sheet  
**MK-1**

### Hood By Owner

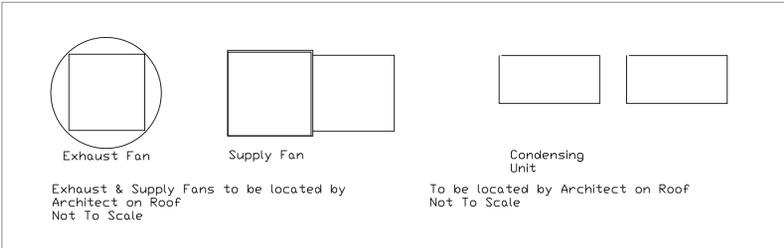

**LEGEND – MECHANICAL**

- EXHAUST DUCT COLLAR
- SUPPLY DUCT COLLAR
- INWALL BACKING FOR WALL SHELVES
- RECESSED FLOOR
- RAISED EQUIPMENT PAD

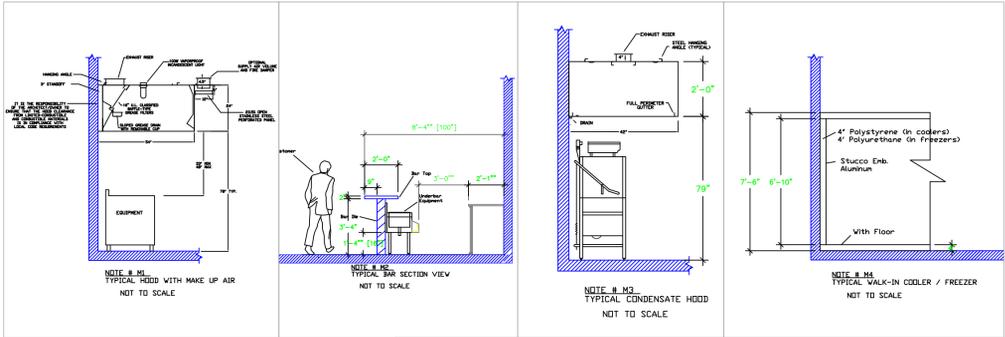

**NOTE # M5**  
SHOP DRAWING WILL BE PROVIDED BY MANUFACTURER FOR HOOD, EXHAUST FANS, & SUPPLY FANS, UNCE ORDER IS PLACE WITH.

**NOTE # M6**  
ARCHITECT OR ENGINEER TO SIZE AND LOCATE, CONTRACTOR TO PROVIDE ALL OPENINGS FOR DUCTS, PLUMBING LINES, ELECTRICAL LINES, AND REFRIGERATION LINES, AS REQUIRED BY EQUIPMENT.

**NOTE # M7**  
SUPPLY FANS TO BE LOCATED A MINIMUM OF 10' FROM EXHAUST FANS.

**NOTE # M8**  
CEILING HEIGHTS TO BE VERIFIED FOR SUFFICIENT CLARENCE FOR EQUIPMENT.

**NOTE # M9**  
GENERAL CONTRACTOR TO PROVIDE 2" PLYWOOD WALL BACKING FROM 48" TO 78" AFF FOR ALL WALL MOUNTED EQUIPMENT.

**NOTE # M10**  
CEILING HEIGHTS TO BE VERIFIED FOR SUFFICIENT CLARENCE FOR EQUIPMENT.

**NOTE # M11**  
REFRIGERATION CONTRACTOR TO HANG EVAPORATORS FOR WALK-IN, RUN & CHARGE LINES BETWEEN EVAP. & CONDENSING UNIT.

## Equipment MECHANICAL Service Requirements

All Dimensions to be verified on the job site. Actual locations for floor drains, and any ventilating equipment to be determined by Engineer. Mechanical, Plumbing & Electrical to be checked and verified by Customers MEP Engineer. Exhaust & Supply Units to be located by Architect.

6	Updated From Owner Comments.	11-15-18
7	Updated From Owner Comments.	11-19-18
8	Added MEP Sheets	11-28-18
9	Updated Background	1-31-19
No.	Revision/Issue	Date

Date  
**Jan 31, 2019**

Drawn By  
**Dayne Gauntlett**


Scale  
**3/8" = 1'0"**

Sheet  
**MK-2**


**Fish Pot - 4**  
**Kitchen**  
Portmore, Jamaica

**uni-source**  
SUPPLY  
INTERNATIONAL INC.


2055 W 73rd Street, Miami, FL 33016  
Ph:(305)826-8696 Fax:(305)826-9131

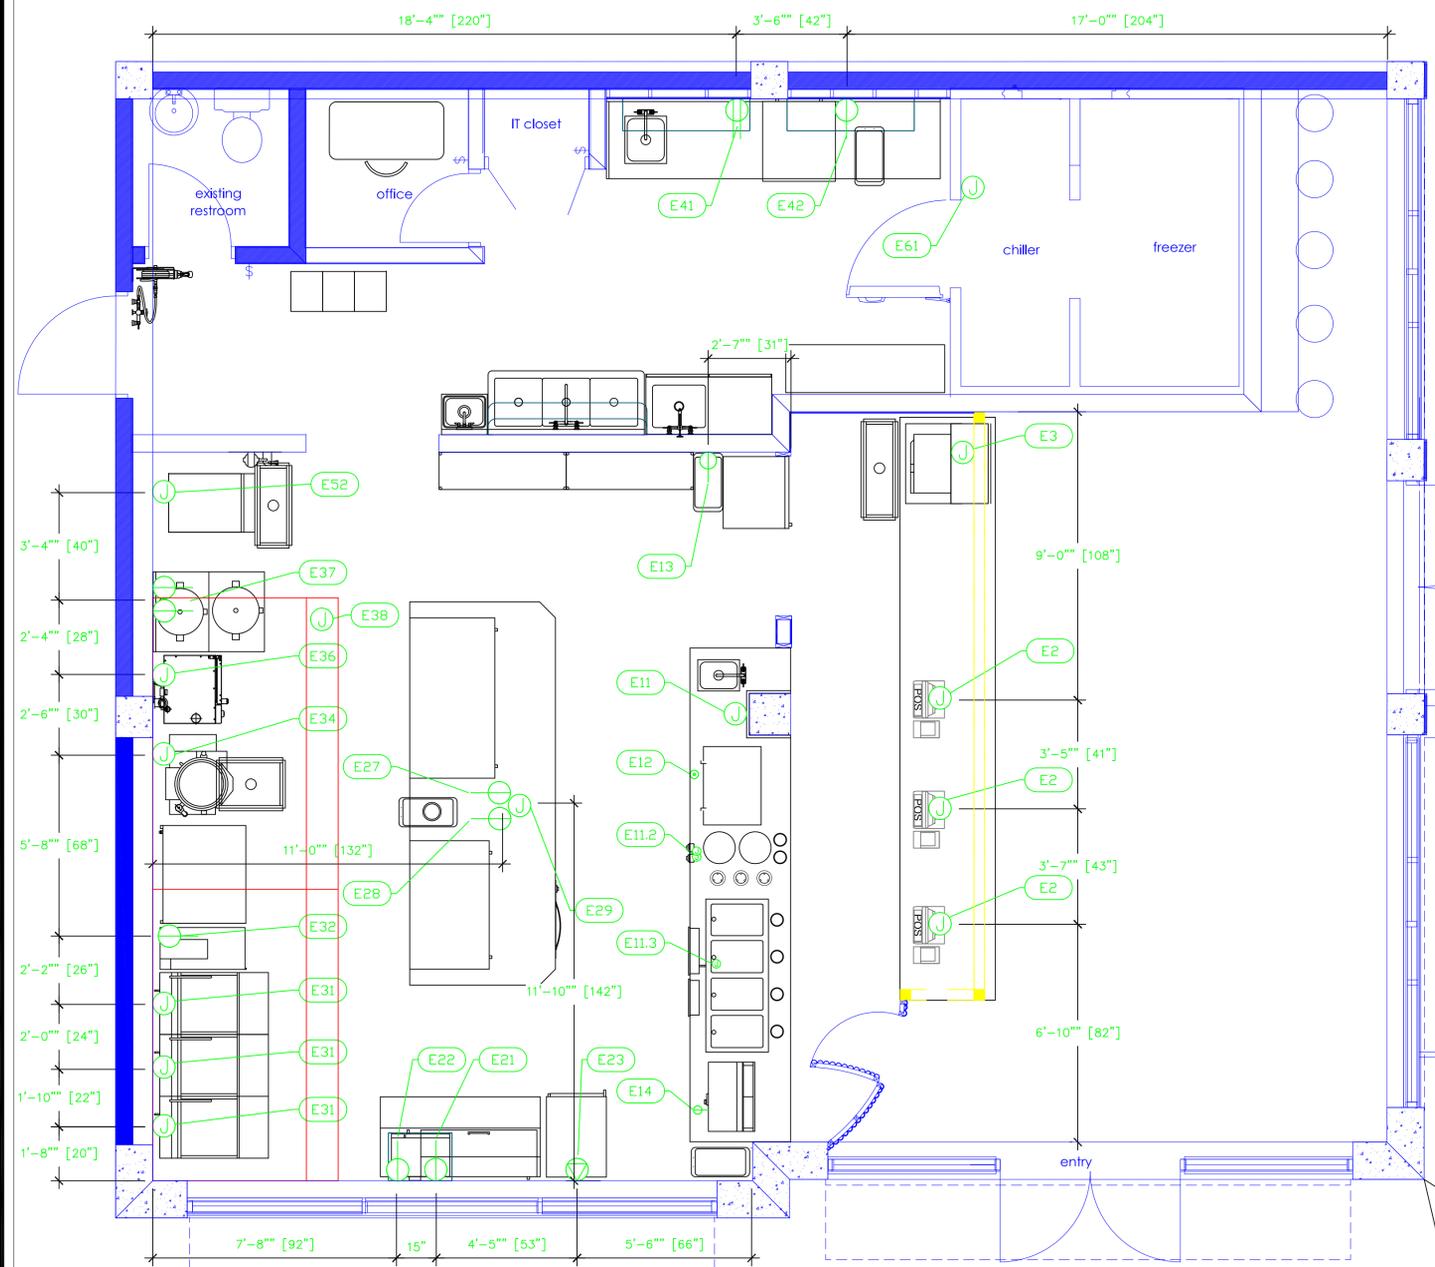

ItemNo	Category	Voltage	Cycle	Phase	Amps	Hp	ConnectionType	Rough-In AFF	Quantity	Electrical Remarks
2	POS Terminals	220	50	1	tbd		J-Box	Floor	3	By Owner, Confirm Electrical
3	Soda Ice & Beverage Dispenser	220	50	1	tbd		J-Box	Floor	1	By Owner, Confirm Electrical
11	Rear Serving Counter	120/208	50-60	1	Verify		J-Box	Floor	1	Main Incoming for Elec Panel
11.2	Hot Food Wait Unit, Drop-In, Electric	208-240	50-60	1	3.0		J-Box	n/a	2	Elec. Supply from #11 Elec. Panel
11.3	Hot Food Wait Unit, Drop-In, Electric	208/240	50-60	3	15.8		J-Box	n/a	1	Elec. Supply from #11 Elec. Panel
12	French Fry Warmer	230	50	1	5.9		Floor	n/a	1	Elec. Supply from #11 Elec. Panel
13	Refrigerated Merchandiser	230-240	50	1	2.4	1/3	Simplex	n/a	1	Elec. Supply from #11 Elec. Panel
14	Display Case, Hot Food, Countertop	120	50-60	1	12.0		Simplex	n/a	1	Elec. Supply from #11 Elec. Panel
21	Sandwich / Salad Preparation Refrigerator	230-240	50	1	6.5	1/3	Simplex	18"	1	By Owner, Confirm Electrical
22	Microwave Oven	230-240	50	1	13		Simplex	72"	1	By Owner, Confirm Electrical
23	Mobile Heated Cabinet	230	50-60	1	7.7		Special	18"	1	By Owner, Confirm Electrical
27	Undercounter Refrigerator	230	50-60	1	3.5	1/5	Simplex	Floor	1	Stub up from Floor
28	Reach-In Undercounter Freezer	230	50-60	1	2.1	1/2	Simplex	Floor	1	Stub up from Floor
29	Warming Drawer, Built-In	208-240	50-60	1	3.3-3.8		J-Box	Floor	1	Stub up from Floor
31	Gas Floor Fryer	230	50	1	6.2		J-Box	18"	3	
32	Fryer Dump Station	230	50-60	1	3.0		Simplex	18"	1	By Owner, Confirm Electrical
34	Kettle, Gas, Tilting	230	50	1	1.0		J-Box	18"	1	
36	Combi Oven, Electric	220	50/60	1	28.0		J-Box	18"	1	Confirm Elec with Ownership
37	Rice / Grain Cooker	240	60	1	10.4		Simplex	48"	2	
38	Main Hood	115	50-60	1	tbd		J-Box	108"	1	Elec for Lights in Hood By Owner, Confirm Electrical
38.1	Exhaust Fan	208	50	3	tbd		J-Box	108"	1	By Owner, Confirm Electrical
38.2	Supply Fan	208	50	3	tbd		J-Box	108"	1	By Owner, Confirm Electrical
41	Work Table, Stainless Steel Top	115/230	50	1	15		Duplex	48"	1	Convenience Outlet, Confirm Elec w/ Owner
42	Undercounter Refrigerator	230-240	50	1	1.8	1/6	Simplex	18"	1	
52	Ice Cuber	220-240	50	1	6.8		J-Box	72"	1	By Owner, Confirm Electrical
61	Walk-In Combo	115	50	1	15		J-Box	ceiling	1	By Owner, Confirm Electrical
61.1	Evaporator	220	50	1	10		J-Box	ceiling	1	By Owner, Confirm Electrical
61.2	Condensing Unit	220	50	1	32		J-Box	18"	1	By Owner, Confirm Electrical
61.3	Evaporator	220	50	1	10		J-Box	ceiling	1	By Owner, Confirm Electrical
61.4	Condensing Unit	220	50	1	32		J-Box	18"	1	By Owner, Confirm Electrical

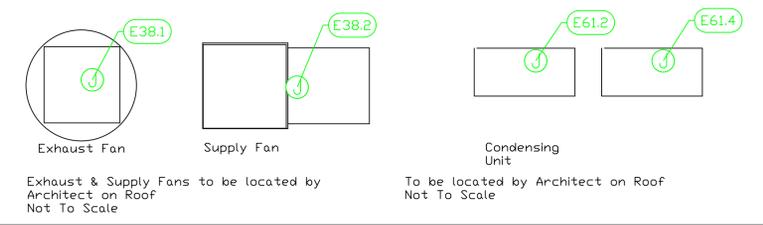

- LEGEND - ELECTRICAL CONNECTIONS**
- DUPLEX RECEPT., 15-AMP, 120-VOLT, GROUND TYPE, HORIZONTAL MOUNT
  - SIMPLEX RECEPT., 120-VOLT, GROUND TYPE, HORIZONTAL MOUNT
  - SPECIAL PURPOSE OUTLET, GROUND TYPE, HORIZONTAL MOUNT
  - JUNCTION BOX, DIRECT CONNECTION
  - DISCONNECT SWITCH, DIRECT CONNECTION
  - FLOOR/CEILING RECEPTACLE AS INDICATED
  - (2) Telephone + (2) Data
  - FIELD CONNECTIONS
  - HARD WIRE CONNECTION POINT AT MACHINE

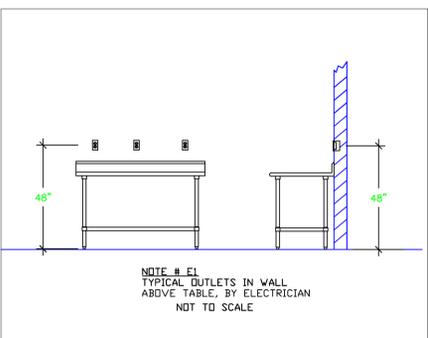

**NOTE # E2**  
ALL NATIONAL, STATE, AND LOCAL CODES SHALL APPLY

**NOTE # E3**  
ALL ELECTRICAL CONNECTIONS AND HARDWARE REQUIRED TO BE PROVIDED BY ELECTRICAL CONTRACTOR

**NOTE # E4**  
ALL JUNCTION BOXES, OUTLETS, ETC. TO BE LOCATED SO AS TO NOT INTERFERE WITH EQUIPMENT

**NOTE # E5**  
ALL RELAYS, CONTRACTORS, STARTERS, AND SWITCHES REQUIRED FOR EXHAUST & SUPPLY FANS TO BE PROVIDED BY ELECTRICAL CONTRACTOR UNLESS SPECIFIED

**NOTE # E6**  
ELECTRICAL CONTRACTOR TO INTERCONNECT DISHMACHINE TO EXHAUST FAN FOR DISHMACHINE SO THAT THE FAN RUNS WHEN THE DISHMACHINE IS IN OPERATION.

**NOTE # E7**  
ELECTRICAL CONTRACTOR TO INSTALL TABLE LIMIT SWITCH TO END OF CLEAN DISHTABLE TO THAT MACHINE STOPS WHEN SWITCH IS DEPRESSED.

**NOTE # E8**  
ELECTRICAL CONTRACTOR TO CONNECT DRAIN LINE HEATER, PAN HEATER AND DODR HEATER FOR WALK-IN FREEZER.

## Equipment ELECTRICAL Service Requirements

All Dimensions to be verified on the job site. Actual locations for floor drains, and any ventilating equipment to be determined by Engineer. Mechanical, Plumbing & Electrical to be checked and verified by Customers MEP Engineer. Remote Condensing Units to be located by Architect. Exhaust & Supply fans to be located by Architect.

**Fish Pot - 4**  
**Kitchen**  
Portmore, Jamaica




2055 W 73rd Street, Miami, FL 33016  
Ph:(305)826-8696 Fax:(305)826-9131





No.	Revision/Issue	Date
6	Updated From Owner Comments.	11-15-18
7	Updated From Owner Comments.	11-19-18
8	Added MEP Sheets	11-28-18
9	Updated Background	1-31-19

Date  
**Jan 31, 2019**  
Drawn By  
**Dayne Gauntlett**  
Scale  
**3/8" = 1'0"**

Sheet  
**MK-3**

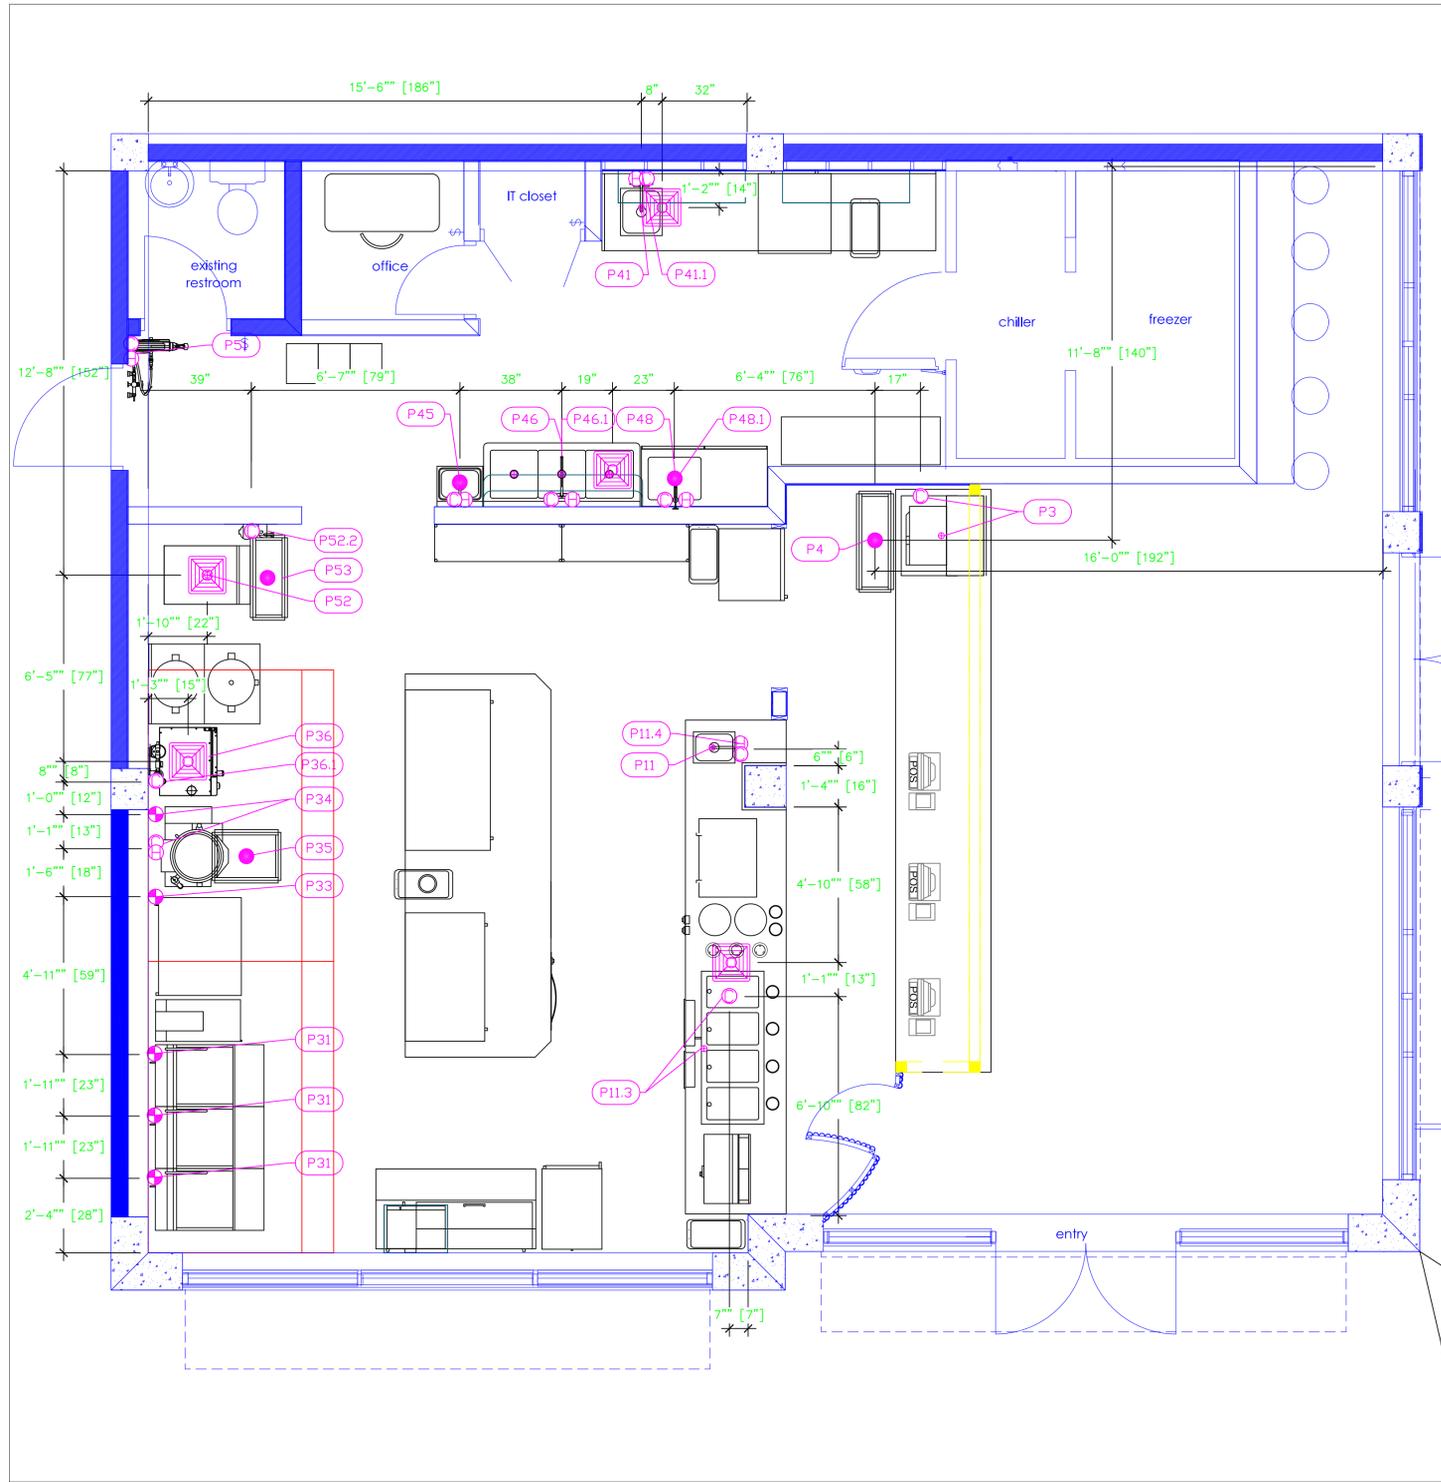

PLUMBING SCHEDULE												
ITEM NO.	DESCRIPTION	COLD WATER SIZE	HOT WATER SIZE	H&C Rough-In	DIRECT WASTE	INDIRECT WASTE	INDIRECT WASTE AFF.	INDIRECT WASTE SIZE	GAS SIZE(IN)	GAS METU	QTY	PLUMBING REMARKS
3	Soda Ice & Beverage Dispenser	3/8"		12"				3/4"			1	Owner to Verify Existing Equipment
4	Floor Trough				4"	0"					1	Floor Trough, Installed by Plumber
11	Rear Serving Counter							1-1/2"			1	Waste to Floor Sink
11.3	Hot Food Wall Unit, Drop-In, Electric	1/4"		Floor				1"			1	Waste to Floor Sink
11.4	Deck Mount Faucet	1/2"	1/2"	Floor							1	Waste to Floor Sink
31	Gas Floor Fryer								1/2"	120.0	3	
33	Hotplate, Countertop, Gas								3/4"	198.0	1	
34	Kettle, Gas, Tilling	3/8"	3/8"	12"					3/4"	43.0	1	See Note P3
35	Floor Trough				4"	0"					1	Floor Trough, Installed by Plumber
36	Combi Oven, Electric	3/4"		n/a				1-1/2"			1	Incoming Water from Filter 36.1
36.1	Water Filtration System, for Steam Equipment	3/8"		12"							1	
41	Work Table, Stainless Steel Top										1	
41.1	Sink							1-1/2"			1	Waste to Floor Sink
41.1	Deck Mount Faucet	1/2"	1/2"	12"							1	
45	Hand Sink	1/2"	1/2"		1-1/2"	24"					1	(1) set of 1" faucet holes, 4" OC, splash mount
46	Three (3) Compartment Sink							(3) 1-1/2"			1	(1) set of 1/2" faucet holes, 8" OC
46.1	Wall / Splash Mount Faucet	1/2"	1/2"	12"							1	
48	Mop Sink Cabinet				2"	0"					1	Mop Sink, Installed by Plumber
48.1	Service Faucet	1/2"	1/2"	36"							1	
51	Enclosed Hose Reel	1/2"	1/2"	36"							1	
52	Ice Cuber	1/2"		n/a				3/4"			1	Incoming water from Filter 52.2
52	Ice Bin							3/4"			1	
52.2	Water Filtration System, for Ice Machines	3/4"		12"							1	
53	Floor Trough				4"	0"					1	Floor Trough, Installed by Plumber
61.1	Evaporator							1"			1	Condensate to floor drain
61.3	Evaporator							1"			1	Condensate to floor drain
2100	Floor Sink				4"	Floor					3	Floor Sink, Installed by Plumber

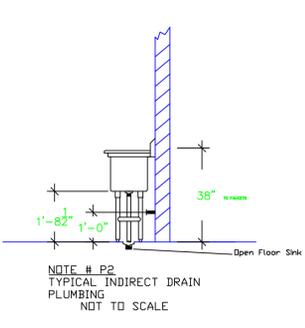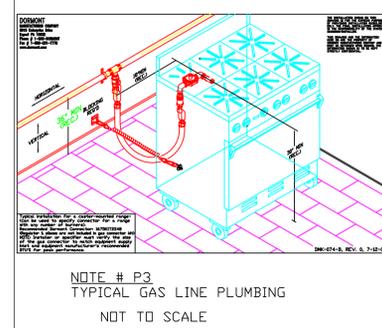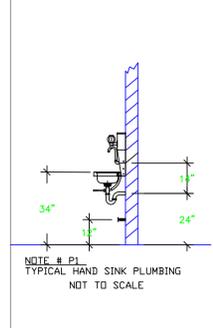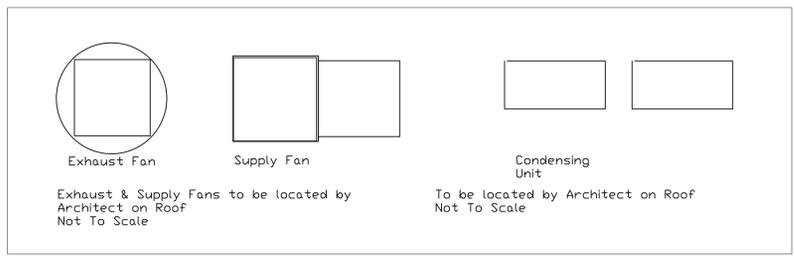

- LEGEND - PLUMBING CONNECTIONS**
- HW-HOT WATER, OR CW-COLD WATER
  - GAS
  - WASTE, DIRECT-CONNECTED
  - WASTE, INDIRECT TO Floor Sink
  - FLOOR DRAIN Josam 30000-A3
  - FUNNEL FLOOR DRAIN Josam 30000-E3
  - FLOOR SINK Zurn FD-2370-Y-PV4-F

**NOTE # P4:** ALL NATIONAL, STATE, AND LOCAL CODES SHALL APPLY

**NOTE # P5:** ALL PLUMBING CONNECTIONS TO BE EXTENDED AND INTERCONNECTED TO EQUIPMENT AND ALL HARDWARE REQUIRED TO BE PROVIDED BY PLUMBING CONTRACTOR

**NOTE # P6:** PLUMBING CONTRACTOR TO VERIFY THAT ALL EQUIPMENT IS INSTALLED WITH THE APPROPRIATE GAS PRESSURE AND REGULATORS

**NOTE # P7:** ALL WASTE LINES AND CONDENSATE LINES TO BE EXTEND FROM EQUIPMENT TO FLOOR DRAINS BY PLUMBING CONTRACTOR.

## Equipment PLUMBING Service Requirements

All Dimensions to be verified on the job site. Actual locations for floor drains, and any ventilating equipment to be determined by Engineer. Mechanical, Plumbing & Electrical to be checked and verified by Customers MEP Engineer. Remote Condensing Units to be located by Architect. Exhaust & Supply fans to be located by Architect.

**Fish Pot - 4 Kitchen**  
Portmore, Jamaica







2055 W 73rd Street, Miami, FL 33016  
Ph:(305)826-8696 Fax:(305)826-9131

6	Updated From Owner Comments.	11-15-18
7	Updated From Owner Comments.	11-19-18
8	Added MEP Sheets	11-28-18
9	Updated Background	1-31-19
No.	Revision/Issue	Date

Date  
**Jan 31, 2019**  
Drawn By  
**Dayne Gauntlett**  
Scale  
**3/8" = 1'0"**

Sheet  
**MK-4**

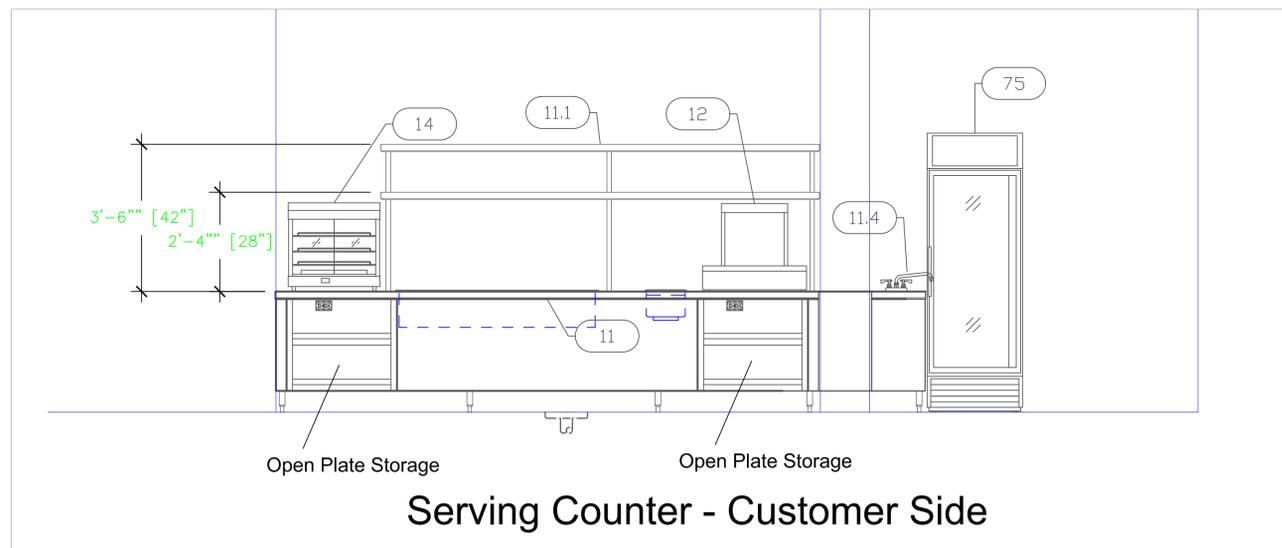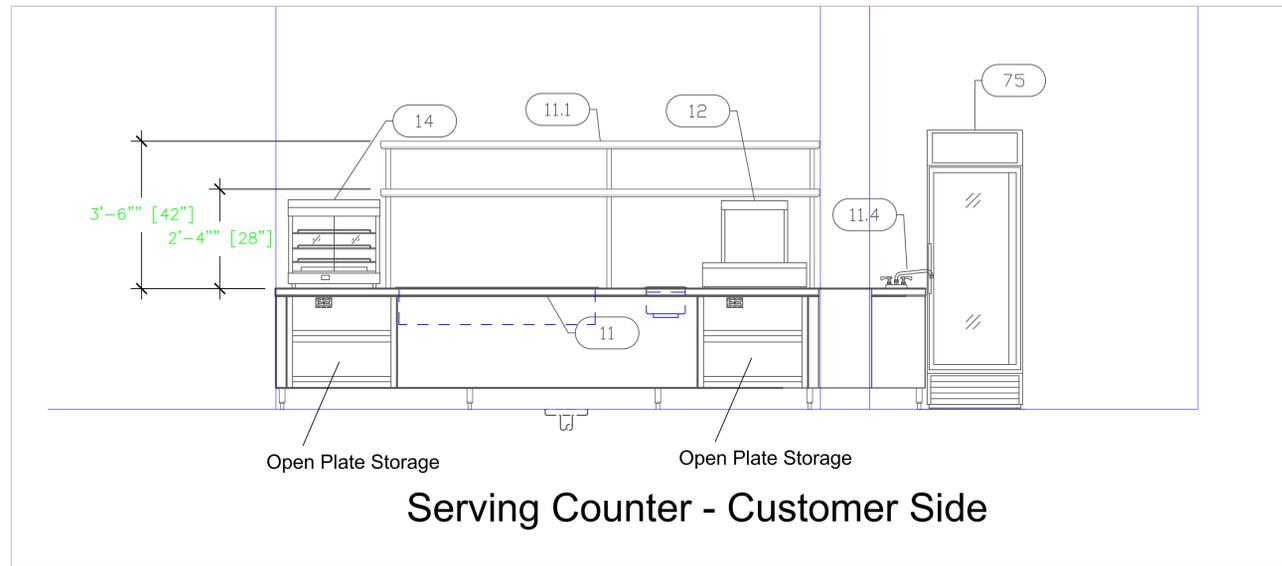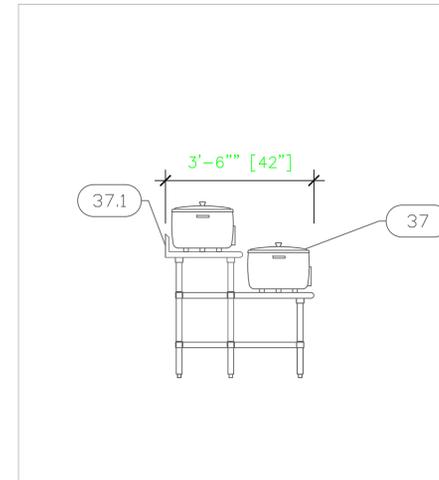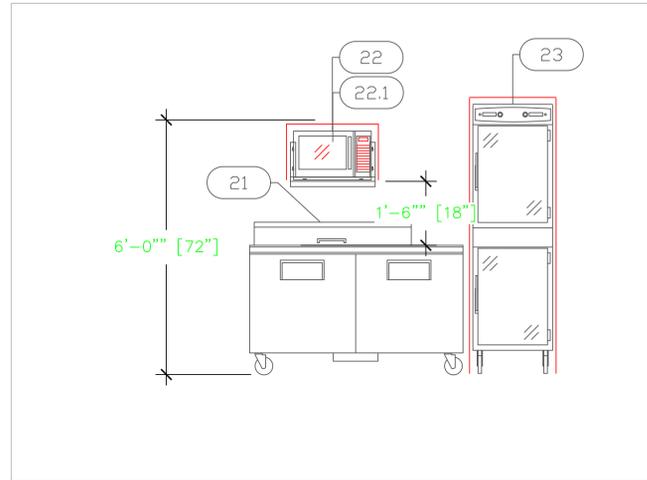

**Fish Pot - 4**  
**Kitchen**  
 Portmore, Jamaica



INTERNATIONAL INC.  
 2055 W 73rd Street, Miami, FL 33016  
 Ph: (305)826-8696 Fax: (305)826-9131

No.	Revision/Issue	Date
6	Updated From Owner Comments.	11-15-18
7	Updated From Owner Comments.	11-19-18
8	Added MEP Sheets	11-28-18
9	Updated Background	1-31-19

Date  
**Jan 31, 2019**  
 Drawn By  
**Dayne Gauntlett**  
 Scale  
**1/2" = 1'**

Sheet  
**MK-5**