

EQUIPMENT SCHEDULE

ItemNo	Category	Mfr	Model	Quantity	Equipment Remarks
1	Drainboard	Krowne	KR18-C24R	1	
2	Hand Sink	Krowne	KR18-12DST	1	
3	Underbar Add-On Unit	Krowne	KR18-T12	1	
	Trash Receptacle, Indoor	Rubbermaid	1971258	1	
4	Underbar Sink Units	Krowne	KR18-33C	1	
5	Spare Number				
6	Blender Station	Krowne	KR18-18BD	1	
6.1	Blender, Bar	Vitamix	036019	2	
7	Ice Bin	Krowne	KR18-24	1	
8	Work Center	Krowne	KR18-PC18	1	
8.1	POS System	POS	POS	1	By Owner/Operator
9	Refrigerated Work Top	True	TWT-27-HC	1	
10	Espresso Cappuccino Machine	Schaerer	COFFEE ART PLUS	1	
10.1	Water Filtration System	Everpure	EV910094	1	
11	Counter, Back Bar	Millwork	COUNTER	1	By Millwork
21.1	Water Filtration System, for Ice Machines	Everpure	EV932421	1	
21	Ice Maker with Bin, Cube-Style	Hoshizaki	KM-115BAJ	1	
22	Reach-In Freezer	True	T-19F-HC	1	
23	Display Case, Dipping, Gelato	Stoelting	CD-BR44-37-WP	1	
24	Mop Sink	Advance Tabco	9-OP-20	1	
24.1	Service Faucet	Krowne	16-127	1	

## EQUIPMENT LAYOUT

All Dimensions to be verified on the job site.  
 Actual locations for floor drains, and any ventilating equipment to be determined by Engineer.  
 Mechanical, Plumbing & Electrical to be checked and verified by Customers MEP Engineer.  
 Remote Condensing Units to be located by Architect.  
 Exhaust & Supply fans to be located by Architect.

**City Zero  
 Juice Bar  
 Miami, Florida**



INTERNATIONAL INC.


2055 W 73rd Street, Miami, FL 33016

Ph: (305)826-8696 Fax: (305)826-9131

No.	Revision/Issue	Date
1	Preliminary Layout	11-16-19
2	Update based on new backgrounds	12-19-19
3	Update based on 1-15-20 conference call	1-16-20
4	Moved 3 bowl sink.	12-17-20

Date  
**Dec 17, 2020**  
 Drawn By  
**Dayne Gauntlett**  
 Scale  
**1/2" = 1'0"**

Sheet  
**FS-1**

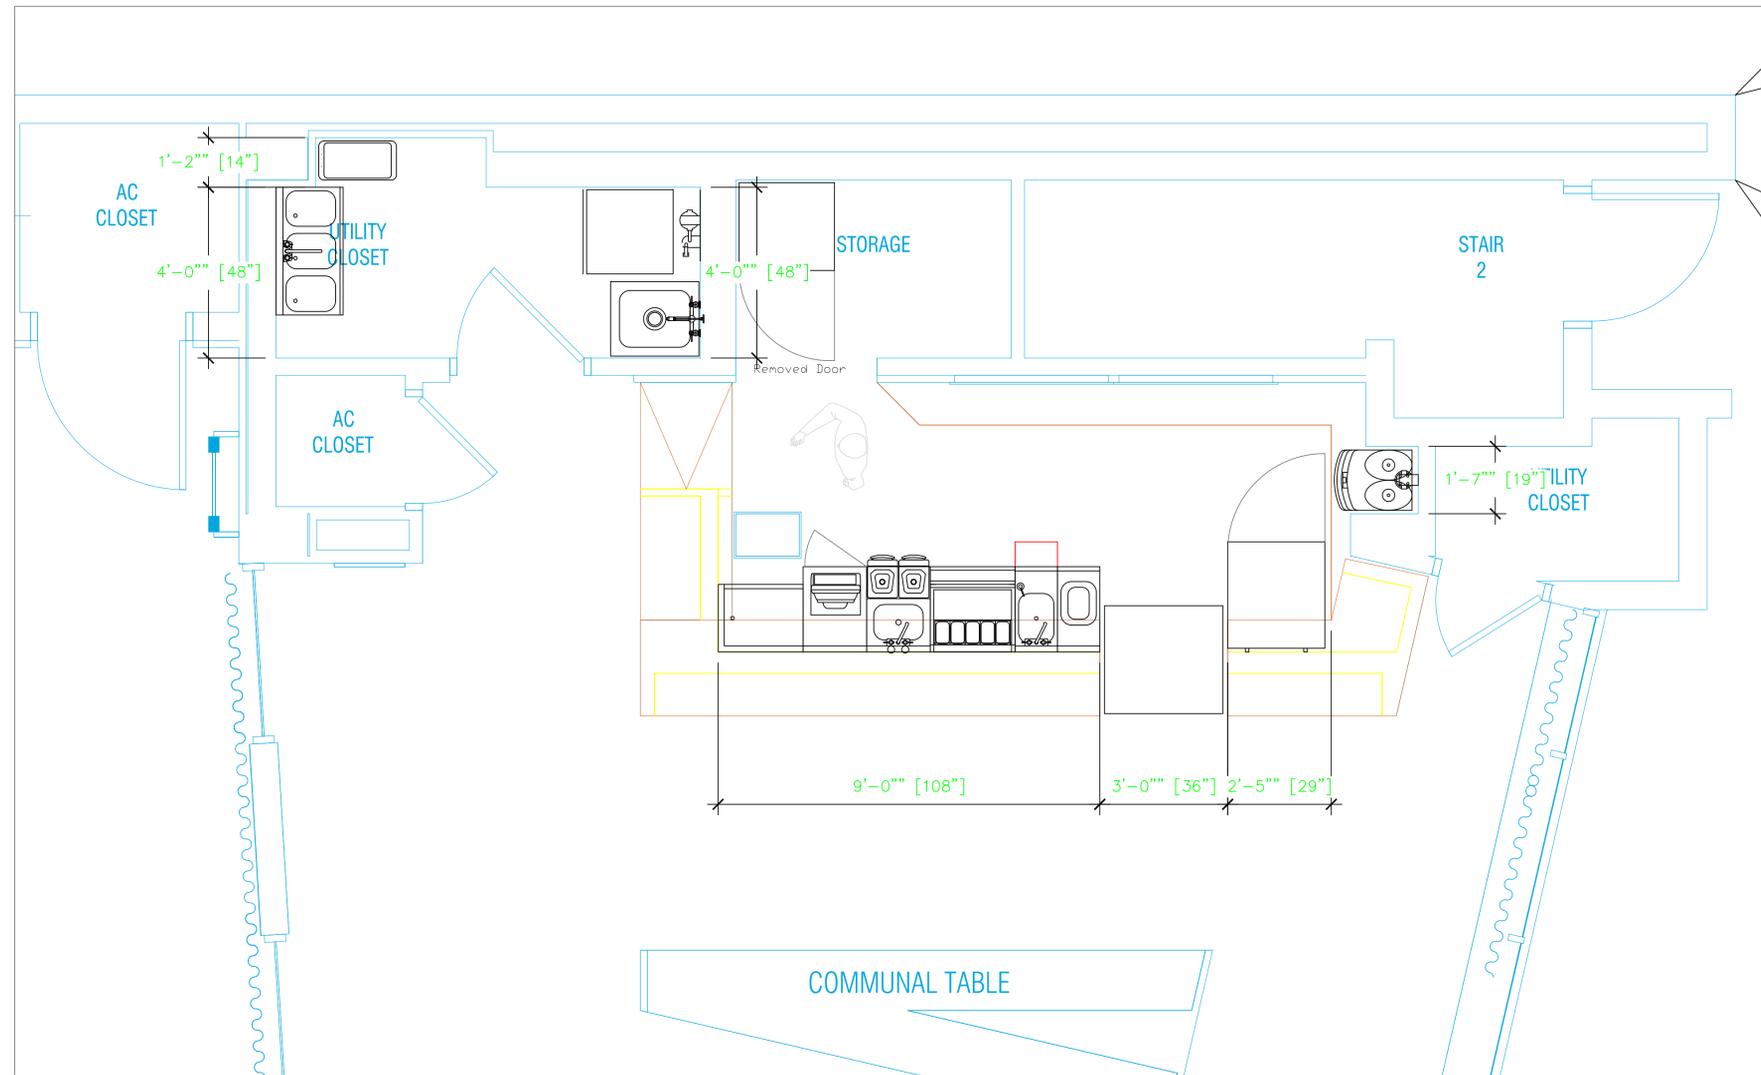

City Zero  
Juice Bar  
Miami, Florida



INTERNATIONAL INC.  
2055 W 73rd Street, Miami, FL 33016  
Ph: (305) 826-8696 Fax: (305) 826-9131

1	Preliminary Layout	11-16-19
2	Update based on new backgrounds	12-19-19
3	Update based on 1-15-20 conference call	1-16-20
4	Moved 3 bowl sink.	12-17-20
No.	Revision/Issue	Date

Date  
Dec 17, 2020  
Drawn By  
Dayne Gauntlett  
Scale  
1/2" = 1'0"





Sheet  
**FS-2**

## Equipment MECHANICAL Service Requirements

All Dimensions to be verified on the job site. Actual locations for floor drains, and any ventilating equipment to be determined by Engineer. Mechanical, Plumbing & Electrical to be checked and verified by Customers MEP Engineer. Remote Condensing Units to be located by Architect. Exhaust & Supply Fans to be located by Architect.

### LEGEND - MECHANICAL

- EXHAUST DUCT COLLAR
- SUPPLY DUCT COLLAR
- INWALL BACKING FOR WALL SHELVES
- RECESSED FLOOR
- RAISED EQUIPMENT PAD

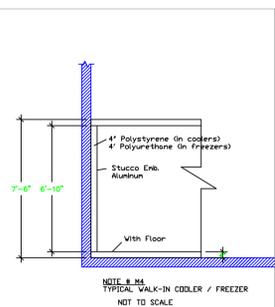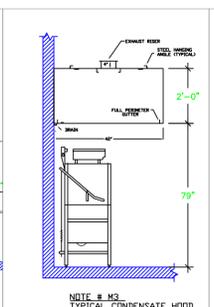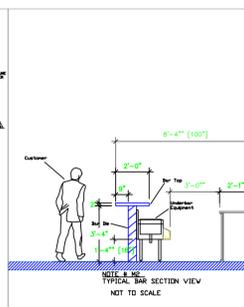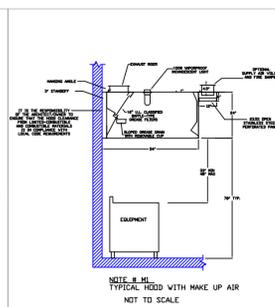

NOTE # M5  
ALL NATIONAL, STATE, AND LOCAL CODES SHALL APPLY

NOTE # M6  
ARCHITECT OR ENGINEER TO SIZE AND LOCATE CONTRACTOR TO PROVIDE ALL OPENINGS FOR DUCTS, PLUMBING LINES, ELECTRICAL LINES, AND REFRIGERATION LINES, AS REQUIRED BY EQUIPMENT.


NOTE # M7  
SUPPLY FANS TO BE LOCATED A MINIMUM OF 10' FROM EXHAUST FANS.

NOTE # M8  
SHOP DRAWING WILL BE PROVIDED BY MANUFACTURER FOR HOOD, EXHAUST FANS, & SUPPLY FANS, ONCE ORDER IS PLACED WITH.

NOTE # M9  
GENERAL CONTRACTOR TO PROVIDE 2" PLYWOOD WALL BACKING FROM 48" TO 78" AFF FOR ALL WALL MOUNTED EQUIPMENT.

NOTE # M10  
CEILING HEIGHTS TO BE VERIFIED FOR SUFFICIENT CLEARANCE FOR EQUIPMENT.


NOTE # M11  
REFRIGERATION CONTRACTOR TO HANG EVAPORATORS FOR WALK-IN, RUN & CHARGE LINES BETWEEN EVAP. & CONDENSING UNIT.

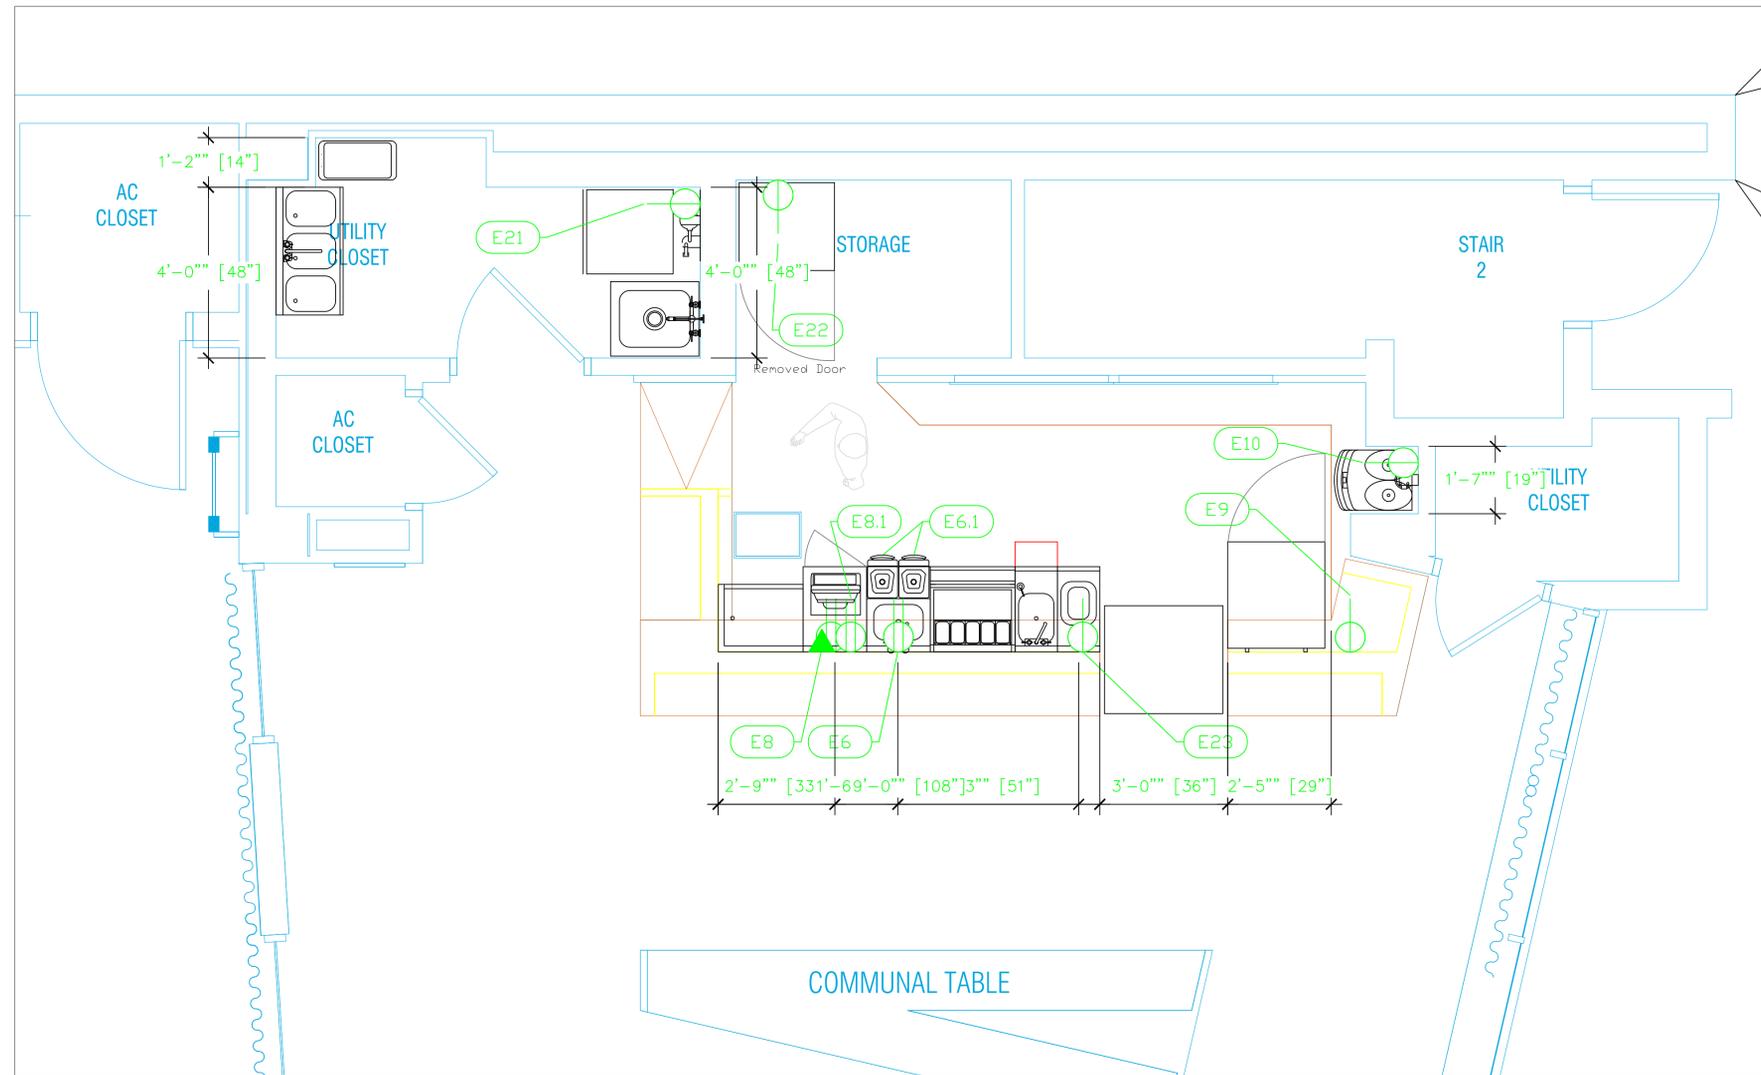

ELECTRICAL SCHEDULE												
ItemNo	Category	Voltage	Cycle	Phase	Amps	Hp	NEMA	ConnectionType	Rough-In AFF	Quantity	Electrical Remarks	
6	Blender Station	115	60	1	15			Duplex	14"	1	Electrician to connect to Outlet on Equipment	
6.1	Blender, Bar	120	50/60	1	15	3	5-15P	Cord & Plug	na	2	Uses Item #6 Outlet	
8	Work Center	115	60	1	15			Duplex	14"	1		
8.1	POS System	115	60	1	15			Duplex	14"	1	Confirm Requirements with Owner	
								DATA	14"	1	Confirm Requirements with Owner	
9	Refrigerated Work Top	115	60	1	2	1/6	5-15P	Simplex	18"	1		
10	Espresso Cappuccino Machine	208	60	1	30		L6-30P	Simplex	48"	1		
21	Ice Maker with Bin, Cube-Style	115	60	1	5.5		5-15P	Simplex	60"	1		
22	Reach-In Freezer	115	60	1	3.7	1/2	5-15P	Simplex	18"	1		
23	Display Case, Dipping, Gelato	115	60	1				Simplex	18"	1	Electrician to provide electrical whip	

**LEGEND -- ELECTRICAL CONNECTIONS**

- DUPLEX RECEPT., 15-AMP, 120-VOLT, GROUND TYPE, HORIZONTAL MOUNT
- SIMPLEX RECEPT., 120-VOLT, GROUND TYPE, HORIZONTAL MOUNT
- SPECIAL PURPOSE OUTLET, GROUND TYPE, HORIZONTAL MOUNT
- JUNCTION BOX, DIRECT CONNECTION
- DISCONNECT SWITCH, DIRECT CONNECTION
- FLOOR/CEILING RECEPTACLE AS INDICATED
- (2) Telephone + (2) Data
- FIELD CONNECTIONS
- HARD WIRE CONNECTION POINT AT MACHINE

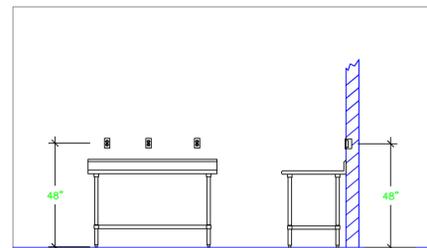

NOTE # E1  
TYPICAL OUTLETS IN WALL ABOVE TABLE, BY ELECTRICIAN NOT TO SCALE

NOTE # E2  
ALL NATIONAL, STATE, AND LOCAL CODES SHALL APPLY

NOTE # E3  
ALL ELECTRICAL CONNECTIONS AND HARDWARE REQUIRED TO BE PROVIDED BY ELECTRICAL CONTRACTOR

NOTE # E4  
ALL JUNCTION BOXES, OUTLETS, ETC. TO BE LOCATED SO AS TO NOT INTERFERE WITH EQUIPMENT

NOTE # E5  
ALL RELAYS, CONTRACTORS, STARTERS, AND SWITCHES REQUIRED FOR EXHAUST & SUPPLY FANS TO BE PROVIDED BY ELECTRICAL CONTRACTOR UNLESS SPECIFIED

NOTE # E6  
ELECTRICAL CONTRACTOR TO INTERCONNECT DISHMACHINE TO EXHAUST FAN FOR DISHMACHINE SO THAT THE FAN RUNS WHEN THE DISHMACHINE IS IN OPERATION.

NOTE # E7  
ELECTRICAL CONTRACTOR TO INSTALL TABLE LIMIT SWITCH TO END OF CLEAN DISHTABLE TO THAT MACHINE STOPS WHEN SWITCH IS DEPRESSED.

NOTE # E8  
ELECTRICAL CONTRACTOR TO CONNECT DRAIN LINE HEATER, PAN HEATER AND DODR HEATER FOR WALK-IN FREEZER.

## Equipment ELECTRICAL Service Requirements

All Dimensions to be verified on the job site. Actual locations for floor drains, and any ventilating equipment to be determined by Engineer. Mechanical, Plumbing & Electrical to be checked and verified by Customers MEP Engineer. Remote Condensing Units to be located by Architect. Exhaust & Supply fans to be located by Architect.

**City Zero  
Juice Bar  
Miami, Florida**




INTERNATIONAL INC.  
2055 W 73rd Street, Miami, FL 33016  
Ph:(305)826-8696 Fax:(305)826-9131

No.	Revision/Issue	Date
1	Preliminary Layout	11-16-19
2	Update based on new backgrounds	12-19-19
3	Update based on 1-15-20 conference call.	1-16-20
4	Moved 3 bowl sink.	12-17-20

Date  
**Dec 17, 2020**  
Drawn By  
**Dayne Gauntlett**  
Scale  
**1/2" = 1'0"**

Sheet  
**FS-3**

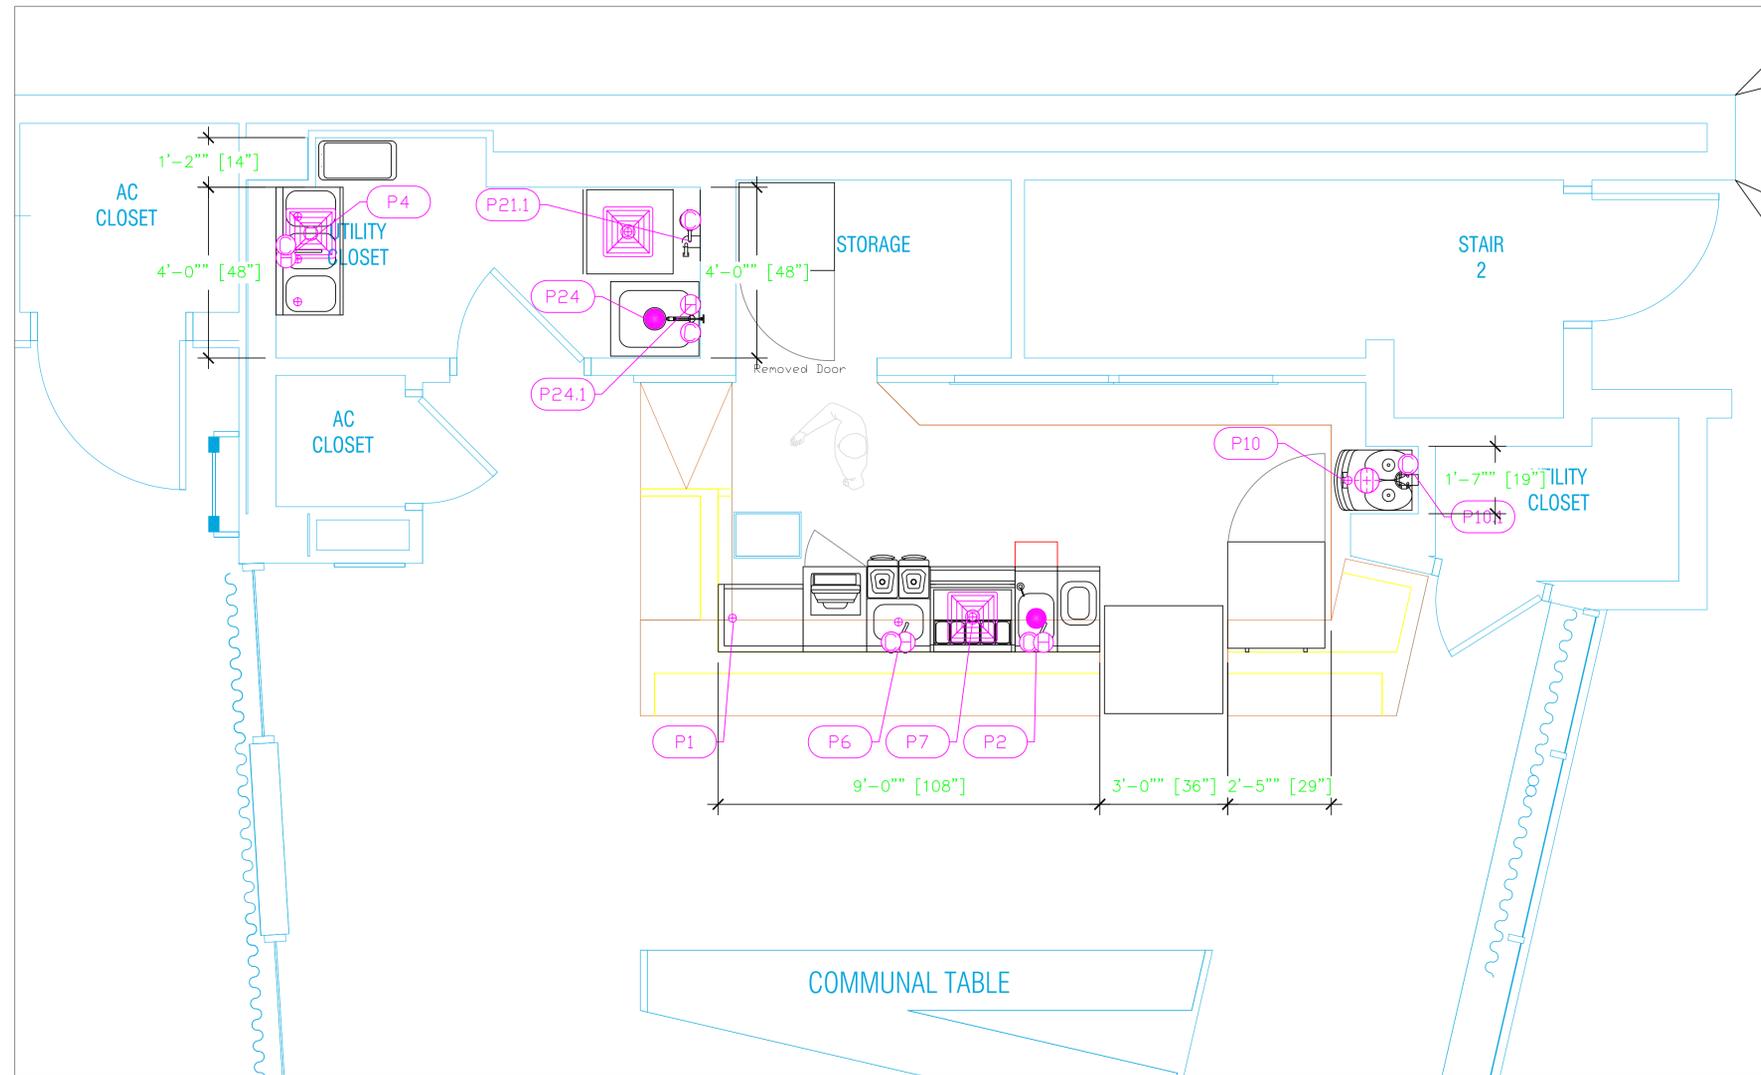

PLUMBING SCHEDULE												
ITEM NO.	DESCRIPTION	COLD WATER SIZE	HOT WATER SIZE	H&C ROUGH-IN	DIRECT WASTE SIZE	DIRECT WASTE AFF	INDIRECT WASTE SIZE	GAS SIZE(IN)	GAS MBTU	QTY	PLUMBING REMARKS	
1	Drainboard						1"			1		
2	Hand Sink	1/2"	1/2"	12"	1-1/2"	16"				1		
4	Underbar Sink Units	1/2"	1/2"	12"			(3) 1-1/2"			1		
6	Blender Station	1/2"	1/2"	12"			1"			1		
7	Ice Bin						1"			1		
10	Espresso Cappuccino Machine	3/8"		na			1-1/2"			1	Connect with Filter	
10.1	Water Softener Conditioner	1"		12"						1		
21	Ice Maker with Bin, Cube-Style	1/2"		na			3/4"			1	Connect with Filter	
21.1	Water Filtration System, for Ice Machines	3/4"		60"						1		
24	Mop Sink				2"					1		
24.1	Service Faucet	1/2"	1/2"	36"						1		

**City Zero  
Juice Bar  
Miami, Florida**



INTERNATIONAL INC.

2055 W 73rd Street, Miami, FL 33016  
Ph:(305)826-8696 Fax:(305)826-9131

No.	Revision/Issue	Date
1	Preliminary Layout	11-16-19
2	Update based on new backgrounds	12-19-19
3	Update based on 1-15-20 conference call	1-16-20
4	Moved 3 bowl sink.	12-17-20

Date

**Dec 17, 2020**

Drawn By




**Dayne Gauntlett**

Scale

**1/2" = 1'0"**

Sheet

**FS-4**

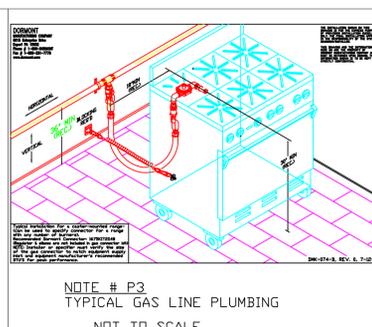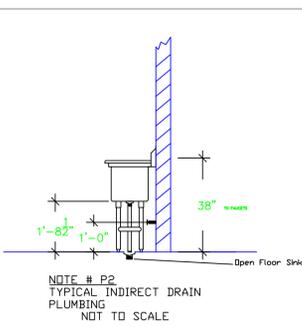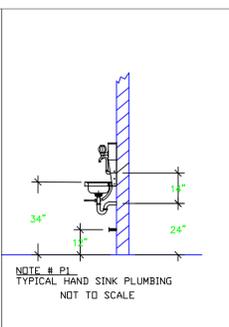

**LEGEND -- PLUMBING CONNECTIONS**

- HW-HOT WATER, OR CW-COLD WATER
- GAS
- WASTE, DIRECT-CONNECTED
- WASTE, INDIRECT TO Floor Sink
- FLOOR DRAIN Josam 30000-A3
- FUNNEL FLOOR DRAIN Josam 30000-E3
- FLOOR SINK Zurn FD-2370-Y-PV4-F

NOTE # P4. ALL NATIONAL, STATE, AND LOCAL CODES SHALL APPLY

NOTE # P5. ALL PLUMBING CONNECTIONS TO BE EXTENDED AND INTERCONNECTED TO EQUIPMENT AND ALL HARDWARE REQUIRED TO BE PROVIDED BY PLUMBING CONTRACTOR

NOTE # P6. PLUMBING CONTRACTOR TO VERIFY THAT ALL EQUIPMENT IS INSTALLED WITH THE APPROPRIATE GAS PRESSURE AND REGULATORS

NOTE # P7. ALL WASTE LINES AND CONDENSATE LINES TO BE EXTEND FROM EQUIPMENT TO FLOOR DRAINS BY PLUMBING CONTRACTOR.

**Equipment  
PLUMBING  
Service Requirements**

All Dimensions to be verified on the job site. Actual locations for floor drains, and any ventilating equipment to be determined by Engineer. Mechanical, Plumbing & Electrical to be checked and verified by Customers MEP Engineer. Remote Condensing Units to be located by Architect. Exhaust & Supply fans to be located by Architect.