

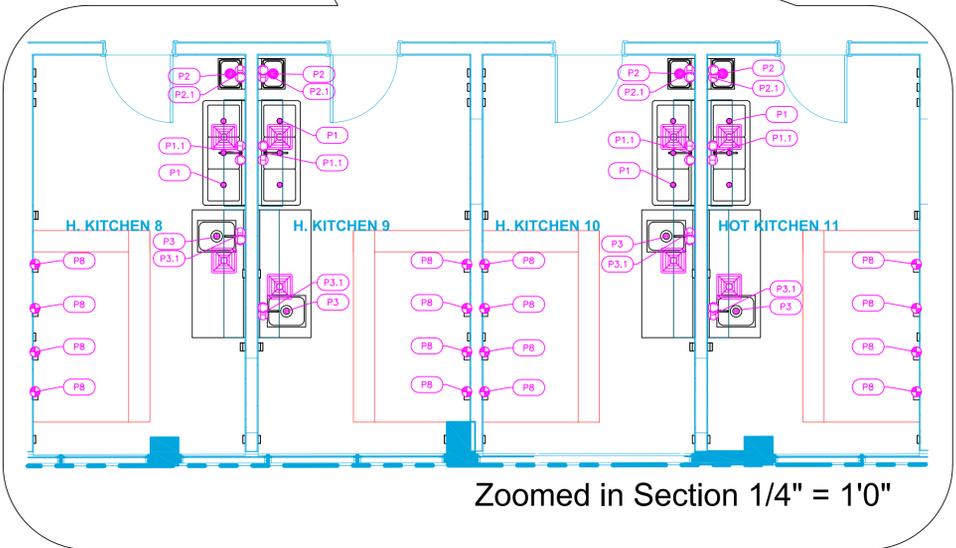
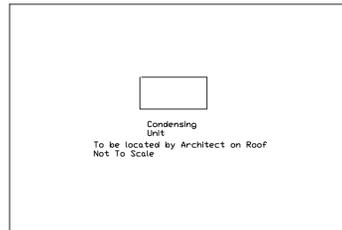
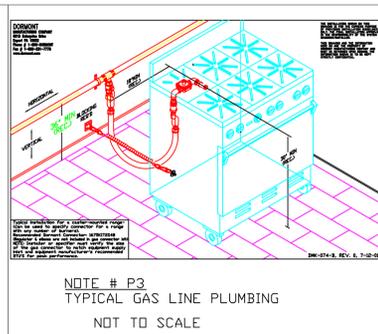


1/8" = 1'0"

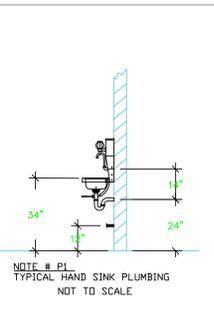

Zoomed in Section 1/4" = 1'0"

PLUMBING SCHEDULE											
ITEM NO.	DESCRIPTION	COLD WATER SIZE	HOT WATER SIZE	H&C Rough-In	DIRECT WASTE SIZE	DIRECT WASTE AFF	INDIRECT WASTE SIZE	GAS SIZE(IN)	GAS MBTU	QTY	PLUMBING REMARKS
1	Three (3) Compartment Sink						(3) 1-1/2"			24	Waste to Floor Sink
1.1	Wall / Splash Mount Faucet	1/2"	1/2"	12"						24	
2	Hand Sink	1/2"	1/2"	12"	1-1/2"	12"				24	See Note P1
2.1	Wall / Splash Mount Faucet	1/2"	1/2"	12"						24	
3	Work Table, with Prep Sink(s)						1-1/2"			24	Waste to Floor Sink
3.1	Deck Mount Faucet	1/2"	1/2"	12"						24	
8	Gas							3/4"	70	72	See Note P3
10	Mop Sink Cabinet				2"	Floor				1	
10.1	Service Faucet	1/2"	1/2"	36"						1	
21.1	Evaporator						1/2"			1	Waste to FFD

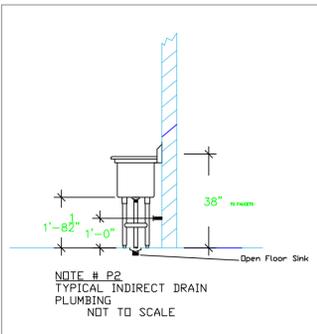

- LEGEND -- PLUMBING CONNECTIONS**
- HW--HOT WATER, OR CW--COLD WATER
 - GAS
 - WASTE, DIRECT--CONNECTED
 - WASTE, INDIRECT to Floor Sink
 - WASTE, INDIRECT to Funnel Floor Drain
 - FLOOR DRAIN Josam 30000-A3
 - WASTE, INDIRECT to Floor Sink Zurn FD-23

NOTE # P4: ALL NATIONAL, STATE, AND LOCAL CODES SHALL APPLY

NOTE # P5: ALL PLUMBING CONNECTIONS TO BE EXTENDED AND INTERCONNECTED TO EQUIPMENT AND ALL HARDWARE REQUIRED TO BE PROVIDED BY PLUMBING CONTRACTOR

NOTE # P6: PLUMBING CONTRACTOR TO VERIFY THAT ALL EQUIPMENT IS INSTALLED WITH THE APPROPRIATE GAS PRESSURE AND REGULATORS

NOTE # P7: ALL WASTE LINES AND CONDENSATE LINES TO BE EXTEND FROM EQUIPMENT TO FLOOR DRAINS BY PLUMBING CONTRACTOR.

Equipment PLUMBING Service Requirements

All Dimensions to be verified on the job site. Actual locations for floor drains, and any ventilating equipment to be determined by Engineer. Mechanical, Plumbing & Electrical to be checked and verified by Customers MEP Engineer. Remote Condensing Units to be located by Architect. Exhaust & Supply fans to be located by Architect.

Kitchen Labs Miami
Cloud Kitchens
 Miami, Florida



2055 W 73rd Street, Miami, FL 33016
 Ph:(305)826-8696 Fax:(305)826-9131

No.	Revision/Issue	Date
2	Update with new background, added storage details	2-4-21
3	Update with new McKenzie background.	2-23-21
4	Added MEP Information	3-2-21
5	Kit 1 to cold, kit 23 to hot	6-22-21

Date
June 22, 2021
 Drawn By
Dayne Gauntlett
 Scale
 1/8" = 1'0"

Sheet
FS-4.0