

ROCK HOUSE
TURKS & CAICOS
GRACE BAY RESORTS
Main Bar




INTERNATIONAL INC.

2055 W 73rd Street, Miami, FL 33016
Ph: (305)826-8696 Fax: (305)826-9131

1	Preliminary Layout	6-26-21
2	Update	7-11-21
3	Adjusted walls and equipment to fit 24'10"	11-24-21
4		
No.	Revision/Issue	Date

Date
Nov. 24, 2021
Drawn By
Dayne Gauntlett
Scale
1/2" = 1'0"

Sheet
FS-1

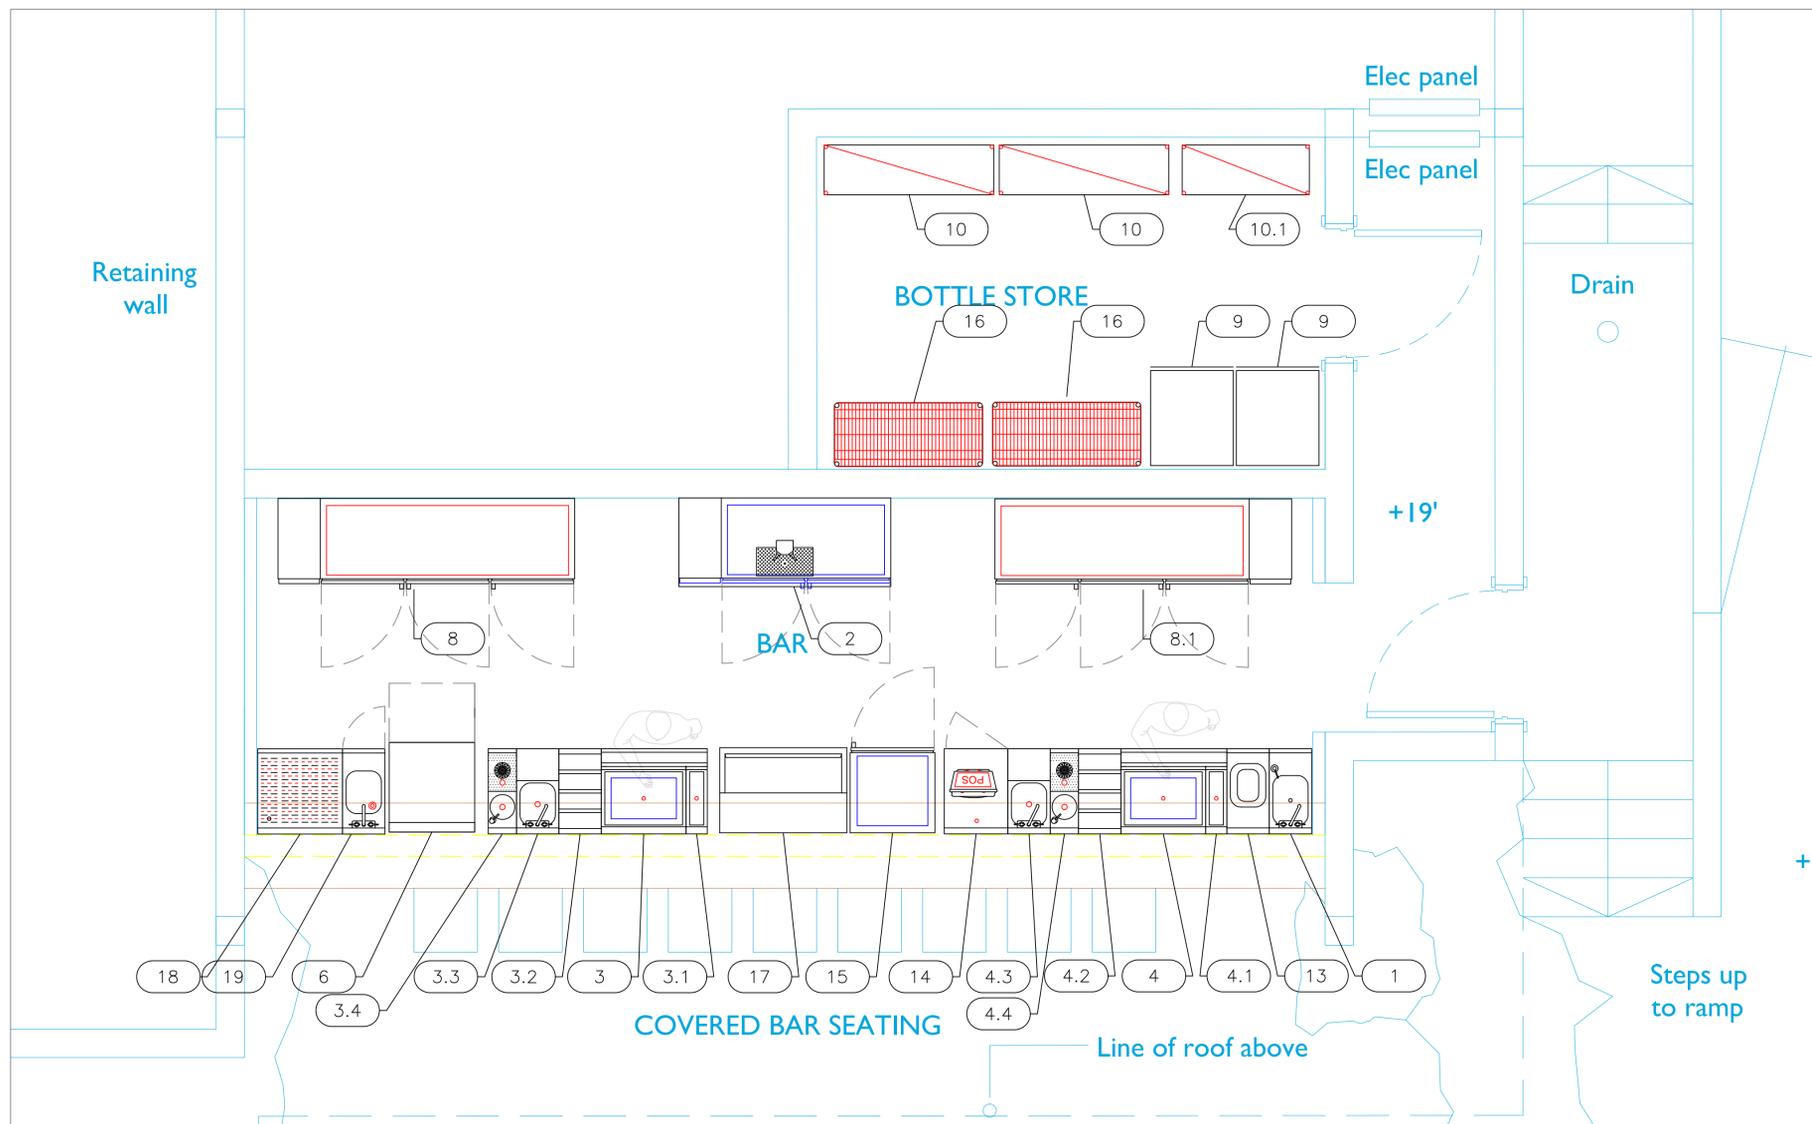

EQUIPMENT SCHEDULE

ItemNo	Category	Mfr	Model	Quantity	Equipment Remarks
1	Hand Sink	Krowne	KR24-12ST	1	
2	Draft Beer Cooler	Krowne	DB60	1	
3	Ice Bin	Krowne	KR19-24-10	1	Future
3.1	Ice Bin	Krowne	KR19-6	1	Future
3.2	Bottle Storage Unit	Krowne	KR24-12RD	1	Future
3.3	Blender Station	Krowne	KR24-12BD	1	Future
3.4	Underbar Sink Units	Krowne	KR24-MD8	1	Future
4	Ice Bin	Krowne	KR19-24-10	1	
4.1	Ice Bin	Krowne	KR19-6	1	
4.2	Bottle Storage Unit	Krowne	KR24-12RD	1	
4.3	Blender Station	Krowne	KR24-12BD	1	
4.4	Underbar Sink Units	Krowne	KR24-MD8	1	
6	Dishwasher, Undercounter	Jackson WWS	DISHSTAR HT-E-SEER	1	
8	Back Bar Cabinet, Refrigerated	Krowne	BS84	1	
8.1	Back Bar Cabinet, Refrigerated	Krowne	BS84	1	
9	Wine Cellar Cabinet	Eurodib USA	USF168S	2	
10	Wine Shelving	Eagle Group	W1448BL	16	
10.1	Wine Shelving	Eagle Group	W1436BL	8	
13	Underbar Add-On Unit	Krowne	KR24-T12	1	
13.1	Underbar Add-On Unit	Krowne	KR24-T14R	1	
14	Work Center	Krowne	KR24-PC18	1	
15	Glass Froster	Krowne	FMC24	1	
16	Wire Shelving Unit	Quantum Food Service	WR63-1842BK	2	
17	Bottle Cooler	Krowne	BC36-SS	1	
18	Glass Rack	Krowne	KR24-GSB3	1	
19	Hand Sink	Krowne	KR24-SD12C	1	

EQUIPMENT LAYOUT

All Dimensions to be verified on the job site.
Actual locations for floor drains, and any ventilating equipment to be determined by Engineer.
Mechanical, Plumbing & Electrical to be checked and verified by Customers MEP Engineer.
Remote Condensing Units to be located by Architect.
Exhaust & Supply fans to be located by Architect.

ROCKHOUSE
TURKS & CAICOS
GRACE BAY RESORTS
Main Bar





INTERNATIONAL INC.
2055 W 73rd Street, Miami, FL 33016
Ph:(305)826-8696 Fax:(305)826-9131

1	Preliminary Layout	6-26-21
2	Update	7-11-21
3	Adjusted walls and equipment to fit 24'10"	11-24-21
4		
No.	Revision/Issue	Date

Date
Nov. 24, 2021
Drawn By
Dayne Gauntlett
Scale
1/2" = 1'0"

Sheet
FS-2

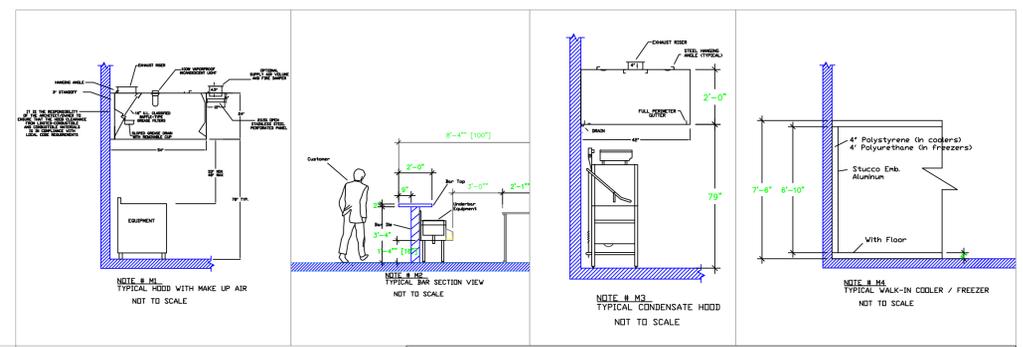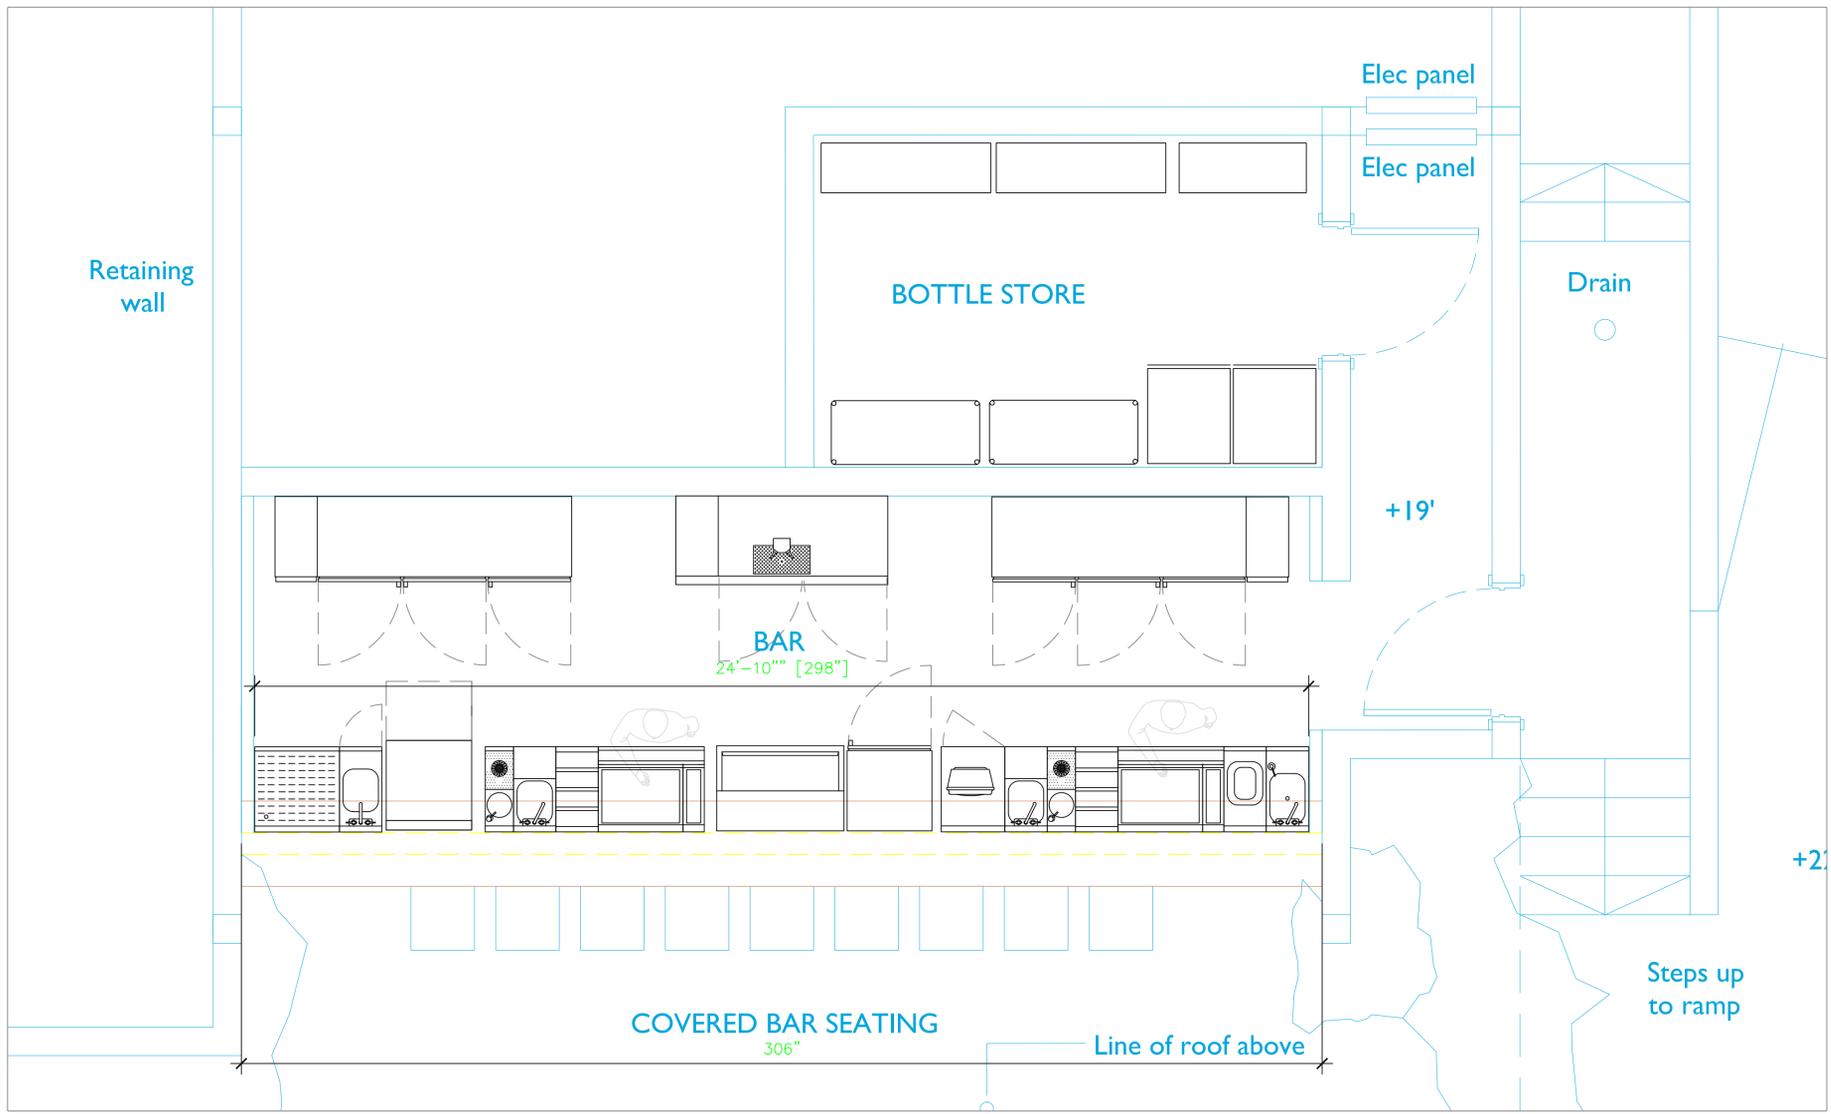

LEGEND — MECHANICAL

- EXHAUST DUCT COLLAR
- SUPPLY DUCT COLLAR
- INWALL BACKING FOR WALL SHELVES
- RECESSED FLOOR
- RAISED EQUIPMENT PAD

NOTE # M5
ALL NATIONAL, STATE, AND LOCAL CODES SHALL APPLY.

NOTE # M6
ARCHITECT OR ENGINEER TO SIZE AND LOCATE, CONTRACTOR TO PROVIDE ALL OPENINGS FOR DUCTS, PLUMBING LINES, ELECTRICAL LINES, AND REFRIGERATION LINES, AS REQUIRED BY EQUIPMENT.

NOTE # M7
SUPPLY FANS TO BE LOCATED A MINIMUM OF 10' FROM EXHAUST FANS.

NOTE # M8
SHOP DRAWING WILL BE PROVIDED BY MANUFACTURER FOR HOOD, EXHAUST FANS, & SUPPLY FANS, UNCE ORDER IS PLACE WITH.

NOTE # M9
GENERAL CONTRACTOR TO PROVIDE 2" PLYWOOD WALL BACKING FROM 48" TO 78" AFF FOR ALL WALL MOUNTED EQUIPMENT.

NOTE # M10
CEILING HEIGHTS TO BE VERIFIED FOR SUFFICIENT CLARENCE FOR EQUIPMENT.

NOTE # M11
REFRIGERATION CONTRACTOR TO HANG EVAPORATORS FOR WALK-IN, RUN & CHARGE LINES BETWEEN EVAP. & CONDENSING UNIT.

Equipment MECHANICAL Service Requirements

All Dimensions to be verified on the job site. Actual locations for floor drains, and any ventilating equipment to be determined by Engineer. Mechanical, Plumbing & Electrical to be checked and verified by Customers MEP Engineer. Remote Condensing Units to be located by Architect. Exhaust & Supply Fans to be located by Architect.




2055 W 73rd Street, Miami, FL 33016
Ph:(305)826-8696 Fax:(305)826-9131

1	Preliminary Layout	6-26-21
2	Update	7-11-21
3	Adjusted walls and equipment to fit 24'10"	11-24-21
4		
No.	Revision/Issue	Date

Date
Nov. 24, 2021
Drawn By
Dayne Gauntlett
Scale
1/2" = 1'0"


Sheet
FS-3

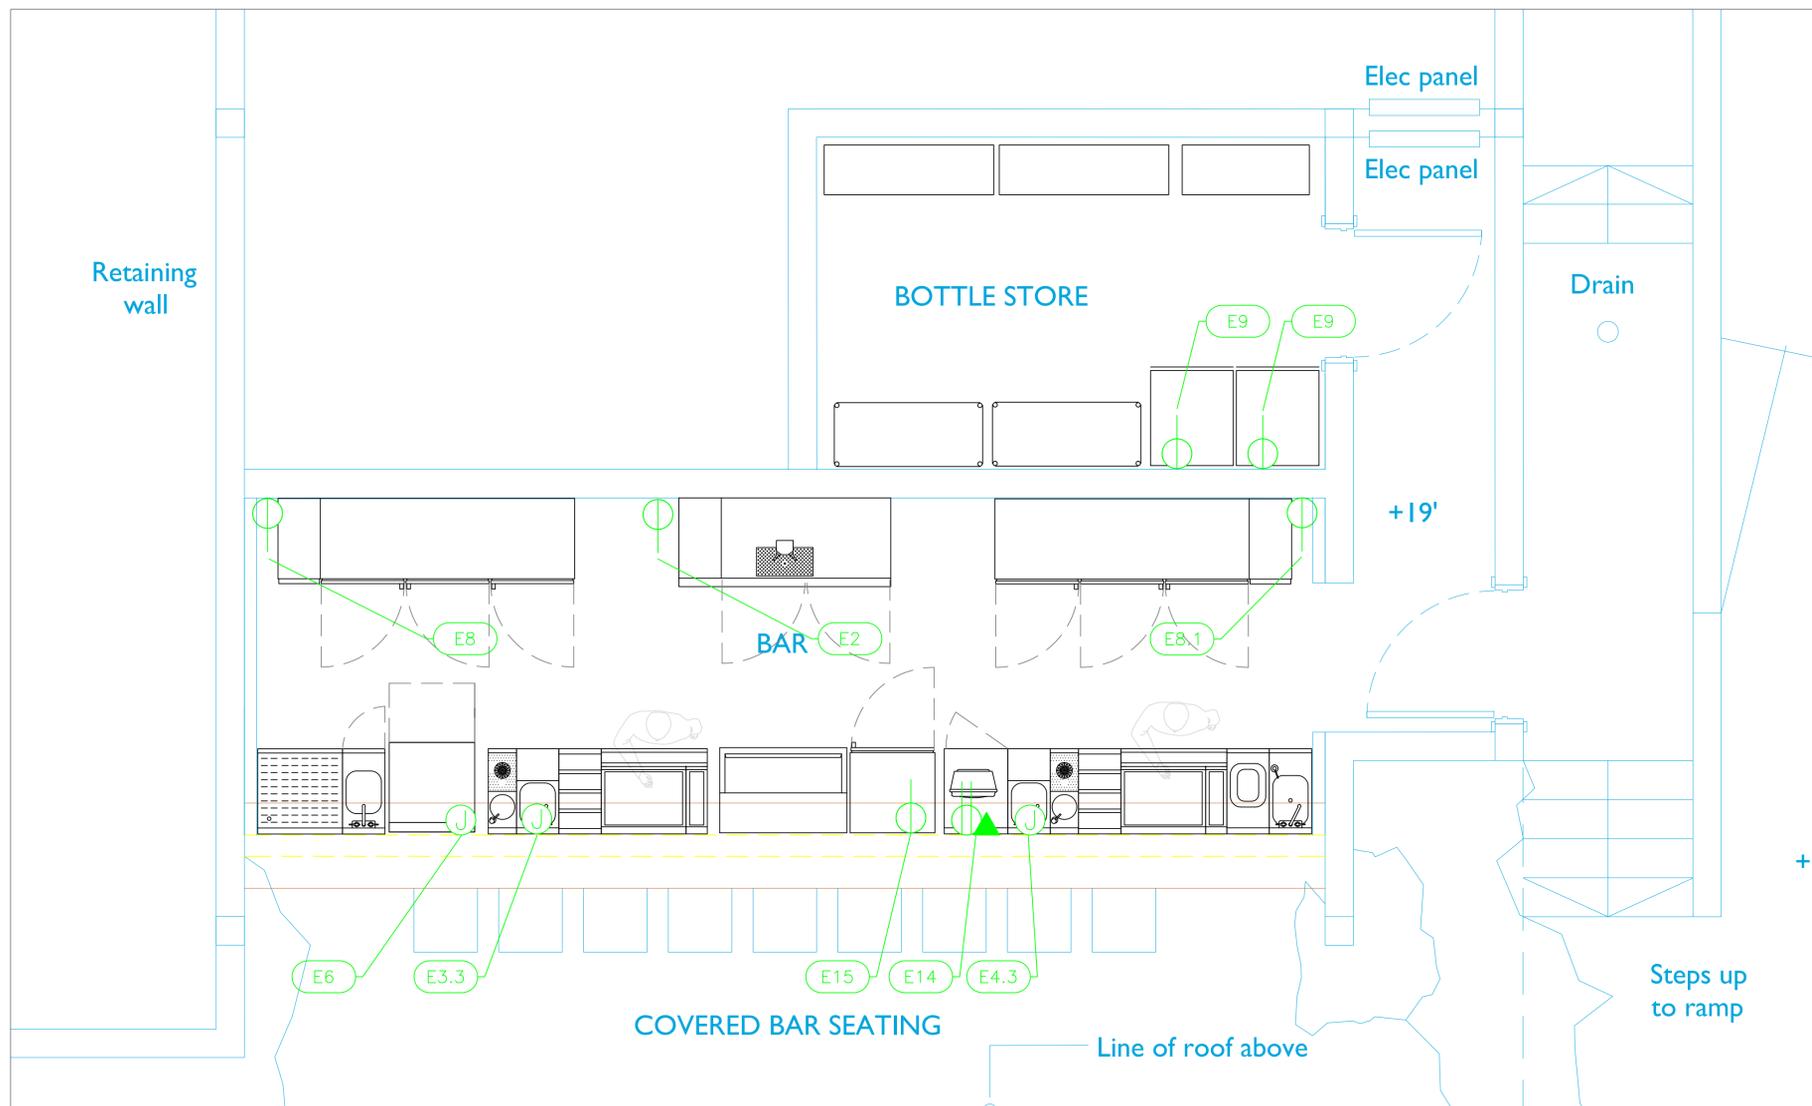

ELECTRICAL SCHEDULE											
ItemNo	Category	Voltage	Cycle	Phase	Amps	Hp	NEMA	ConnectionType	Rough-In AFF	Quantity	Electrical Remarks
2	Draft Beer Cooler	115	60	1	2.2	1/4	5-15P	Simplex	18"	1	
3.3	Blender Station	115	60	1	15			J-Box	14"	1	Electrician to Connect to Receptacle on Equip
4.3	Blender Station	115	60	1	15			J-Box	14"	1	Electrician to Connect to Receptacle on Equip
6	Dishwasher, Undercounter	208	60	1	24.7	1		J-Box	14"	1	Electrician to Hard Wire
8	Back Bar Cabinet, Refrigerated	115	60	1	5.8	1/3	5-15P	Simplex	18"	1	
8.1	Back Bar Cabinet, Refrigerated	115	60	1	5.8	1/3	5-15P	Simplex	18"	1	
9	Wine Cellar Cabinet	110	60	1	1.7			Simplex	18"	2	
14	Work Center	115	60	1	15			Duplex	14"	1	Confirm Requirements with Owner
								DATA	14"	1	Confirm Requirements with Owner
15	Glass Froster	115	60	1	5.2	1/3	5-15P	Simplex	14"	1	Do not plug into GFI outlet
17	Bottle Cooler	115	60	1	4.0	1/5	5-15P	Simplex	14"	1	Do not plug into GFI outlet

LEGEND - ELECTRICAL CONNECTIONS

- DUPLEX RECEPT., 15-AMP, 120-VOLT, GROUND TYPE, HORIZONTAL MOUNT
- SIMPLEX RECEPT., 120-VOLT, GROUND TYPE, HORIZONTAL MOUNT
- SPECIAL PURPOSE OUTLET, GROUND TYPE, HORIZONTAL MOUNT
- JUNCTION BOX, DIRECT CONNECTION
- DISCONNECT SWITCH, DIRECT CONNECTION
- FLOOR/CEILING RECEPTACLE AS INDICATED
- (2) Telephone + (2) Data
- FIELD CONNECTIONS
- HARD WIRE CONNECTION POINT AT MACHINE

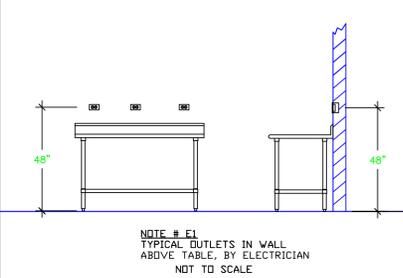

NOTE # E2
ALL NATIONAL, STATE, AND LOCAL CODES SHALL APPLY

NOTE # E3
ALL ELECTRICAL CONNECTIONS AND HARDWARE REQUIRED TO BE PROVIDED BY ELECTRICAL CONTRACTOR

NOTE # E4
ALL JUNCTION BOXES, OUTLETS, ETC. TO BE LOCATED SO AS TO NOT INTERFERE WITH EQUIPMENT

NOTE # E5
ALL RELAYS, CONTRACTORS, STARTERS, AND SWITCHES REQUIRED FOR EXHAUST & SUPPLY FANS TO BE PROVIDED BY ELECTRICAL CONTRACTOR UNLESS SPECIFIED


NOTE # E6
ELECTRICAL CONTRACTOR TO INTERCONNECT DISHMACHINE TO EXHAUST FAN FOR DISHMACHINE SO THAT THE FAN RUNS WHEN THE DISHMACHINE IS IN OPERATION.

NOTE # E7
ELECTRICAL CONTRACTOR TO INSTALL TABLE LIMIT SWITCH TO END OF CLEAN DISHTABLE TO THAT MACHINE STOPS WHEN SWITCH IS DEPRESSED.




NOTE # E8
ELECTRICAL CONTRACTOR TO CONNECT DRAIN LINE HEATER, PAN HEATER AND DDOR HEATER FOR WALK-IN FREEZER.

Equipment ELECTRICAL Service Requirements

All Dimensions to be verified on the job site. Actual locations for floor drains, and any ventilating equipment to be determined by Engineer. Mechanical, Plumbing & Electrical to be checked and verified by Customers MEP Engineer. Remote Condensing Units to be located by Architect. Exhaust & Supply fans to be located by Architect.

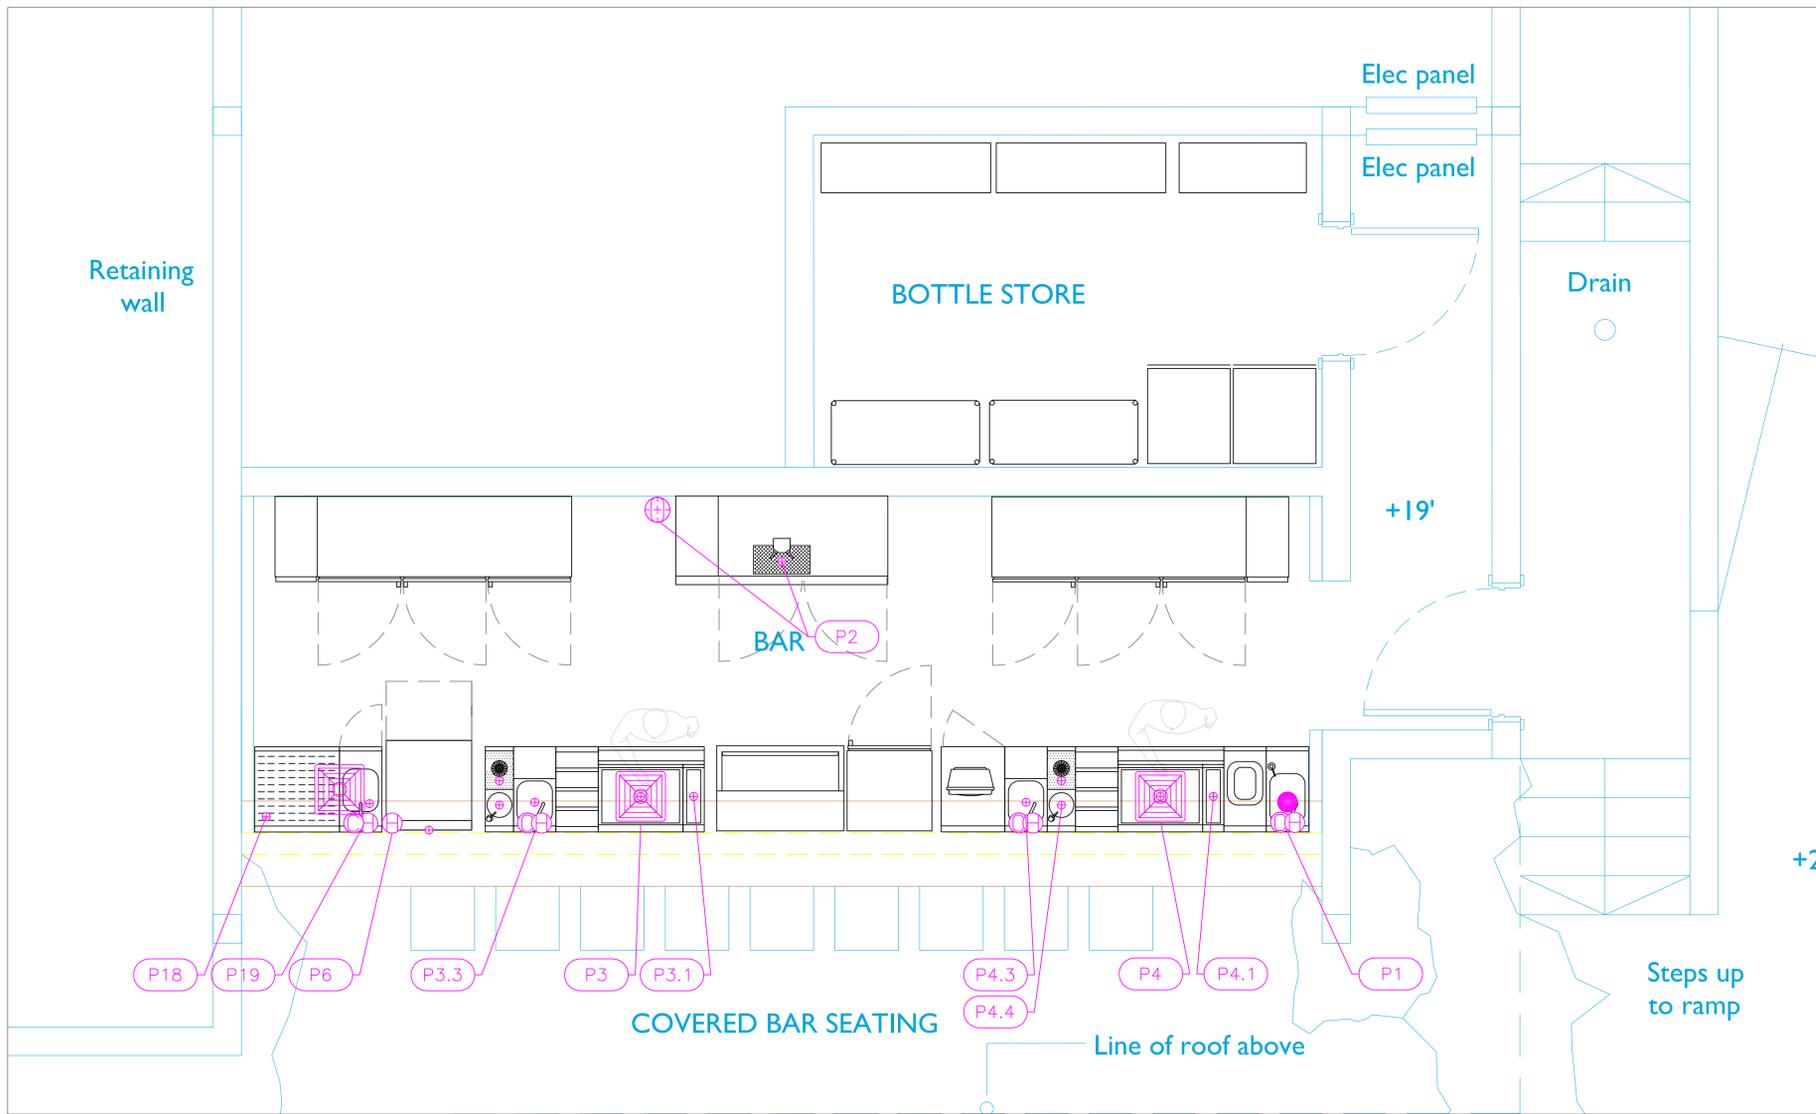

PLUMBING SCHEDULE												
ITEM NO.	DESCRIPTION	COLD WATER SIZE	HOT WATER SIZE	H&C Rough-In	DIRECT WASTE SIZE	DIRECT WASTE AFF	INDIRECT WASTE SIZE	GAS SIZE(IN)	GAS MBTU	QTY	PLUMBING REMARKS	
1	Hand Sink	1/2"	1/2"	12"	1-1/2"	24"				1	See Note P1	
2	Draft Beer Cooler						1/2"			1	Waste to FFD	
3	Ice Bin						1/2"			1	Waste to Floor Sink	
3.1	Ice Bin						1"			1	Waste to Floor Sink	
3.3	Blender Station	1/2"	1/2"	12"			1"			1	Waste to Floor Sink	
3.4	Underbar Sink Units	1/2"		12"			1"			1	Dipperwell, Dipperwell	
4	Ice Bin	1/2"		12"			1/2"			1	Rinser	
4.1	Ice Bin						1/2"			1	Waste to Floor Sink	
4.3	Blender Station	1/2"	1/2"	12"			1"			1	Waste to Floor Sink	
4.4	Underbar Sink Units	1/2"		12"			1"			1	Dipperwell, Dipperwell	

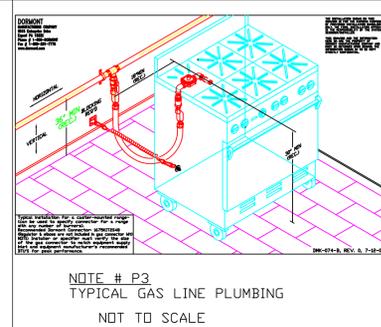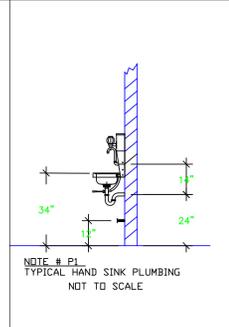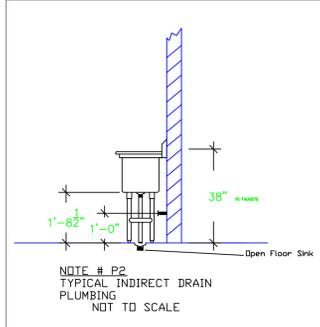

LEGEND -- PLUMBING CONNECTIONS

- HW-HOT WATER, OR CW-COLD WATER
- ⊕ GAS
- WASTE, DIRECT-CONNECTED
- ⊖ WASTE, INDIRECT TO Floor Sink, or Floor Drain
- ⊕ FUNNEL FLOOR DRAIN Josam 30000-E3
- ⊕ FLOOR DRAIN Josam 30000-A3
- ⊕ FLOOR SINK Zurn FD-2370-y-PV4-F
- ⊕ FILTERED WATER, at machine.

NOTE # P4.
ALL NATIONAL, STATE, AND LOCAL CODES SHALL APPLY

NOTE # P5.
ALL PLUMBING CONNECTIONS TO BE EXTENDED AND INTERCONNECTED TO EQUIPMENT AND ALL HARDWARE REQUIRED TO BE PROVIDED BY PLUMBING CONTRACTOR

NOTE # P6.
PLUMBING CONTRACTOR TO VERIFY THAT ALL EQUIPMENT IS INSTALLED WITH THE APPROPRIATE GAS PRESSURE AND REGULATORS

NOTE # P7.
ALL WASTE LINES AND CONDENSATE LINES TO BE EXTEND FROM EQUIPMENT TO FLOOR DRAINS BY PLUMBING CONTRACTOR.

Equipment PLUMBING Service Requirements

All Dimensions to be verified on the job site. Actual locations for floor drains, and any ventilating equipment to be determined by Engineer. Mechanical, Plumbing & Electrical to be checked and verified by Customers MEP Engineer. Remote Condensing Units to be located by Architect. Exhaust & Supply fans to be located by Architect.

ROCKHOUSE
TURKS & CAICOS
GRACE BAY RESORTS
Main Bar

uni-source SUPPLY
INTERNATIONAL INC.
2055 W 73rd Street, Miami, FL 33016
Ph:(305)826-8696 Fax:(305)826-9131

1	Preliminary Layout	6-26-21
2	Update	7-11-21
3	Adjusted walls and equipment to fit 24'10"	11-24-21
4		
No.	Revision/Issue	Date

Date
Nov. 24, 2021
Drawn By
Dayne Gauntlett
Scale
1/2" = 1'0"

Sheet
FS-4