

EQUIPMENT SCHEDULE

| ItemNo | Category | Mfr | Model | Quantity | Equipment Remarks |
|--------|--------------------------------|-------------|--------------|----------|-------------------|
| 1 | Ice Bin | Glastender | IBA-24-CP10 | 2 | |
| 2 | Underbar Add-On Unit | Glastender | DWB-12 | 2 | |
| 3 | Bottle Display | Glastender | LDA-18S | 2 | |
| 4 | Work Center | Glastender | PCB-18 | 2 | |
| 5 | Underbar Mixology Sink Unit | Glastender | MFT-8 | 2 | |
| 6 | Back Bar Cabinet, Refrigerated | Glastender | C1SB48 | 1 | |
| 6.1 | Back Bar Cabinet, Refrigerated | Glastender | C1SB48 | 1 | |
| 6.2 | Glass Froster | Glastender | F1SB28 | 1 | |
| 7 | Dishwasher, Undercounter | Jackson WWS | DISHSTAR LTH | 1 | |
| 9 | Ice Maker with Bin, Cube-Style | Scotsman | CU0920MA-1 | 1 | |
| 9.1 | Ice Flaker with Bin | Scotsman | UF2020A-1 | 1 | |
| 10 | Hand Sink | Glastender | HSA-12 | 2 | |
| 12 | Mop Sink | Custom Fab | 9-OP-40DF | 1 | |
| 12.1 | Service Faucet | Krowne | 16-127 | 1 | |
| 13 | POS System | POS | POS | 2 | By Owner/Operator |
| 14 | Drink Rail | Emjac | F34659-14 | 2 | |
| 15 | Filler Panel | Emjac | FILLER | 4 | |
| 16 | Cabinet | Emjac | CABINET | 1 | |
| 16.1 | Cabinet | Emjac | CABINET | 1 | |
| 16.2 | Cabinet | Emjac | CABINET | 1 | |

Dec 09, 2020

| No. | Revision/Issue | Date |
|-----|---|----------|
| 4 | Added Electrical & Plumbing requirements. | 12-17-19 |
| 5 | #14 drink rail, 6.2 freezer, #15 backbar support added. | 10-14-20 |
| 6 | Updated ice machines. | 11-18-20 |
| 7 | Corrected Length of Drink Rails | 12-9-20 |

EQUIPMENT LAYOUT

All Dimensions to be verified on the job site. Actual locations for floor drains, and any ventilating equipment to be determined by Engineer. Mechanical, Plumbing & Electrical to be checked and verified by Customers MEP Engineer. Remote Condensing Units to be located by Architect. Exhaust & Supply fans to be located by Architect.

ARCHITECT
 INTERIOR DESIGNER
 LANDSCAPE ARCHITECT

URBAN ROBOT LLC
 420 LINCOLN ROAD, S.600
 MIAMI BEACH, FL 33139
 T: 786.246.4857
 F: 786.768.2537
 AA6002780, B23001534, LC20000510

OWNER:
 DOUG LEVINE
 2780 N. BAY ROAD
 MIAMI BEACH, FL 33140
 O: (786) 977-5322

STRUCTURAL ENGINEER:
 YHCE ENGINEERING
 99 NW 27 AVE
 MIAMI, FL 33125
 O: (305) 969-YHCE

M.E.P. ENGINEERS:
 H. VIDAL & ASSOCIATES
 241 NW SOUTH RIVER DR
 MIAMI, FL 33128
 O: (305) 571-1880

FOOD SERVICE DESIGN:
 UNI-SOURCE SUPPLY INTL
 2055 W 73RD STREET
 HIALEAH, FL 33016
 O: (305) 526-8696 EXT. 111

VINYL RECORD BAR
 WYNWOOD



REVISIONS

| REV | DESCRIPTION | DATE |
|-----|-------------|------|
| | | |
| | | |
| | | |
| | | |
| | | |

SEAL

URBAN ROBOT LLC
 ARCHITECT/ INTERIOR DESIGNER/ LANDSCAPE ARCHITECT


1926
 PROJECT NO.
 01/20/2020
 DATE
 AR & SC / AR & GP
 DRAWN / CHECKED
 TB

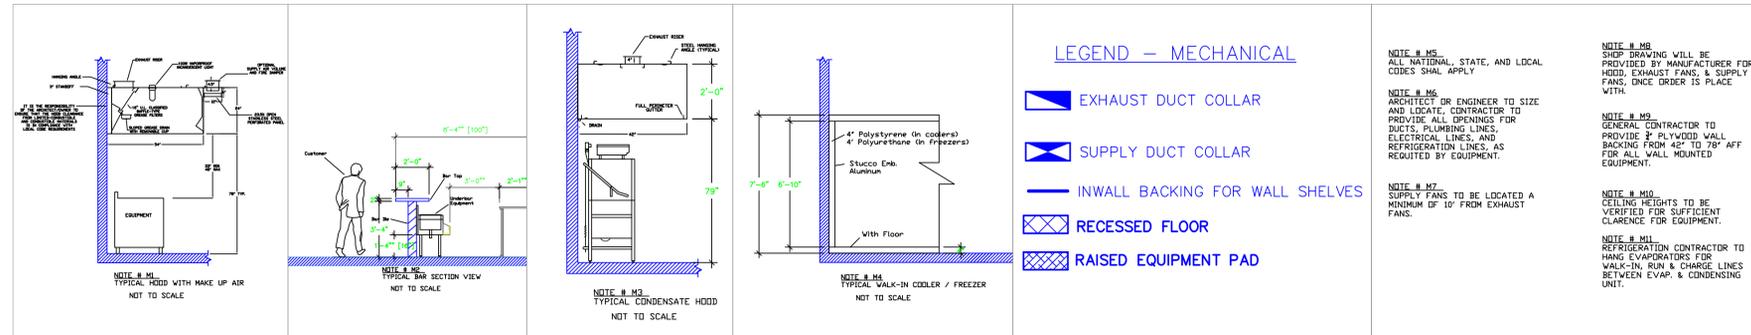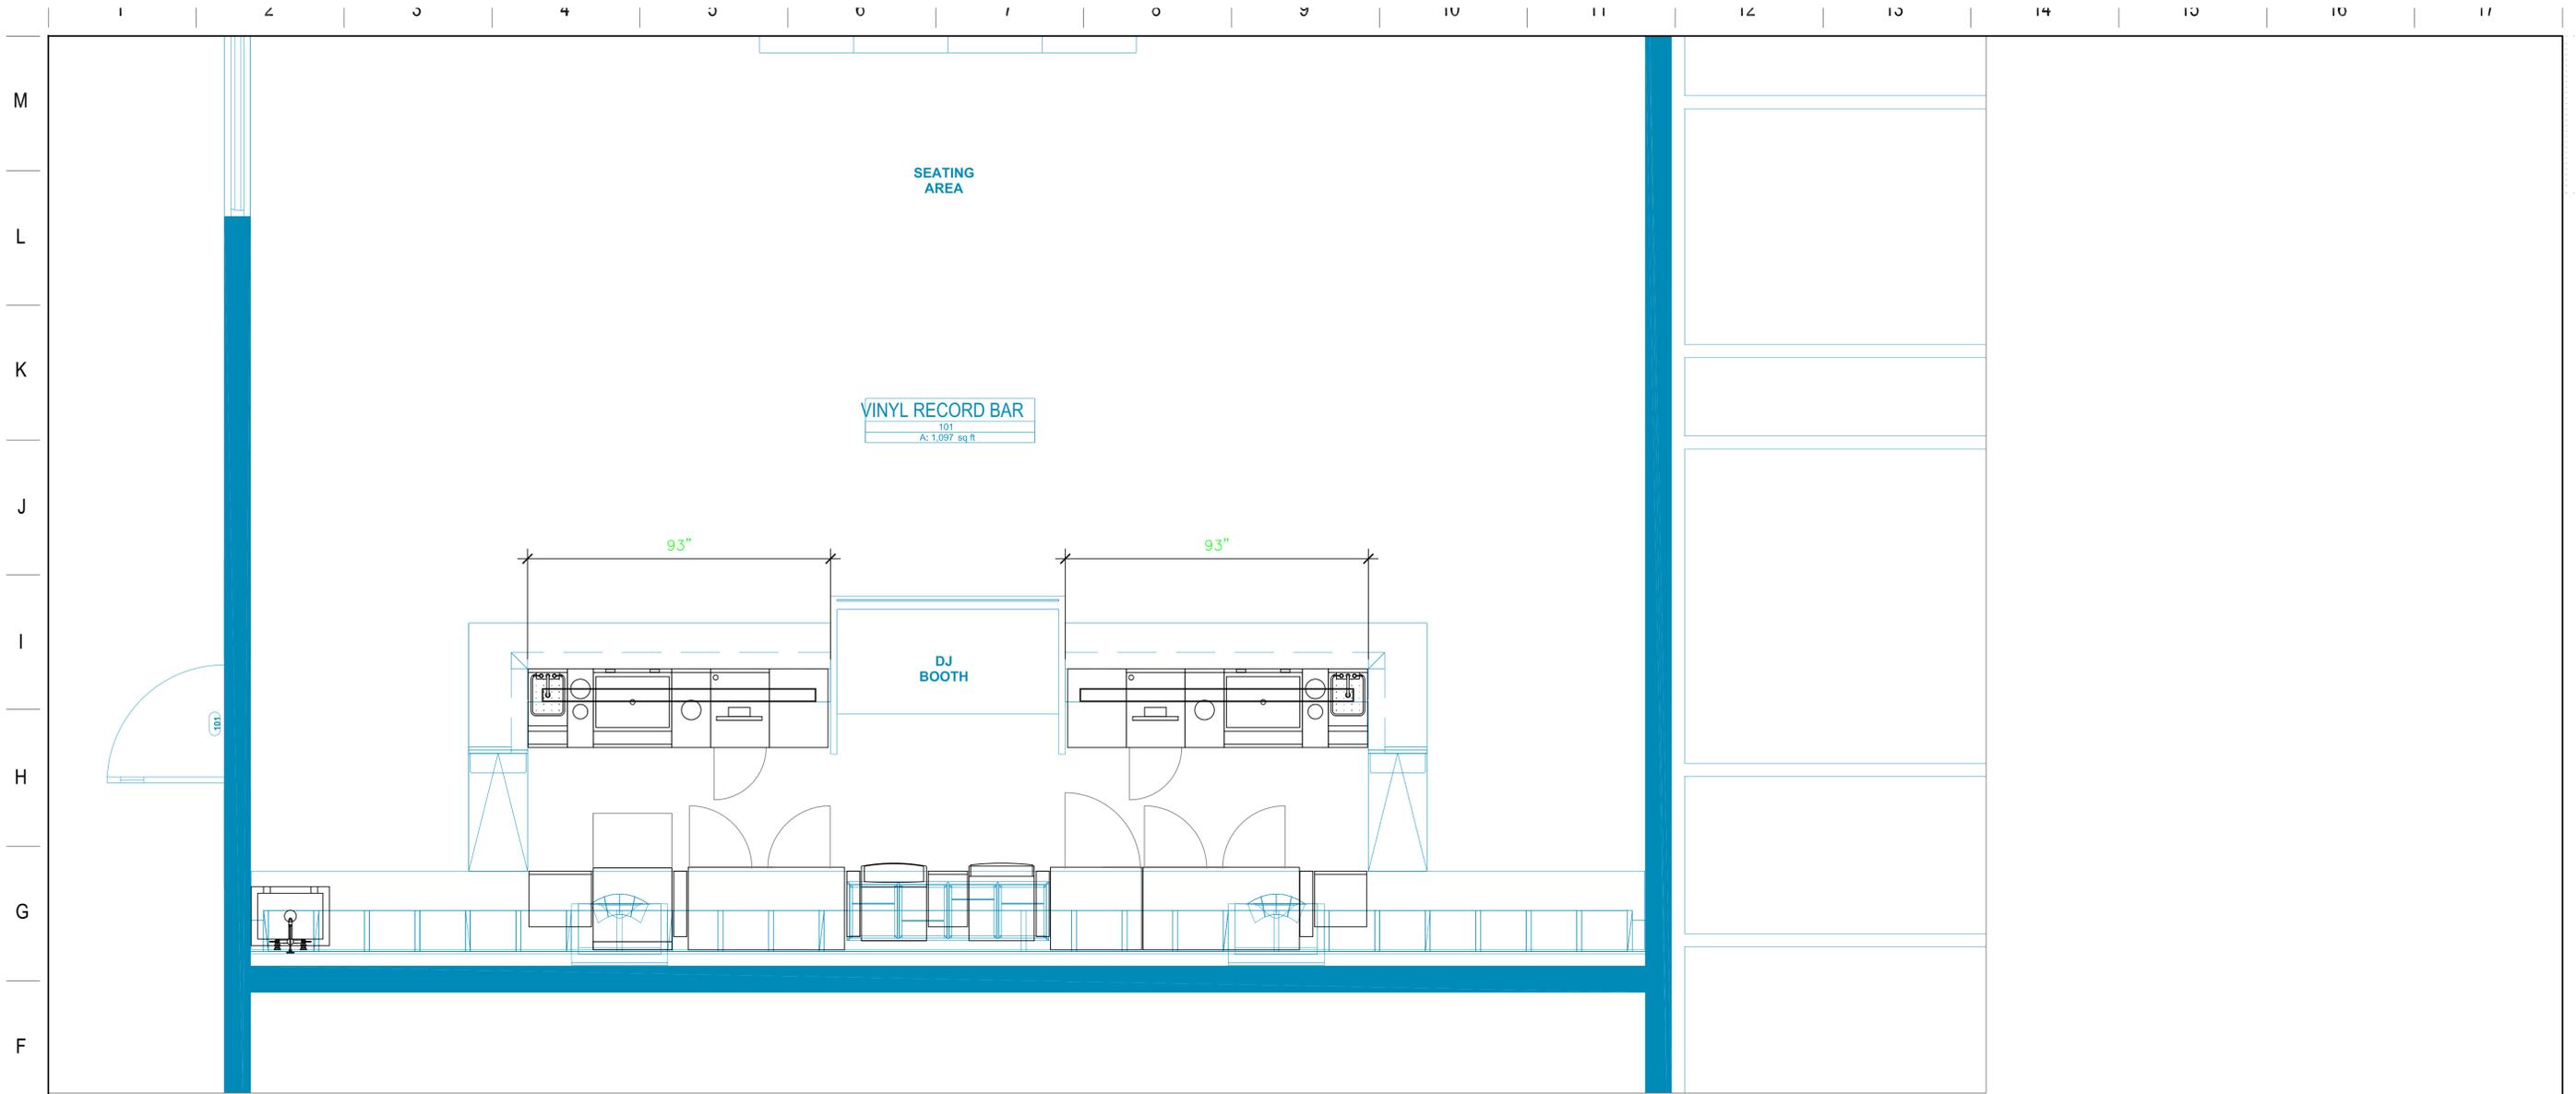

Equipment MECHANICAL Service Requirements

All Dimensions to be verified on the job site. Actual locations for floor drains, and any ventilating equipment to be determined by Engineer. Mechanical, Plumbing & Electrical to be checked and verified by Customers MEP Engineer. Remote Condensing Units to be located by Architect. Exhaust & Supply Fans to be located by Architect.

 ARCHITECT
INTERIOR DESIGNER
LANDSCAPE ARCHITECT



URBAN ROBOT LLC
420 LINCOLN ROAD, S.601
MIAMI BEACH, FL 33139
T: 786.246.4857
F: 786.768.2537

AA602780 B26001534 LC26000510

OWNER:

DOUG LEVINE
2780 N. BAY ROAD
MIAMI BEACH, FL 33140
O: (786) 977-5322

STRUCTURAL ENGINEER:

YHCE ENGINEERING
99 NW 27 AVE
MIAMI, FL 33125
O: (305) 969-YHCE

M.E.P. ENGINEERS:

H. VIDAL & ASSOCIATES
241 NW SOUTH RIVER DR
MIAMI, FL 33128
O: (305) 571-1880

FOOD SERVICE DESIGN:

UNI-SOURCE SUPPLY INTL
2055 W 73RD STREET
HALEAH, FL 33016
O: (305) 826-8696 EXT. 111

VINYL RECORD BAR
WYNWOOD

REVISIONS

| REV | DESCRIPTION | DATE |
|-----|-------------|------|
| | | |
| | | |
SEAL

URBAN ROBOT LLC
AA602780 B26001534 LC26000510

1926

PROJECT NO.


01/20/2020

DATE

AR & SC / AR & GP

DRAWN / CHECKED

TB

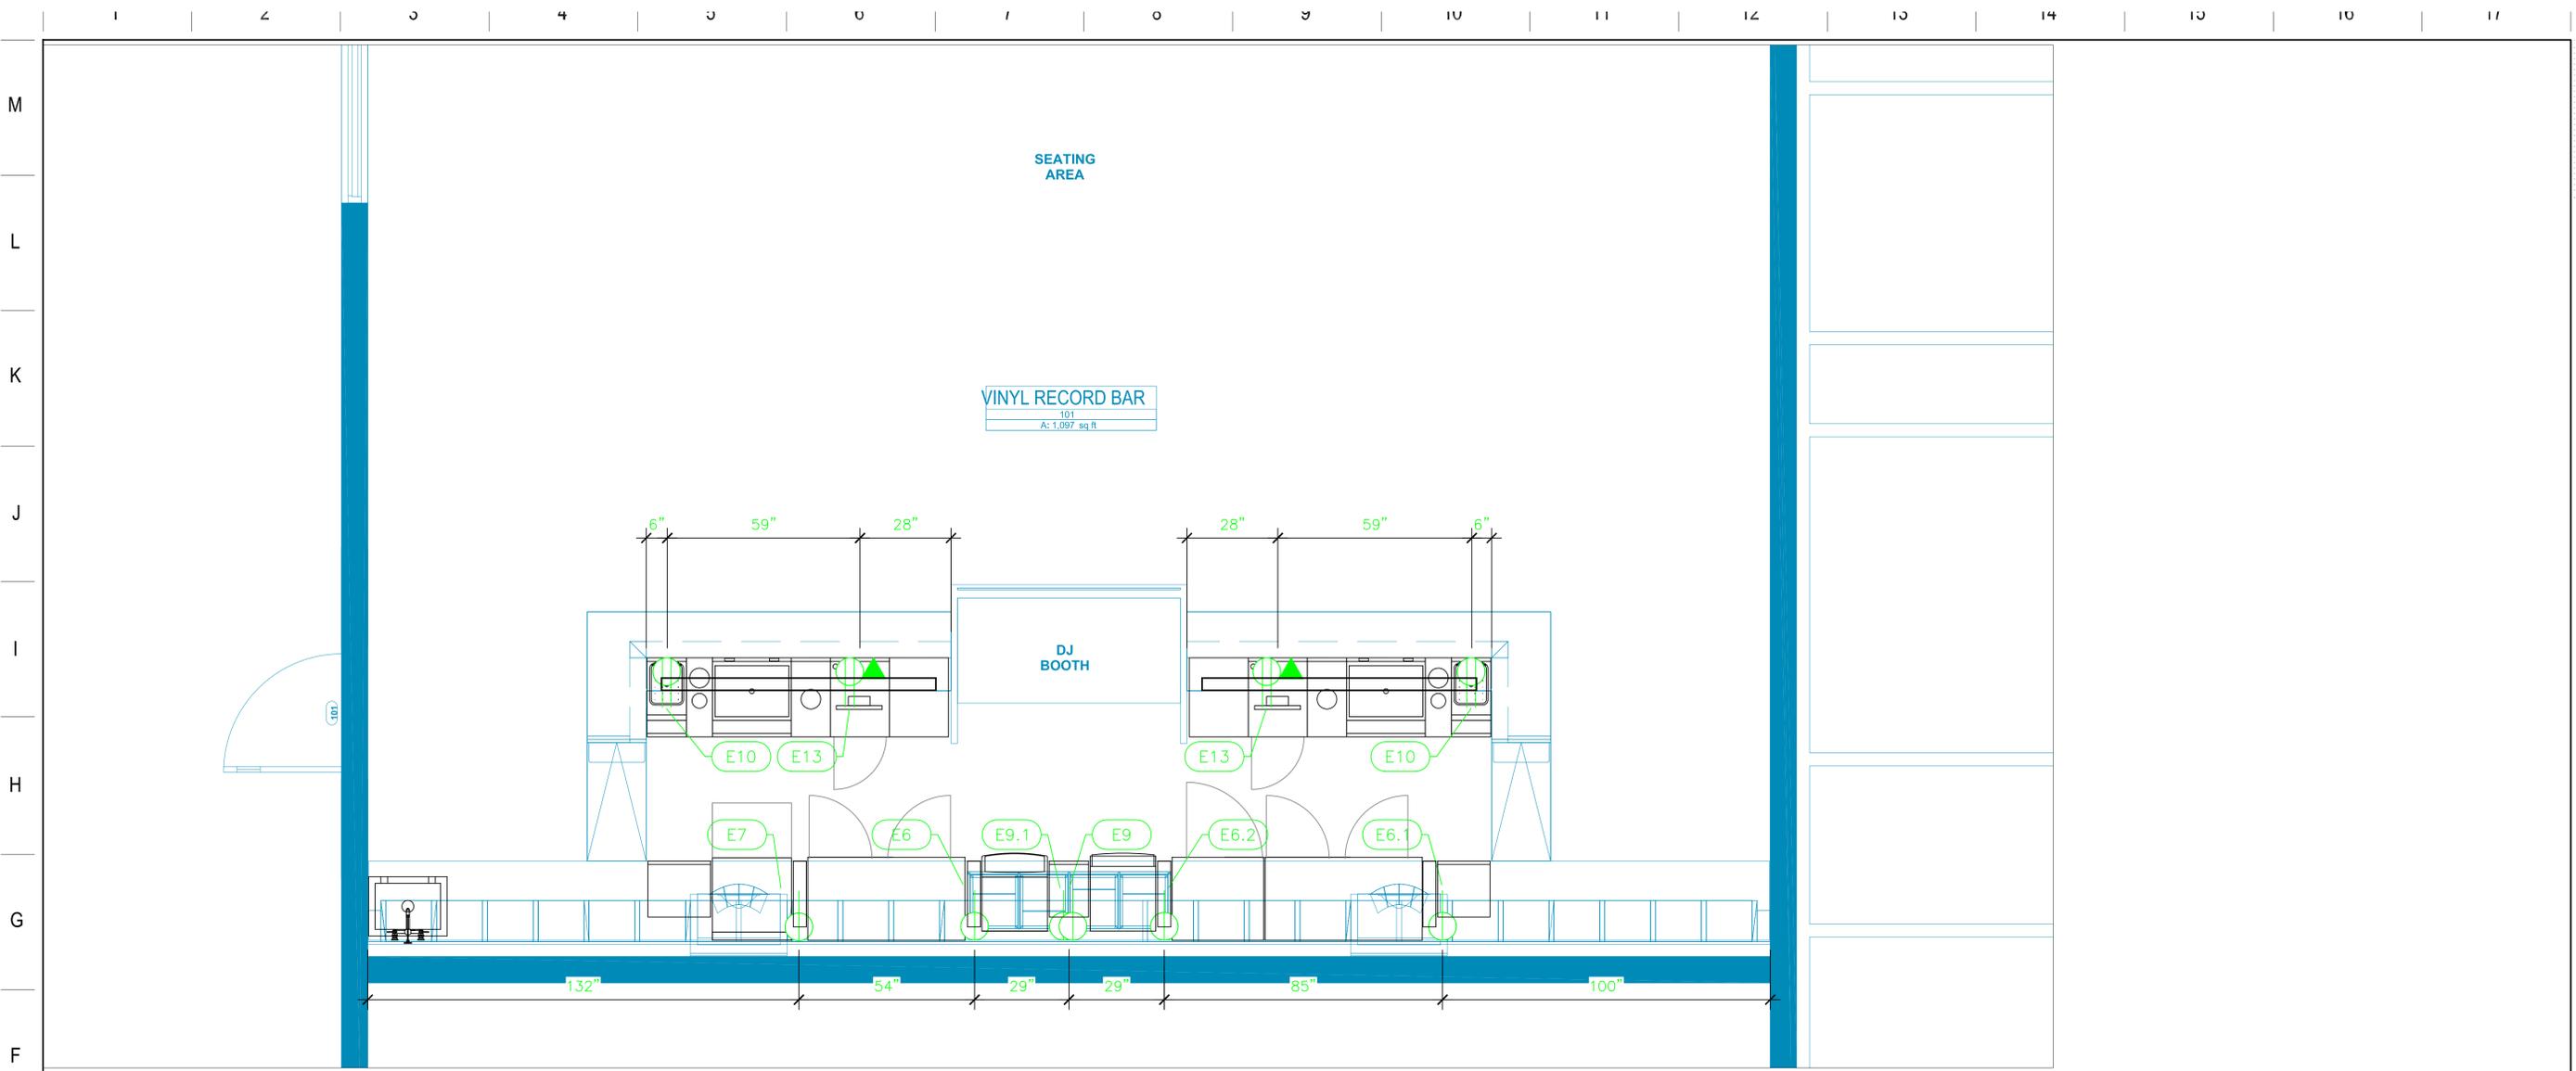


ELECTRICAL SCHEDULE

| ItemNo | Category | Voltage | Cycle | Phase | Amps | Hp | NEMA | ConnectionType | Rough-In AFF | Quantity | Electrical Remarks |
|--------|--------------------------------|---------|-------|-------|------|-----|-------|----------------|--------------|----------|---------------------------------|
| 6 | Back Bar Cabinet, Refrigerated | 120 | 60 | 1 | 2.75 | 1/8 | 5-15P | Simplex | 18" | 1 | |
| 6.1 | Back Bar Cabinet, Refrigerated | 120 | 60 | 1 | 2.75 | 1/8 | 5-15P | Simplex | 18" | 1 | |
| 6.2 | Glass Froster | 120 | 60 | 1 | 5 | 1/3 | 5-15P | Simplex | 18" | 1 | |
| 7 | Dishwasher, Undercounter | 115 | 60 | 1 | 10 | 1 | | Simplex | 18" | 1 | |
| 9 | Ice Maker with Bin, Cube-Style | 115 | 60 | 1 | 6.4 | | | Simplex | 18" | 1 | |
| 9.1 | Ice Flaker with Bin | 115 | 60 | 1 | | | 5-15P | Simplex | 18" | 1 | |
| 10 | Hand Sink | 115 | 60 | 1 | 15 | | | Duplex | 14" | 2 | |
| 13 | POS System | 115 | 60 | 1 | 15 | | | Duplex | 14" | 2 | Confirm Requirements with Owner |
| | | | | | | | | DATA | 14" | 2 | Confirm Requirements with Owner |

LEGEND -- ELECTRICAL CONNECTIONS

- DUPLEX RECEPT., 15-AMP, 120-VOLT, GROUND TYPE, HORIZONTAL MOUNT
- SIMPLEX RECEPT., 120-VOLT, GROUND TYPE, HORIZONTAL MOUNT
- SPECIAL PURPOSE OUTLET, GROUND TYPE, HORIZONTAL MOUNT
- JUNCTION BOX, DIRECT CONNECTION
- DISCONNECT SWITCH, DIRECT CONNECTION
- FLOOR/CEILING RECEPTACLE AS INDICATED
- (2) Telephone + (2) Data
- FIELD CONNECTIONS
- HARD WIRE CONNECTION POINT AT MACHINE

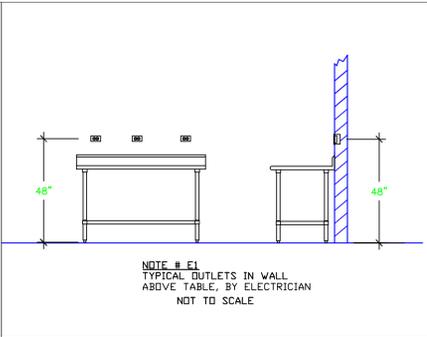

NOTE # E2
ALL NATIONAL, STATE, AND LOCAL CODES SHALL APPLY

NOTE # E3
ALL ELECTRICAL CONNECTIONS AND HARDWARE REQUIRED TO BE PROVIDED BY ELECTRICAL CONTRACTOR

NOTE # E4
ALL JUNCTION BOXES, OUTLETS, ETC. TO BE LOCATED SO AS TO NOT INTERFERE WITH EQUIPMENT

NOTE # E5
ALL RELAYS, CONTRACTORS, STARTERS, AND SWITCHES REQUIRED FOR EXHAUST & SUPPLY FANS TO BE PROVIDED BY ELECTRICAL CONTRACTOR UNLESS SPECIFIED

NOTE # E6
ELECTRICAL CONTRACTOR TO INTERCONNECT DISHWASHER TO EXHAUST FAN FOR DISHWASHER SO THAT THE FAN RUNS WHEN THE DISHWASHER IS IN OPERATION.

NOTE # E7
ELECTRICAL CONTRACTOR TO INSTALL TABLE LIMIT SWITCH TO END OF CLEAN DISHWASHER TO THAT MACHINE STOPS WHEN SWITCH IS DEPRESSED.

NOTE # E8
ELECTRICAL CONTRACTOR TO CONNECT DRAIN LINE HEATER, PAN HEATER AND DOOR HEATER FOR WALK-IN FREEZER.

Equipment ELECTRICAL Service Requirements

All Dimensions to be verified on the job site. Actual locations for floor drains, and any ventilating equipment to be determined by Engineer. Mechanical, Plumbing & Electrical to be checked and verified by Customers MEP Engineer. Remote Condensing Units to be located by Architect. Exhaust & Supply fans to be located by Architect.

ARCHITECT
INTERIOR DESIGNER
LANDSCAPE ARCHITECT

URBAN ROBOT LLC
420 LINCOLN ROAD, S.600
MIAMI BEACH, FL 33139
T: 786.246.4857
F: 786.768.2537
AA0002780, B20001534, LC20000510

OWNER:
DOUG LEVINE
2780 N. BAY ROAD
MIAMI BEACH, FL 33140
O: (786) 977-6322

STRUCTURAL ENGINEER
YHCE ENGINEERING
99 NW 27 AVE
MIAMI, FL 33125
O: (305) 969-YHCE

M.E.P. ENGINEERS:
H. VIDAL & ASSOCIATES
241 NW SOUTH RIVER DR
MIAMI, FL 33128
O: (305) 571-1880

FOOD SERVICE DESIGN
UNI-SOURCE SUPPLY INTL
2055 W 73RD STREET
HALEAH, FL 33016
O: (305) 926-8696 EXT. 111

VINYL RECORD BAR
WYNWOOD

REVISIONS


| REV | DESCRIPTION | DATE |
|-----|-------------|------|
| | | |
| | | |
| | | |
| | | |
| | | |
| | | |

SEAL

URBAN ROBOT LLC
ARCHITECT: B20001534, LC20000510




1926
PROJECT NO:
01/20/2020
DATE
AR & SC / AR & GP
DRAWN / CHECKED
TB

M
L
K
J
I
H
G
F
E
D
C
B
A

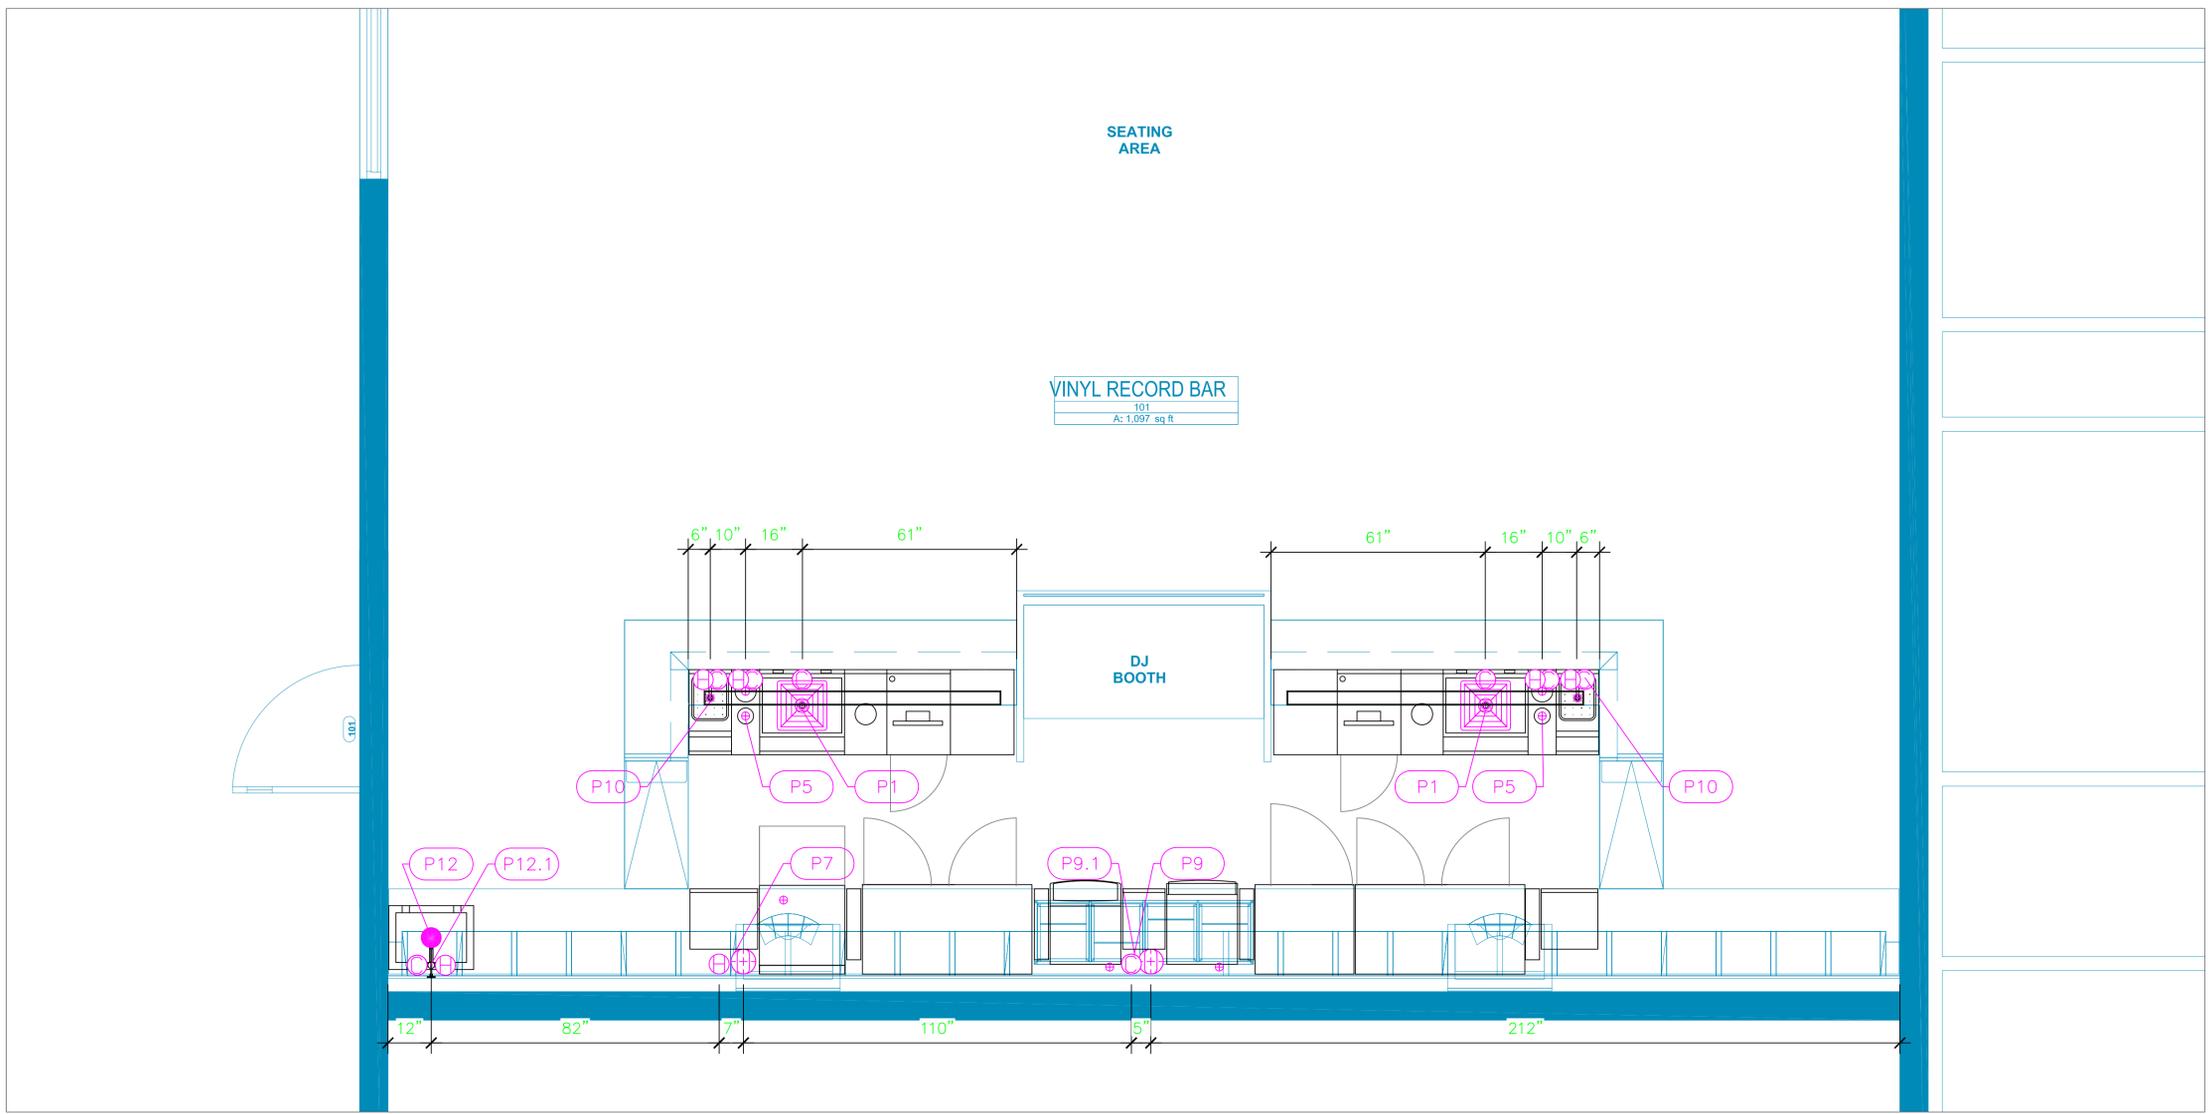

PLUMBING SCHEDULE

| ITEM NO. | DESCRIPTION | COLD WATER SIZE | HOT WATER SIZE | H&C Rough-In | DIRECT WASTE SIZE | DIRECT WASTE AFF | INDIRECT WASTE SIZE | GAS SIZE (IN) | GAS MBTU | QTY | PLUMBING REMARKS |
|----------|--------------------------------|-----------------|----------------|--------------|-------------------|------------------|---------------------|---------------|----------|-----|---|
| 1 | Ice Bin | | | | | | 3/4" | | | 2 | Waste to Floor Sink |
| 5 | Underbar Mixology Sink Unit | 3/8" | 3/8" | 12" | | | 1-1/2" | | | 2 | Waste to Floor Sink |
| | | 3/8" | | 12" | | | | | | 2 | Glass rinser, incoming through cold plate |
| 7 | Dishwasher, Undercounter | | 3/4" | 12" | | | 1-3/8" | | | 1 | Waste to Funnel Floor Drain |
| 9 | Ice Maker with Bin, Cube-Style | 1/4" | | 12" | | | 3/4" | | | 1 | |
| 9.1 | Ice Flaker with Bin | 1/4" | | 12" | | | 3/4" | | | 1 | |
| 10 | Hand Sink | 3/8" | 3/8" | 12" | | | 1-1/2" | | | 2 | Waste to Floor Sink |
| 12 | Mop Sink | | | | 2" | 0" | | | | 1 | |
| 12.1 | Service Faucet | 1/2" | 1/2" | 24" | | | | | | 1 | |

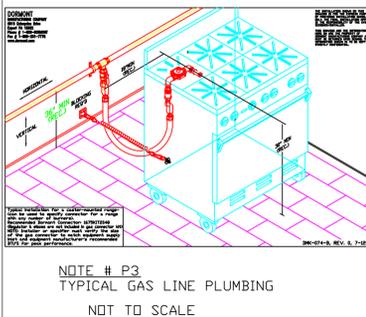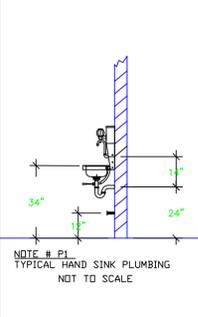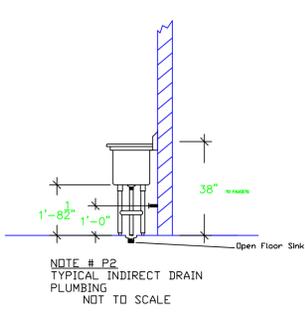

LEGEND -- PLUMBING CONNECTIONS

- HW-HOT WATER, OR CW-COLD WATER
- GAS
- WASTE, DIRECT-CONNECTED
- ⊠ WASTE, INDIRECT to Floor Sink Zurn FD-23
- ⊕ WASTE, INDIRECT to Funnel Floor Drain Jos
- ⊙ FLOOR DRAIN Josam 30000-A3

NOTE # P4
ALL NATIONAL, STATE, AND LOCAL CODES SHALL APPLY

NOTE # P5
ALL PLUMBING CONNECTIONS TO BE EXTENDED AND INTERCONNECTED TO EQUIPMENT AND ALL HARDWARE REQUIRED TO BE PROVIDED BY PLUMBING CONTRACTOR

NOTE # P6
PLUMBING CONTRACTOR TO VERIFY THAT ALL EQUIPMENT IS INSTALLED WITH THE APPROPRIATE GAS PRESSURE AND REGULATORS

NOTE # P7
ALL WASTE LINES AND CONDENSATE LINES TO BE EXTEND FROM EQUIPMENT TO FLOOR DRAINS BY PLUMBING CONTRACTOR.

Equipment PLUMBING Service Requirements

All Dimensions to be verified on the job site. Actual locations for floor drains, and any ventilating equipment to be determined by Engineer. Mechanical, Plumbing & Electrical to be checked and verified by Customers MEP Engineer. Remote Condensing Units to be located by Architect. Exhaust & Supply fans to be located by Architect.

ARCHITECT
INTERIOR DESIGNER
LANDSCAPE ARCHITECT

URBAN ROBOT LLC
420 LINCOLN ROAD, S.601
MIAMI BEACH, FL 33139
T: 786.246.4857
F: 786.768.2537
A4602780, B26001534, LC26000510

OWNER:
DOUG LEVINE
2780 N. BAY ROAD
MIAMI BEACH, FL 33140
O: (786) 977-6322

STRUCTURAL ENGINEER
YHCE ENGINEERING
99 NW 27 AVE
MIAMI, FL 33125
O: (305) 969-YHCE

M.E.P. ENGINEERS:
H. VIDAL & ASSOCIATES
241 NW SOUTH RIVER DR
MIAMI, FL 33128
O: (305) 571-1880

FOOD SERVICE DESIGN
UNI-SOURCE SUPPLY INTL
2055 W 73RD STREET
HALEAH, FL 33016
O: (305) 526-8696 EXT. 111

VINYL RECORD BAR
WYNWOOD

REVISIONS

| REV | DESCRIPTION | DATE |
|-----|-------------|------|
| | | |
| | | |
| | | |
| | | |
| | | |

SEAL



URBAN ROBOT LLC
ARCHITECT: B26001534, LC26000510

1926
PROJECT NO.
01/20/2020
DATE
AR & SC / AR & GP
DRAWN / CHECKED
TB

1 2 3 4 5 6 7 8 9 10 11 12 13 14 15 16 17

1 2 3 4 5 6 7 8 9 10 11 12 13 14 15 16 17

M
L
K
J
I
H
G
F
E
D
C
B
A

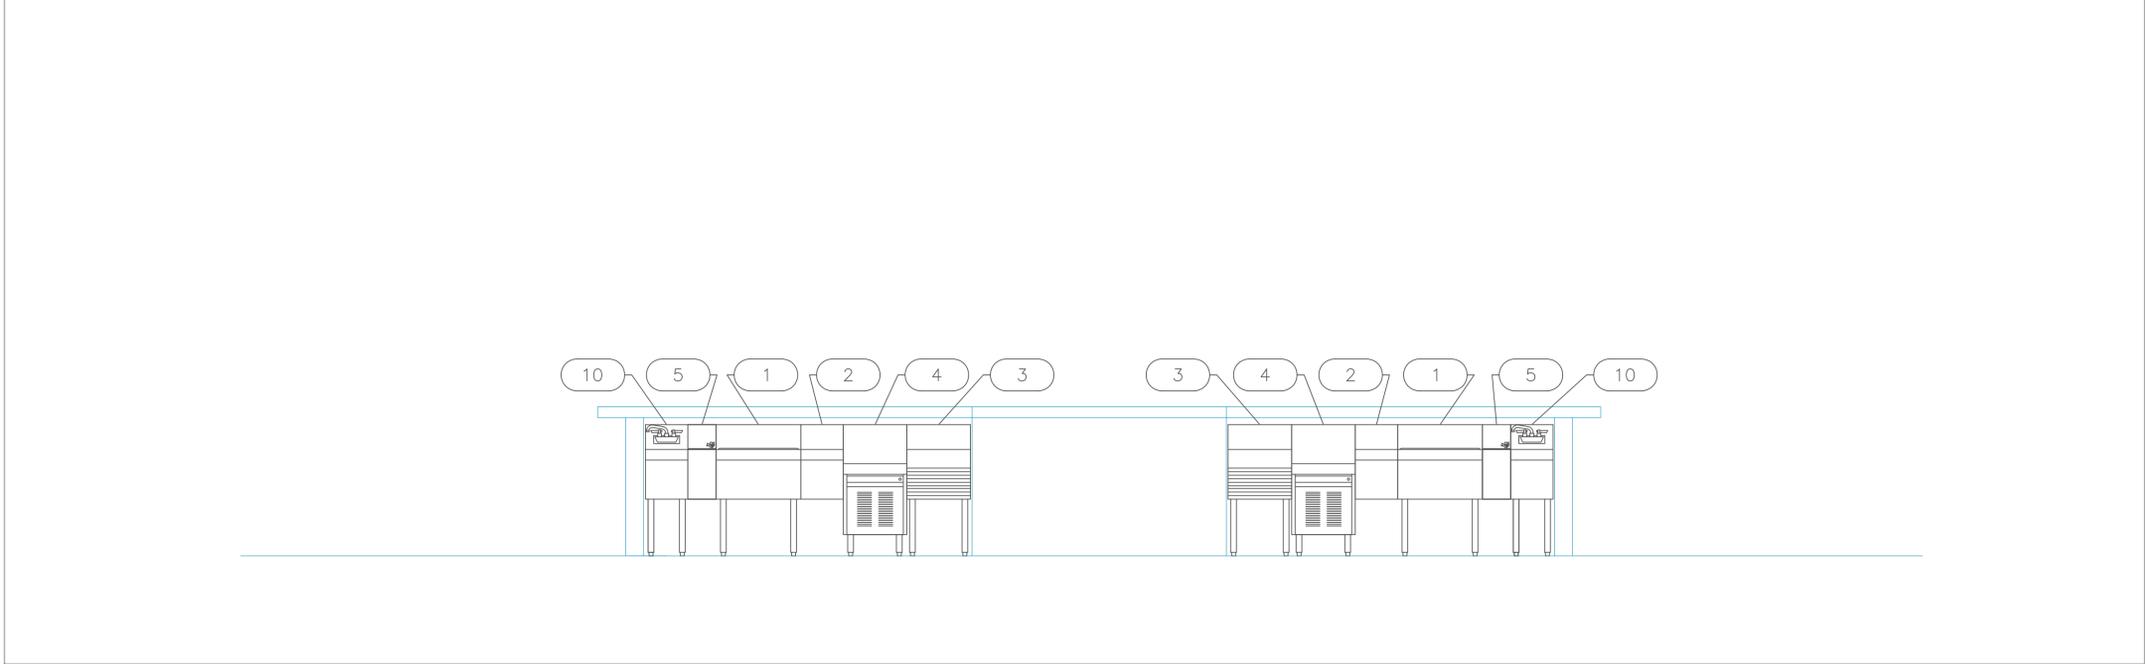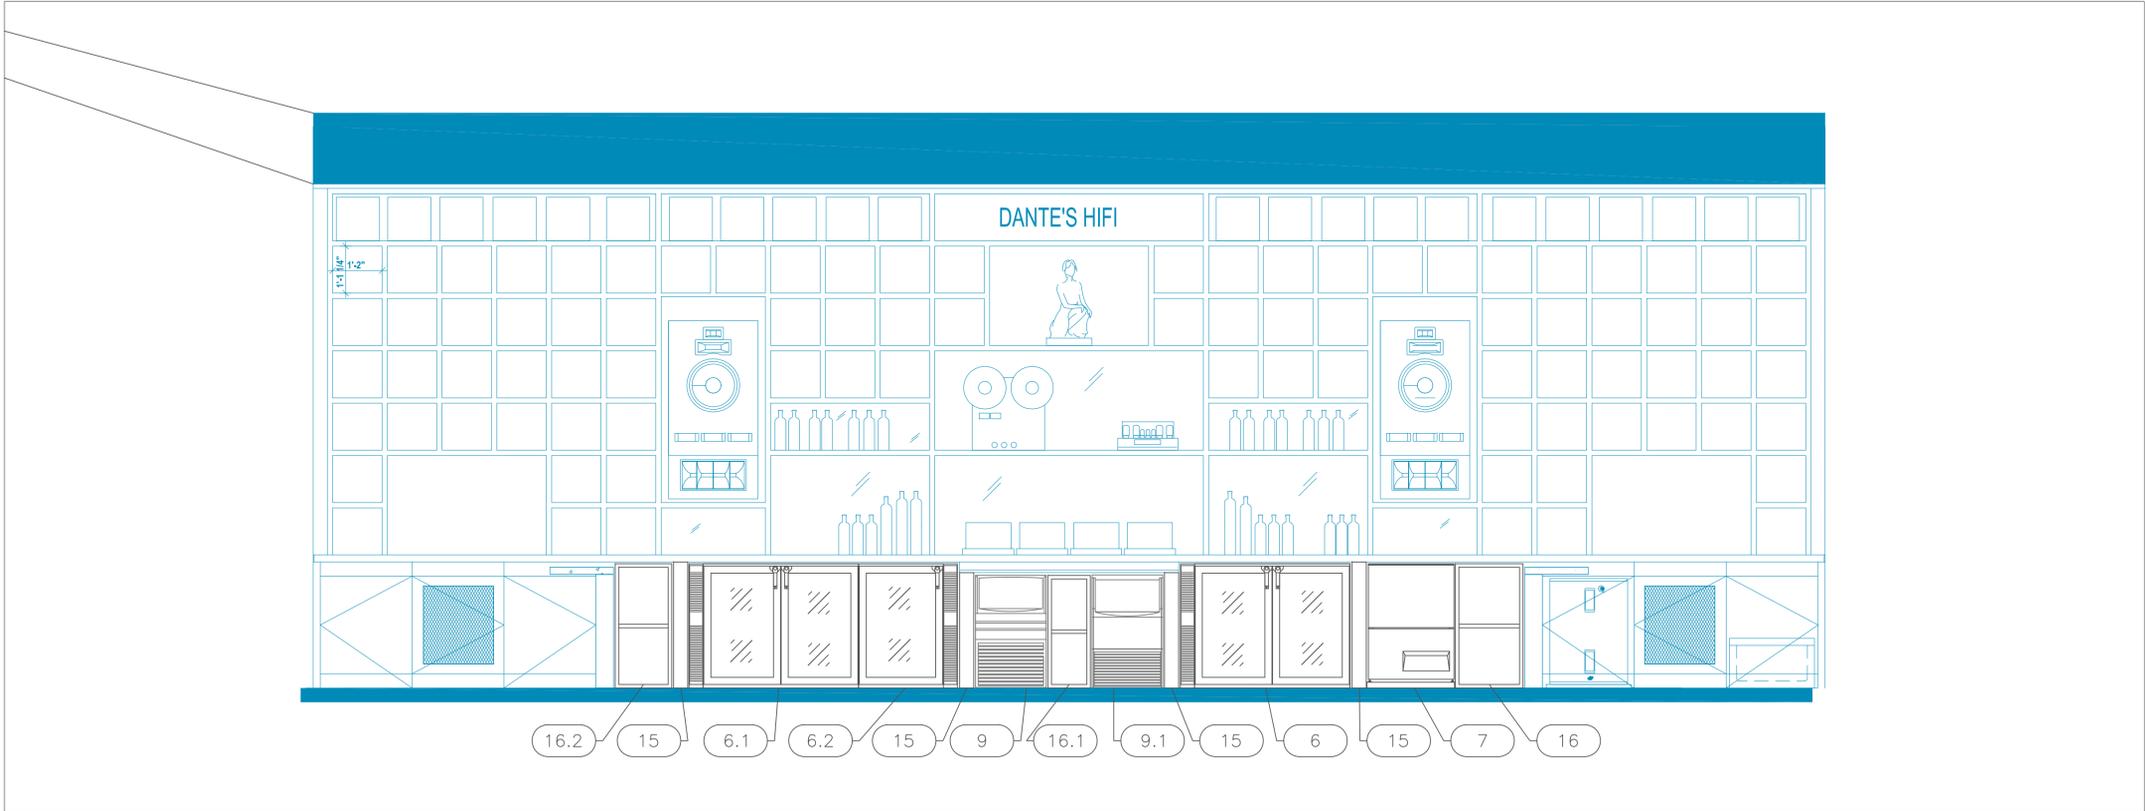

ELEVATIONS

ARCHITECT
INTERIOR DESIGNER
LANDSCAPE ARCHITECT



URBAN ROBOT LLC
420 LINCOLN ROAD, S.601
MIAMI BEACH, FL 33139
T: 786.246.4857
F: 786.768.2537
AA0002780, BE2001534, LC20000510

OWNER:

DOUG LEVINE
2780 N. BAY ROAD
MIAMI BEACH, FL 33140
O: (786) 977-6322

STRUCTURAL ENGINEER:

YHCE ENGINEERING
99 NW 27 AVE
MIAMI, FL 33125
O: (305) 969-YHCE

M.E.P. ENGINEERS:

H. VIDAL & ASSOCIATES
241 NW SOUTH RIVER DR
MIAMI, FL 33128
O: (305) 571-1880

FOOD SERVICE DESIGN:

UNI-SOURCE SUPPLY INTL
2055 W 73RD STREET
HALEAH, FL 33016
O: (305) 526-8696 EXT. 111

VINYL RECORD BAR
WYNWOOD

REVISIONS

| REV | DESCRIPTION | DATE |
|-----|-------------|------|
| | | |
| | | |
| | | |
| | | |
| | | |
| | | |

SEAL

URBAN ROBOT LLC
ARCHITECT: BE2001534, LC20000510

1926
PROJECT NO.

01/20/2020
DATE

AR & SC / AR & GP
DRAWN / CHECKED

TB

1 2 3 4 5 6 7 8 9 10 11 12 13 14 15 16 17