

## OVERVIEW LAYOUT

All Dimensions to be verified on the job site.  
Actual locations for floor drains, and any ventilating equipment to be determined by Engineer.  
Mechanical, Plumbing & Electrical to be checked and verified by Customers MEP Engineer.  
Remote Condensing Units to be located by Architect.  
Exhaust & Supply fans to be located by Architect.

**Soho House**  
**Miami Pool House**  
**Kitchen & Bars**  
**Wynwood, Florida**

SOHO HOUSE



**uni-source**  
SUPPLY

INTERNATIONAL INC.  
2055 W 73rd Street, Miami, FL 33016  
Ph: (305)826-8696 Fax: (305)826-9131

12	Updated backgrounds, underbar equipment custom	7-20-22
13	Elevations, Cooler Shops, Cottage Bar, Hood	8-21-22
14	Added CDB1 "Additional Items"	8-25-22
15	Added Bins For Field Measurements	10-14-22
No.	Revision/Issue	Date

Date  
**Oct 14, 2022**  
Drawn By  
**Dayne Gauntlett**  
Scale  
**3/32" = 1'0"**

Sheet  
**FS-1.0**

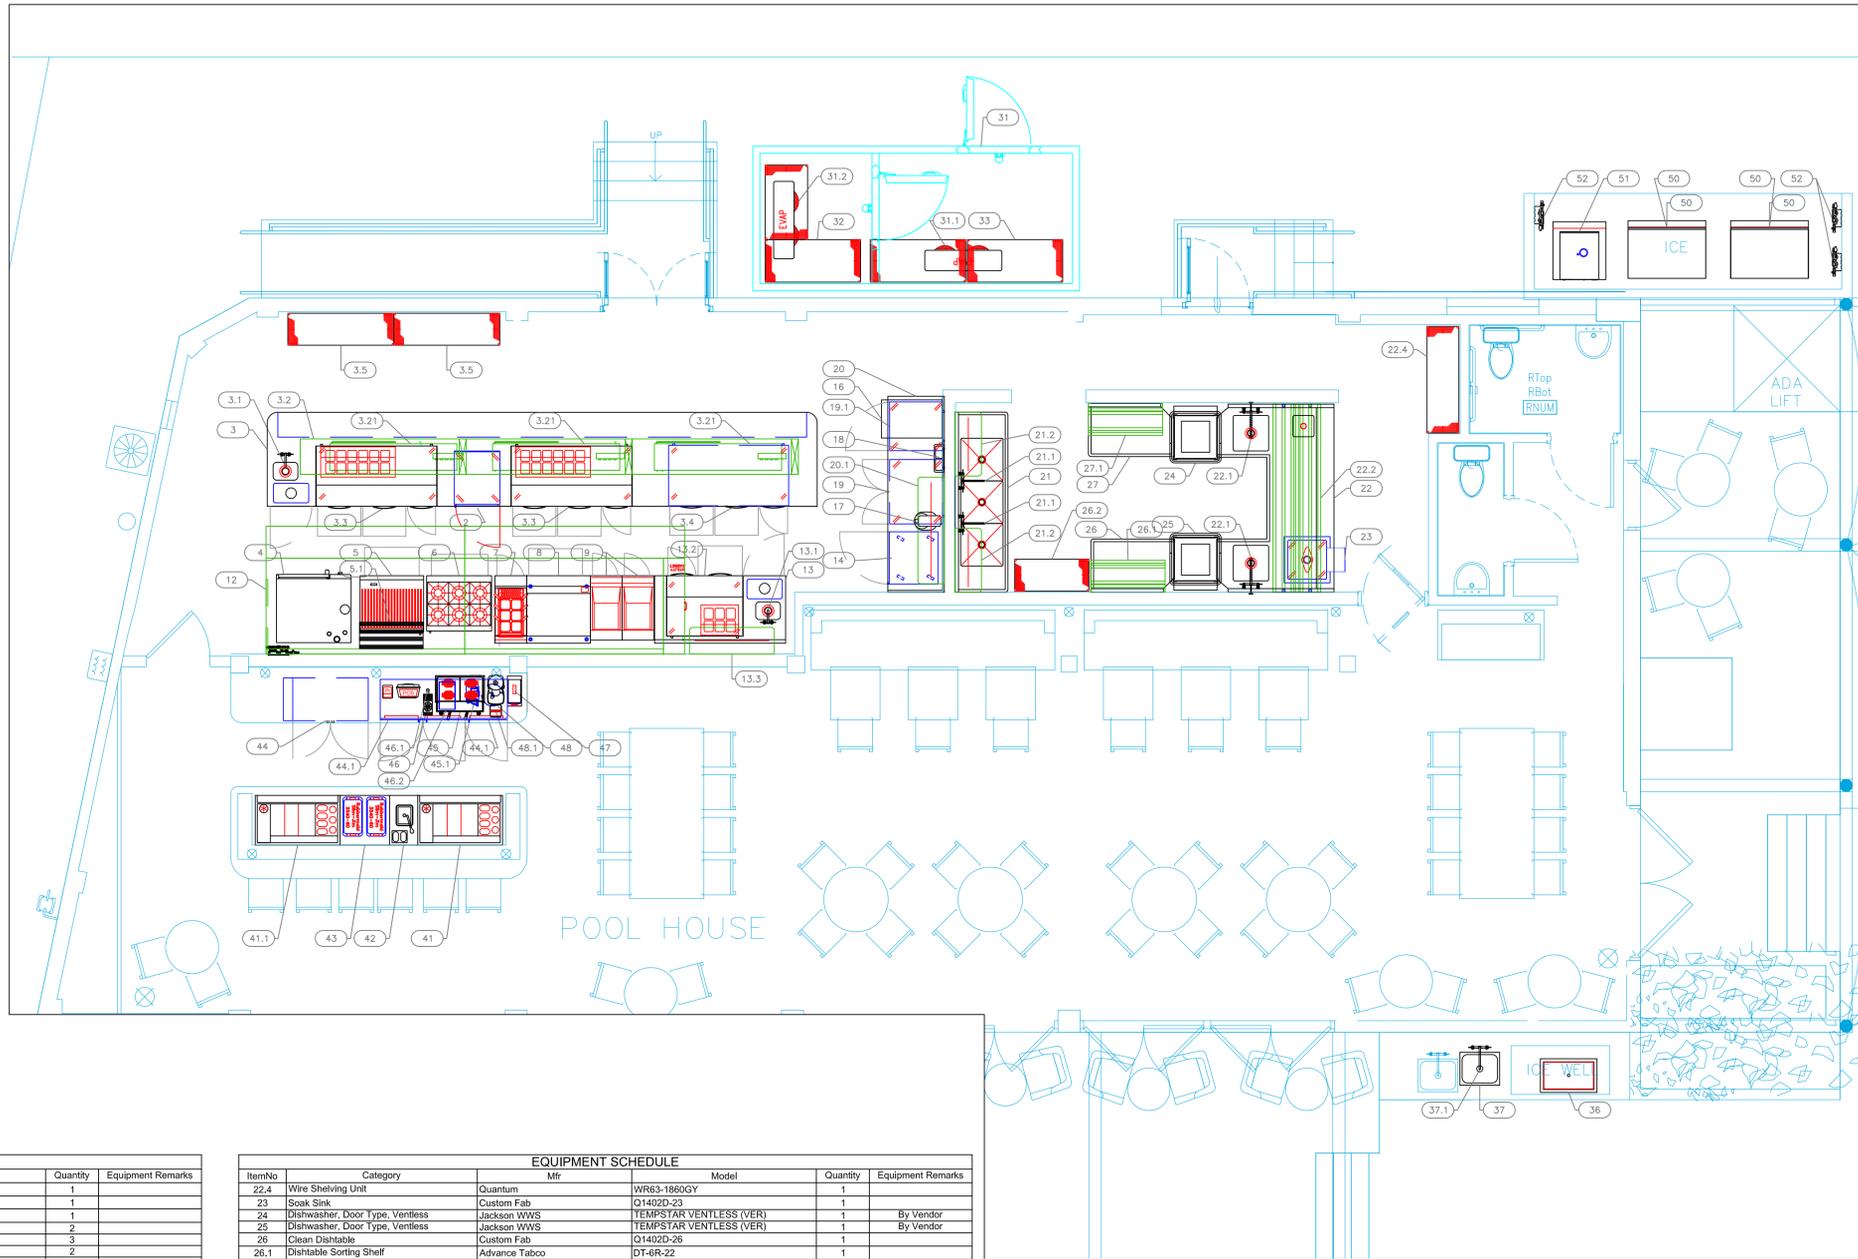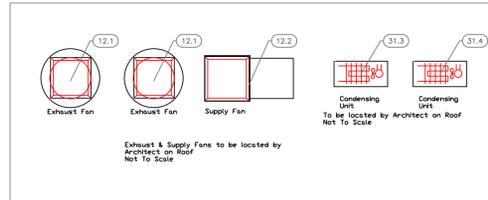

ItemNo	Category	Mfr	Model	Quantity	Equipment Remarks
2	Cabinet, Cook / Hold / Oven	Alto-Shaam	750-TH/II	1	
3	Chiefs Table	Custom Fab	Q1402D-3A	1	
3.1	Deck Mount Faucet	Krowne	15-401L	1	
3.2	Overshelf	Custom Fab	Q1402D-3.2	2	
3.21	Heat Lamp	Hatco	GRAHL-72D3	3	
3.3	Sandwich / Salad Preparation Refrigerator	Continental Refrigerator	RA8BN12-D	2	
3.4	Undercounter Refrigerator	Continental Refrigerator	RA8BN-U-D	1	
3.5	Wire Shelving Unit	Quantum	WR63-1860GY	2	
4	Combi Oven, Gas	Blodgett	BLCT-62-62G	1	
5	Charbroiler, Gas, Countertop	Southbend	HDC-36	1	
5.1	Dishtable Sorting Shelf	Advance Tabco	DT-6R-36	1	
6	Range, 36", 6 Open Burners	Southbend	4361D	1	
	Salamander Broiler, Gas	Southbend	P36-RAD	1	
7	Pasta Cooker, Gas	RositoBisani	CPG1	1	
8	HD Range, 36" Manual Griddle	Jade	JTRH-36C-36	1	By Owner/Operator
8.1	Salamander Broiler, Gas	Southbend	P36-RAD	1	
9	Gas Floor Fryer	Jade	JTF-48-18	2	By Owner/Operator
12	Main Hood	Captive-Aire	HOOD-5424167	1	
12.1	Exhaust Fan	Captive-Aire	AH-DU180HFA-5424167-1/2	2	
12.2	Supply Fan	Captive-Aire	AH-A2-20D-5424167	1	
13	Cabinet with Sink	Custom Fab	Q1402D-13	1	
13.1	Weld-In Sink	Custom Fab		1	
13.1	Deck Mount Faucet	Krowne	15-401L	1	
13.2	Sandwich / Salad Preparation Refrigerator	Continental Refrigerator	RA43NE-D	1	
13.3	Overshelf	Advance Tabco	PS-15-48	1	
14	Blast Chiller/Shock Freezer	American Panel	AP5BCF45-2	1	
16	Soft Serve/Frozen Yogurt Machine	Carpigiani	193 P S/P/A	1	By Owner/Operator
17	Planetary Mixer	Hobart	N50-651	1	By Owner/Operator
18	Dipper Well	Server Products	87740	1	
19	Undercounter Refrigerator	True Mfg. - General Foodservice	TUC-36-LP-HC-SPEC3	1	
19.1	Reach-In Undercounter Freezer	True Mfg. - General Foodservice	TUC-27F-LP-HC-SPEC3	1	
20	Passtry Counter	Custom Fab	Q1402D-20	1	
20.1	Overshelf	Advance Tabco	PS-15-60	1	
21	Three (3) Compartment Sink	Custom Fab	Q1402D-21	1	
21.1	Wall / Splash Mount Faucet	Krowne	DX-812	2	
21.2	Overshelf	Advance Tabco	PS-15-36	1	
22	Soiled Dishable	Custom Fab	Q1402D-22	1	
22.1	Pre-Rinse Faucet Assembly	Krowne	DX-108	1	
22.2	Dishtable Sorting Shelf	Custom Fab	Q1402D-22.2	1	

ItemNo	Category	Mfr	Model	Quantity	Equipment Remarks
22.4	Wire Shelving Unit	Quantum	WR63-1860GY	1	
23	Soak Sink	Custom Fab	Q1402D-23	1	
24	Dishwasher, Door Type, Ventless	Jackson WWS	TEMPSTAR VENTLESS (VER)	1	By Vendor
25	Dishwasher, Door Type, Ventless	Jackson WWS	TEMPSTAR VENTLESS (VER)	1	By Vendor
26	Clean Dishable	Custom Fab	Q1402D-26	1	
26.1	Dishtable Sorting Shelf	Advance Tabco	DT-6R-22	1	
26.2	Wire Shelving Unit	Quantum	WR63-1842GY	1	
27	Clean Dishable	Custom Fab	Q1402D-27	1	
27.1	Dishtable Sorting Shelf	Advance Tabco	DT-6R-22	1	
31	Walk-in	Arctic Industries	WALKIN-183972 V.003	1	
31.1	Evaporator	Arctic Industries	EVAP	1	
31.2	Evaporator	Arctic Industries	EVAP	1	
31.3	Remote Condenser Unit	Arctic Industries	COND	1	
31.4	Remote Condenser Unit	Arctic Industries	COND	1	
32	Wire Shelving Unit	Quantum	WR63-2454GY	1	
33	Wire Shelving Unit	Quantum	WR63-2454GY	2	
36	Drop-In Ice Bin	Custom Fab	DI-IB30	1	
37	Undermount Sink	Custom Fab	Q1402D-37	1	
37.1	Deck Mount Faucet	Krowne	15-812L	1	
41	Underbar Ice Bin / UC Ref	Custom Fab	ICE BIN UC REF - DELI	1	
41.1	Underbar Ice Bin / UC FRE	Custom Fab	ICE BIN UC FRE - DELI	1	
42	Underbar Hand Sink Unit	Custom Fab	HAND SINK	1	
43	Partly Faucet	Krowne	16-306L	1	
43	Trash Cabinet	Custom Fab	TRASH CABINET	1	
44	Back Bar Cabinet, Refrigerated	Glastender	C15848	1	
44.1	Cabinet	Milwork	CABINET	1	By Millwork
45	Espresso Cappuccino Machine	F&O	LINEA-PB-2-AV	1	By Millwork
45.1	Reverse Osmosis System	Everpure	OPS175/5	1	
46	Glass Rinsers, Parts & Accessories	Micro Matic	OP-220D-GR	1	
46.1	Water Dispensing Tower	Marco	1000594	1	
46.2	Hot Water Dispenser	Marco	1000752	1	
47	Coffee Grinder	Nuova Simonelli	MYTHOS-CLIMA-PRO	1	
48	Coffee Grinder	F&O	SUPER JOLLY-A	1	
48.1	Knock Box	F&O	133-1865	1	
50	Ice Maker, Cube-Style	Hoshizaki	IM-500SAB	4	
	Ice Bin for Ice Machines	Hoshizaki	B-700SF	2	
51	Ice Flaker	Hoshizaki	F-1002MAJ	1	
	Ice Bin for Ice Machines	Hoshizaki	B-500SF	1	
52	Water Filtration System, for Ice Machines	Everpure	EV932402	3	

## POOL HOUSE

## EQUIPMENT LAYOUT

All Dimensions to be verified on the job site. Actual locations for floor drains, and any ventilating equipment to be determined by Engineer. Mechanical, Plumbing & Electrical to be checked and verified by Customers MEP Engineer. Remote Condensing Units to be located by Architect. Exhaust & Supply fans to be located by Architect.

**Soho House**  
**Miami Pool House**  
**Kitchen & Bars**  
**Wynwood, Florida**



SOHO HOUSE





INTERNATIONAL INC.

2055 W 73rd Street, Miami, FL 33016  
 Ph: (305)826-8696 Fax: (305)826-9131

12	Updated backgrounds, underbar equipment custom	7-20-22
13	Elevations, Cooler, Shops, Cottage Bar, Hood	8-21-22
14	Added EOB "Additional Items"	8-25-22
15	Added Dims for Field Measurements.	10-14-22
No.	Revision/Issue	Date

Date  
**Oct 14, 2022**  
 Drawn By  
**Dayne Gauntlett**  
 Scale  
**1/4" = 1'0"**

Sheet  
**FS-1.1**

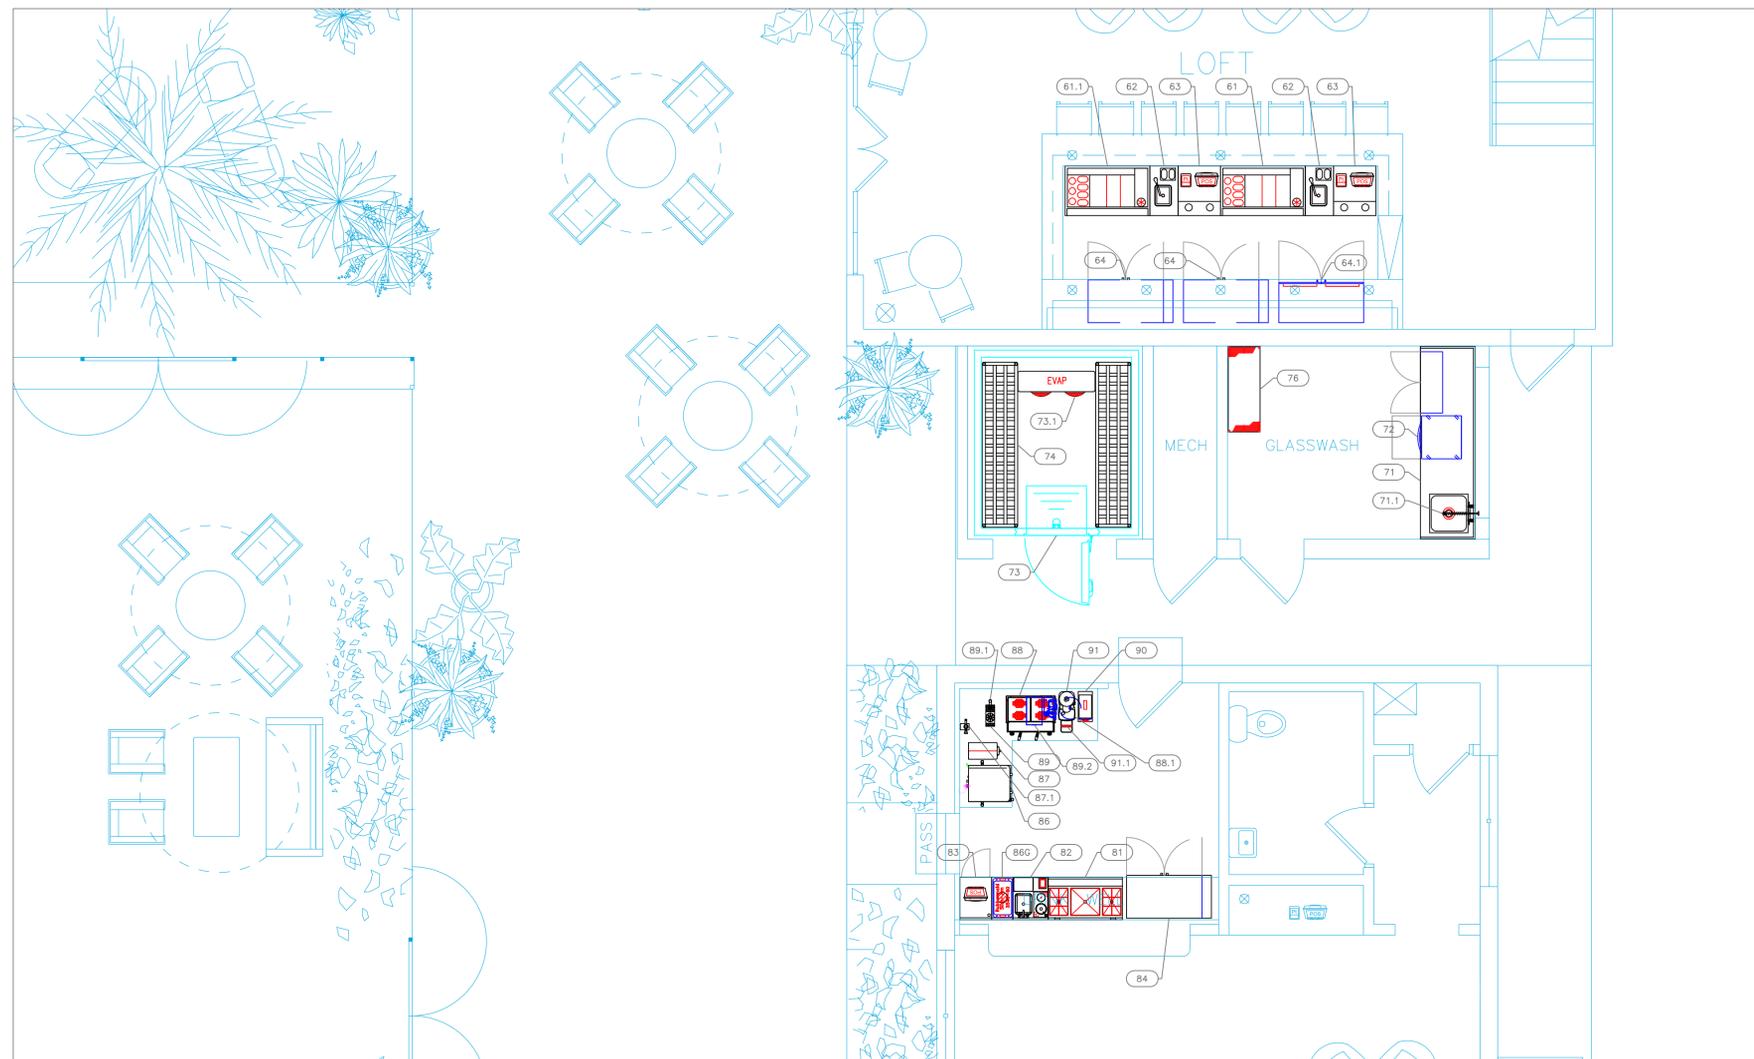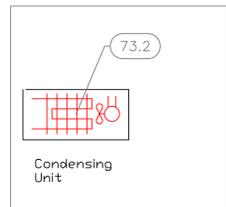

EQUIPMENT SCHEDULE					
ItemNo	Category	Mfr	Model	Quantity	Equipment Remarks
61	Underbar Ice Bin / UC Ref	Custom Fab	ICE BIN UC REF	1	
61.1	Underbar Ice Bin / UC Fre	Custom Fab	ICE BIN UC FRE	1	
62	Underbar Hand Sink Unit	Custom Fab	HAND SINK	2	
	Pantry Faucet	Krowne	16-306L	2	
63	Underbar POS Station	Custom Fab	POS STATION	2	
64	Back Bar Cabinet, Refrigerated	Glastender	C1SB48	2	
64.1	Cabinet	Millwork	CABINET	1	By Millwork
71	Work Table, with Prep Sink(s)	Custom Fab	Q1402D-71	1	
71.1	Pre-Rinse Faucet Assembly	Krowne	DX-108	1	
72	Glasswasher, Undercounter / Underbar	Jackson WWS	DELTA HT-E-SEER	1	By Vendor
74	Keg Storage Rack	Advance Tabco	KR-93-X	2	
73	Walk-in	Arctic Industries	WALKIN-184398 V.001	1	
73.1	Evaporator	Arctic Industries	EVAP	1	
73.2	Remote Condenser Unit	Arctic Industries	COND	1	
76	Wire Shelving Unit	Quantum	WR63-1848GY	1	
81	Ice Bin with Bottle Wells	Glastender	CBA-42	1	
82	Underbar Mixology Sink Unit	Glastender	MFT-20	2	
83	Work Center	Glastender	PCB-18	1	
84	Back Bar Cabinet, Refrigerated	Glastender	C1SL48	1	
86G	Underbar Add-On Unit	Glastender	DWB-12	1	
86	Coffee Tea Brewer	BUNN	52400.0100	1	
87	Coffee Grinder	BUNN	35600.0020	1	
87.1	Water Filtration System, for Coffee Brewers	Everpure	QC71 SINGLE 4FC5-S	1	
88	Espresso Cappuccino Machine	F&O	LINEA-PB-2-AV	1	
88.1	Reverse Osmosis System	Everpure	OPS175/5	1	
89	Glass Rinser, Parts & Accessories	Micro Matic	DP-220D-GR	1	
89.1	Water Dispensing Tower	Marco	1000584	1	
89.2	Hot Water Dispenser	Marco	1000752	1	
90	Coffee Grinder	Nuova Simonelli	MYTHOS-CLIMA-PRO	1	
91	Coffee Grinder	F&O	SUPER JOLLY-A	1	
91.1	Knock Box	FMP	133-1855	1	

## LOFT BAR & COTTAGE BAR

## EQUIPMENT LAYOUT

All Dimensions to be verified on the job site.  
Actual locations for floor drains, and any ventilating equipment to be determined by Engineer.  
Mechanical, Plumbing & Electrical to be checked and verified by Customers MEP Engineer.  
Remote Condensing Units to be located by Architect.  
Exhaust & Supply fans to be located by Architect.

**Soho House**  
**Miami Pool House**  
**Kitchen & Bars**  
**Wynwood, Florida**



SOHO HOUSE



INTERNATIONAL INC.

2055 W 73rd Street, Miami, FL 33016  
Ph: (305)826-8696 Fax: (305)826-9131

No.	Revision/Issue	Date
12	Updated backgrounds, underbar equipment custom	7-20-22
13	Elevations, Cooler Shops, Cottage Bar, Hood	8-21-22
14	Added CDB1 "Additional Items"	8-25-22
15	Added Dims For Field Measurements	10-14-22

Date

Oct 14, 2022

Drawn By

Dayne Gauntlett



Scale

1/4" = 1'0"

Sheet


**FS-1.2**

# POOL HOUSE

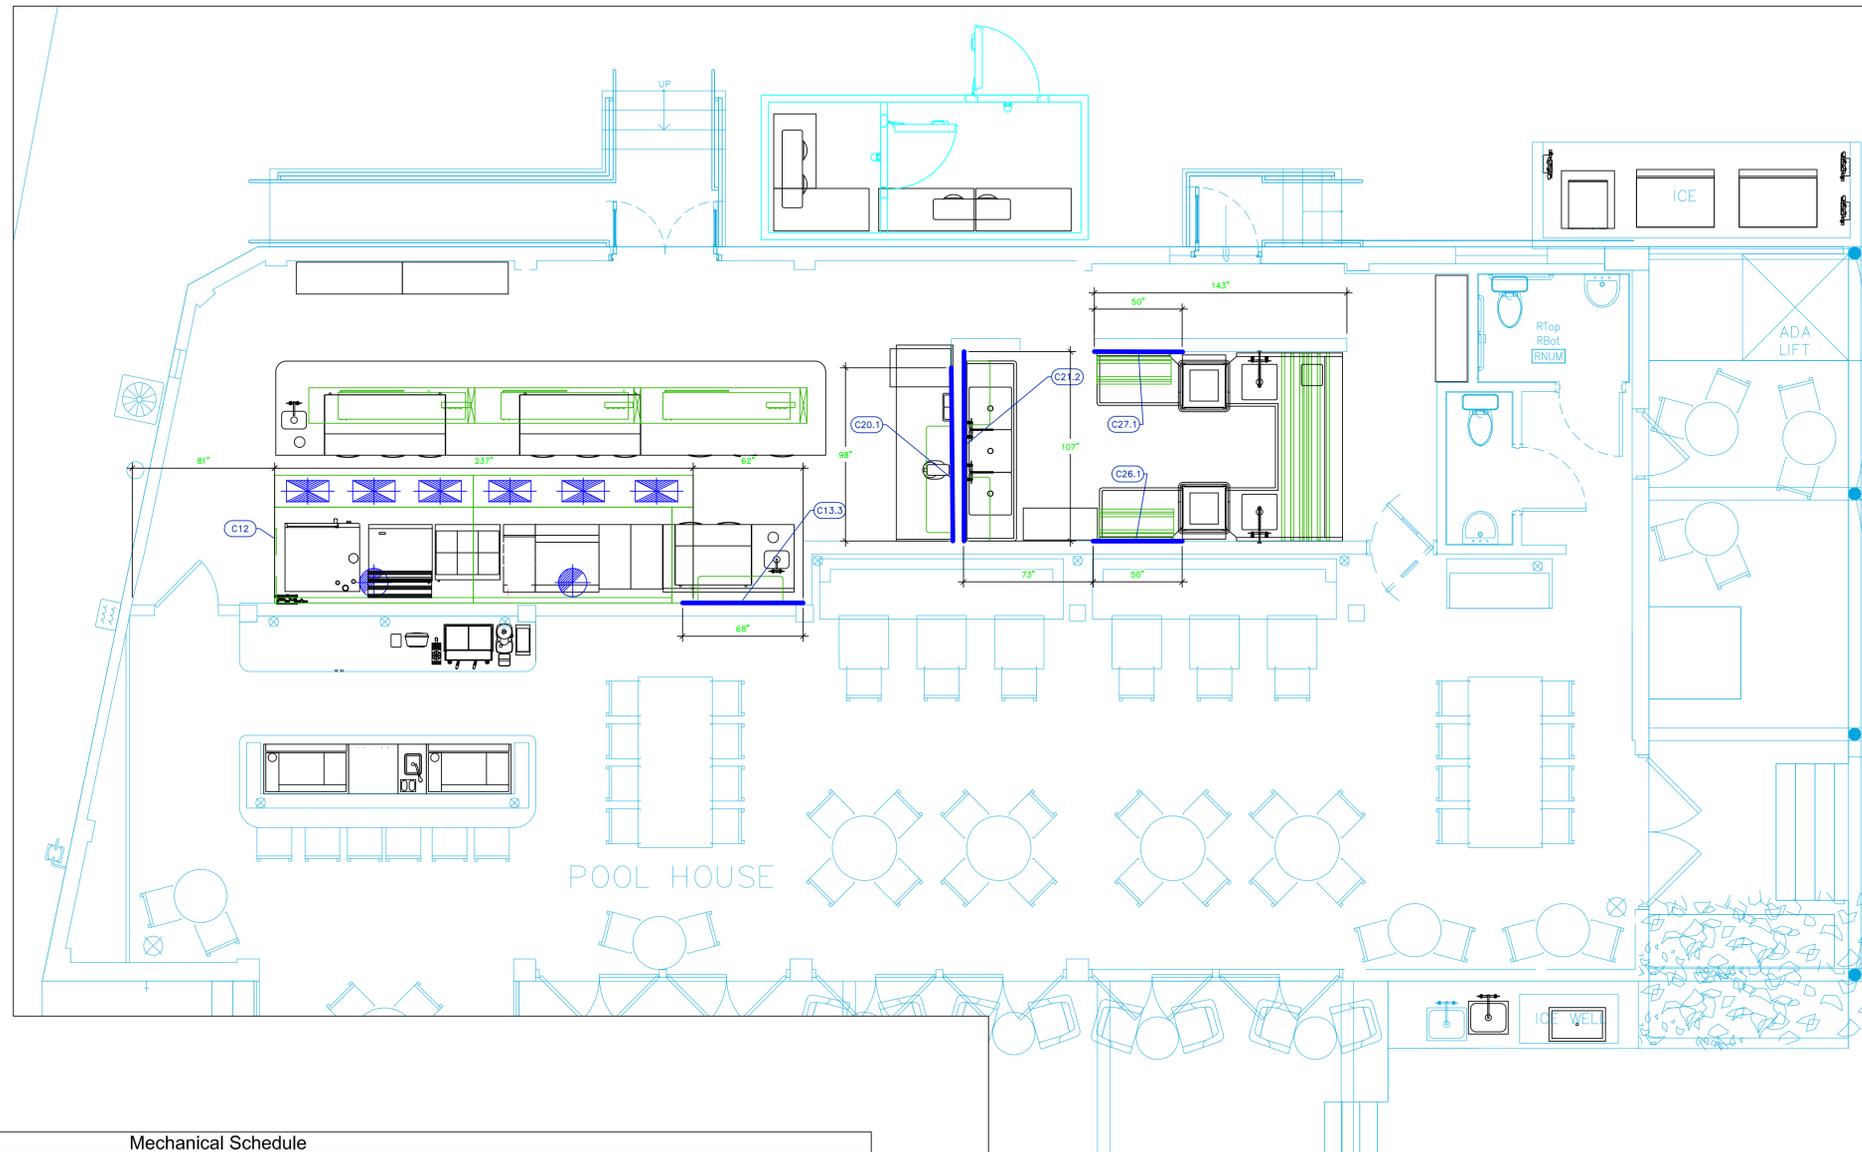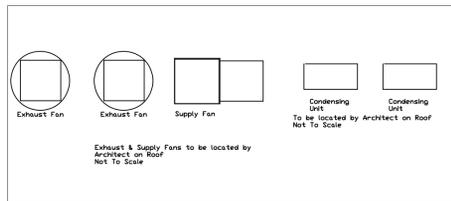

Mechanical Schedule								
ITEM NO.	QTY	DISCRPTION	EXHAUST (L X W)	EXHAUST (CFM)	Makeup Vent Width	SUPPLY (CFM)	Ventilation Remarks	Unit
12	1	Main Hood	(2) 16"dia	5292	(6) 12" x 28"	4234		ea
12.1	2	Exhaust Fan	26" x 26"	2646			Two Exhaust Fans	ea
12.2	1	Supply Fan			29" x 29"	4234		ea
31.1	1	Evaporator					Remote Refrigeration	ea
31.2	1	Evaporator					Remote Refrigeration	ea
31.3	1	Remote Condenser Unit					Remote Refrigeration	ea
31.4	1	Remote Condenser Unit					Remote Refrigeration	ea

- LEGEND -- MECHANICAL**
- EXHAUST DUCT COLLAR
  - SUPPLY DUCT COLLAR
  - INWALL BACKING FOR WALL SHELVES
  - RECESSED FLOOR
  - RAISED EQUIPMENT PAD

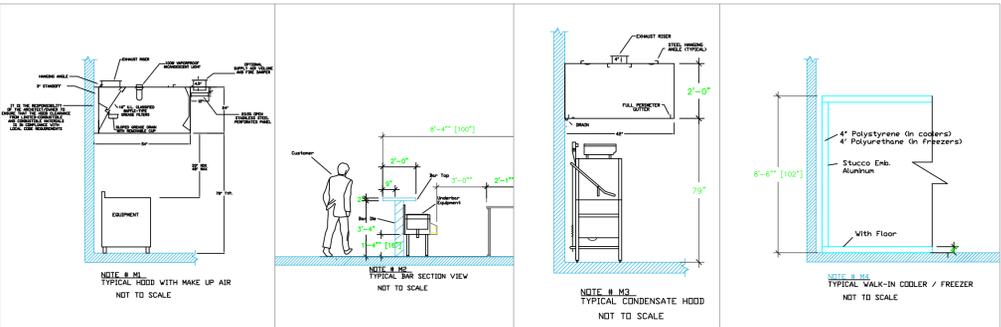

**NOTE # M5**  
ALL NATIONAL, STATE, AND LOCAL CODES SHALL APPLY.

**NOTE # M6**  
ARCHITECT OR ENGINEER TO SIZE AND LOCATE, CONTRACTOR TO PROVIDE ALL OPENINGS FOR DUCTS, PLUMBING LINES, ELECTRICAL LINES, AND REFRIGERATION LINES, AS REQUIRED BY EQUIPMENT.

**NOTE # M7**  
SUPPLY FANS TO BE LOCATED A MINIMUM OF 10' FROM EXHAUST FANS.

**NOTE # M8**  
SHOP DRAWING WILL BE PROVIDED BY MANUFACTURER FOR HOOD, EXHAUST FANS, & SUPPLY FANS, UNCE ORDER IS PLACE WITH.

**NOTE # M9**  
GENERAL CONTRACTOR TO PROVIDE 2" PLYWOOD WALL BACKING FROM 30" TO 78" AFF FOR ALL WALL MOUNTED EQUIPMENT.

**NOTE # M10**  
CEILING HEIGHTS TO BE VERIFIED FOR SUFFICIENT CLARENCE FOR EQUIPMENT.

**NOTE # M11**  
REFRIGERATION CONTRACTOR TO HANG EVAPORATORS FOR WALK-IN, RUN & CHARGE LINES BETWEEN EVAP. & CONDENSING UNIT.

## Equipment MECHANICAL Service Requirements

All Dimensions to be verified on the job site. Actual locations for floor drains, and any ventilating equipment to be determined by Engineer. Mechanical, Plumbing & Electrical to be checked and verified by Customers MEP Engineer. Remote Condensing Units to be located by Architect. Exhaust & Supply Fans to be located by Architect.

**Soho House**  
**Miami Pool House**  
**Kitchen & Bars**  
**Wynwood, Florida**



2055 W 73rd Street, Miami, FL 33016  
Ph:(305)826-8696 Fax:(305)826-9131

No.	Revision/Issue	Date
12	Updated backgrounds, underbar equipment custom	7-20-22
13	Elevations, Cooler Shops, Cottage Bar, Hood	8-21-22
14	Added COB1 "Additional Items"	8-25-22
15	Added Dims For Field Measurements	10-14-22

Date  
**Oct 14, 2022**  
Drawn By  
**Dayne Gauntlett**  
Scale  
**1/4" = 1'0"**

Sheet  
**FS-2.1**

**Soho House  
Miami Pool House  
Kitchen & Bars  
Wynwood, Florida**





2055 W 73rd Street, Miami, FL 33016  
Ph: (305) 826-8696 Fax: (305) 826-9131

12	Updated backgrounds, underbar equipment custom	7-20-22
13	Elevations, Cooler Shops, Cottage Bar, Hood	8-21-22
14	Added CDB1 "Additional Items"	8-25-22
15	Added Dims For Field Measurements	10-14-22
No.	Revision/Issue	Date


Date  
**Oct 14, 2022**  
Drawn By  
**Dayne Gauntlett**  
Scale  
**1/4" = 1'0"**

Sheet  
**FS-2.2**

# LOFT & COTTAGE

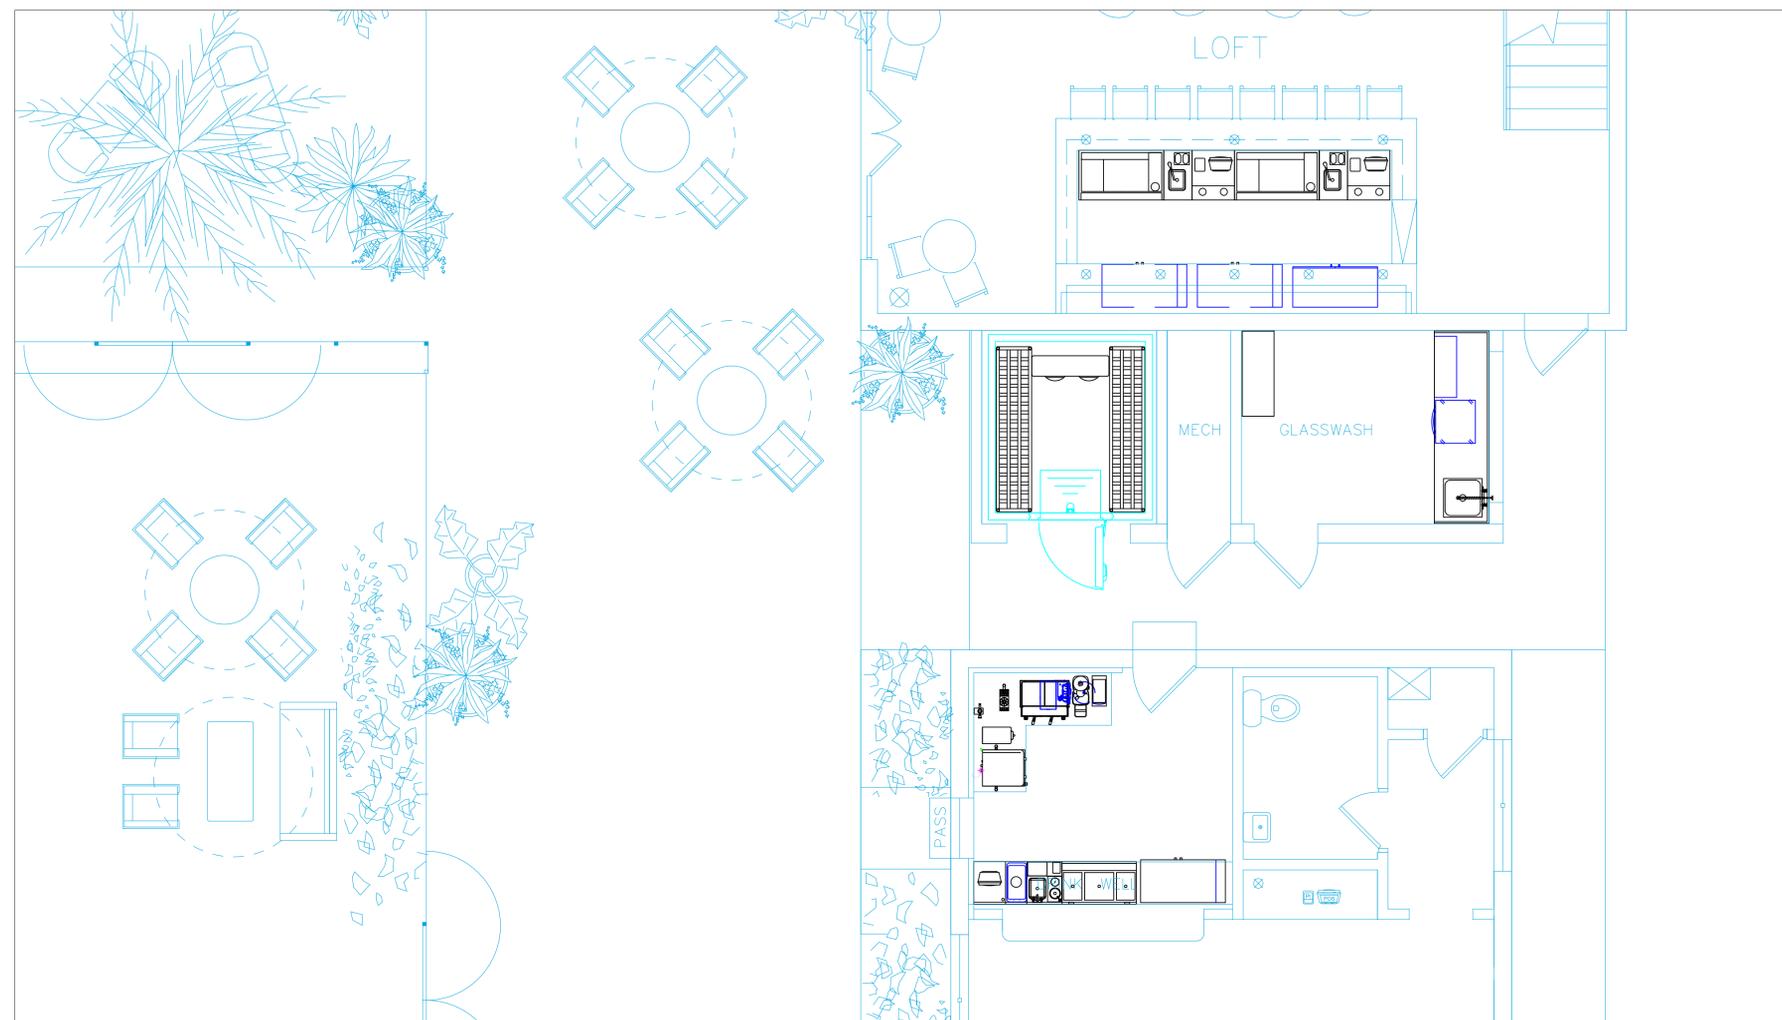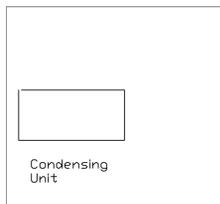

Mechanical Schedule							Unit
ITEM NO.	QTY	DISCRIPTION	EXHAUST (L X W)	EXHAUST (CFM)	Makeup Vent Width	SUPPLY (CFM)	Ventilation Remarks
73.1	1	Evaporator					Remote Refrigeration
73.2	1	Remote Condenser Unit					Remote Refrigeration

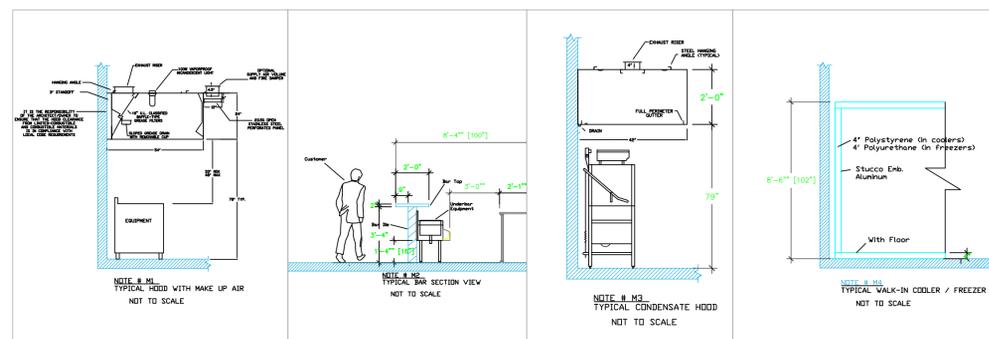

**LEGEND — MECHANICAL**

- EXHAUST DUCT COLLAR
- SUPPLY DUCT COLLAR
- INWALL BACKING FOR WALL SHELVES
- RECESSED FLOOR
- RAISED EQUIPMENT PAD

**NOTE # M5**  
SHOP DRAWING WILL BE PROVIDED BY MANUFACTURER FOR HOOD, EXHAUST FANS, & SUPPLY FANS, UNCE ORDER IS PLACE WITH.

**NOTE # M6**  
ARCHITECT OR ENGINEER TO SIZE AND LOCATE, CONTRACTOR TO PROVIDE ALL OPENINGS FOR DUCTS, PLUMBING LINES, ELECTRICAL LINES, AND REFRIGERATION LINES, AS REQUIRED BY EQUIPMENT.

**NOTE # M7**  
SUPPLY FANS TO BE LOCATED A MINIMUM OF 10' FROM EXHAUST FANS.

**NOTE # M8**  
CEILING HEIGHTS TO BE VERIFIED FOR SUFFICIENT CLEARANCE FOR EQUIPMENT.

**NOTE # M9**  
GENERAL CONTRACTOR TO PROVIDE 2" PLYWOOD WALL BACKING FROM 30" TO 78" AFF FOR ALL WALL MOUNTED EQUIPMENT.



**NOTE # M10**  
CEILING HEIGHTS TO BE VERIFIED FOR SUFFICIENT CLEARANCE FOR EQUIPMENT.

**NOTE # M11**  
REFRIGERATION CONTRACTOR TO HANG EVAPORATORS FOR WALK-IN, RUN & CHARGE LINES BETWEEN EVAP. & CONDENSING UNIT.

## Equipment MECHANICAL Service Requirements

All Dimensions to be verified on the job site. Actual locations for floor drains, and any ventilating equipment to be determined by Engineer.  
Mechanical, Plumbing & Electrical to be checked and verified by Customers MEP Engineer.  
Remote Condensing Units to be located by Architect.  
Exhaust & Supply Fans to be located by Architect.

# POOL HOUSE

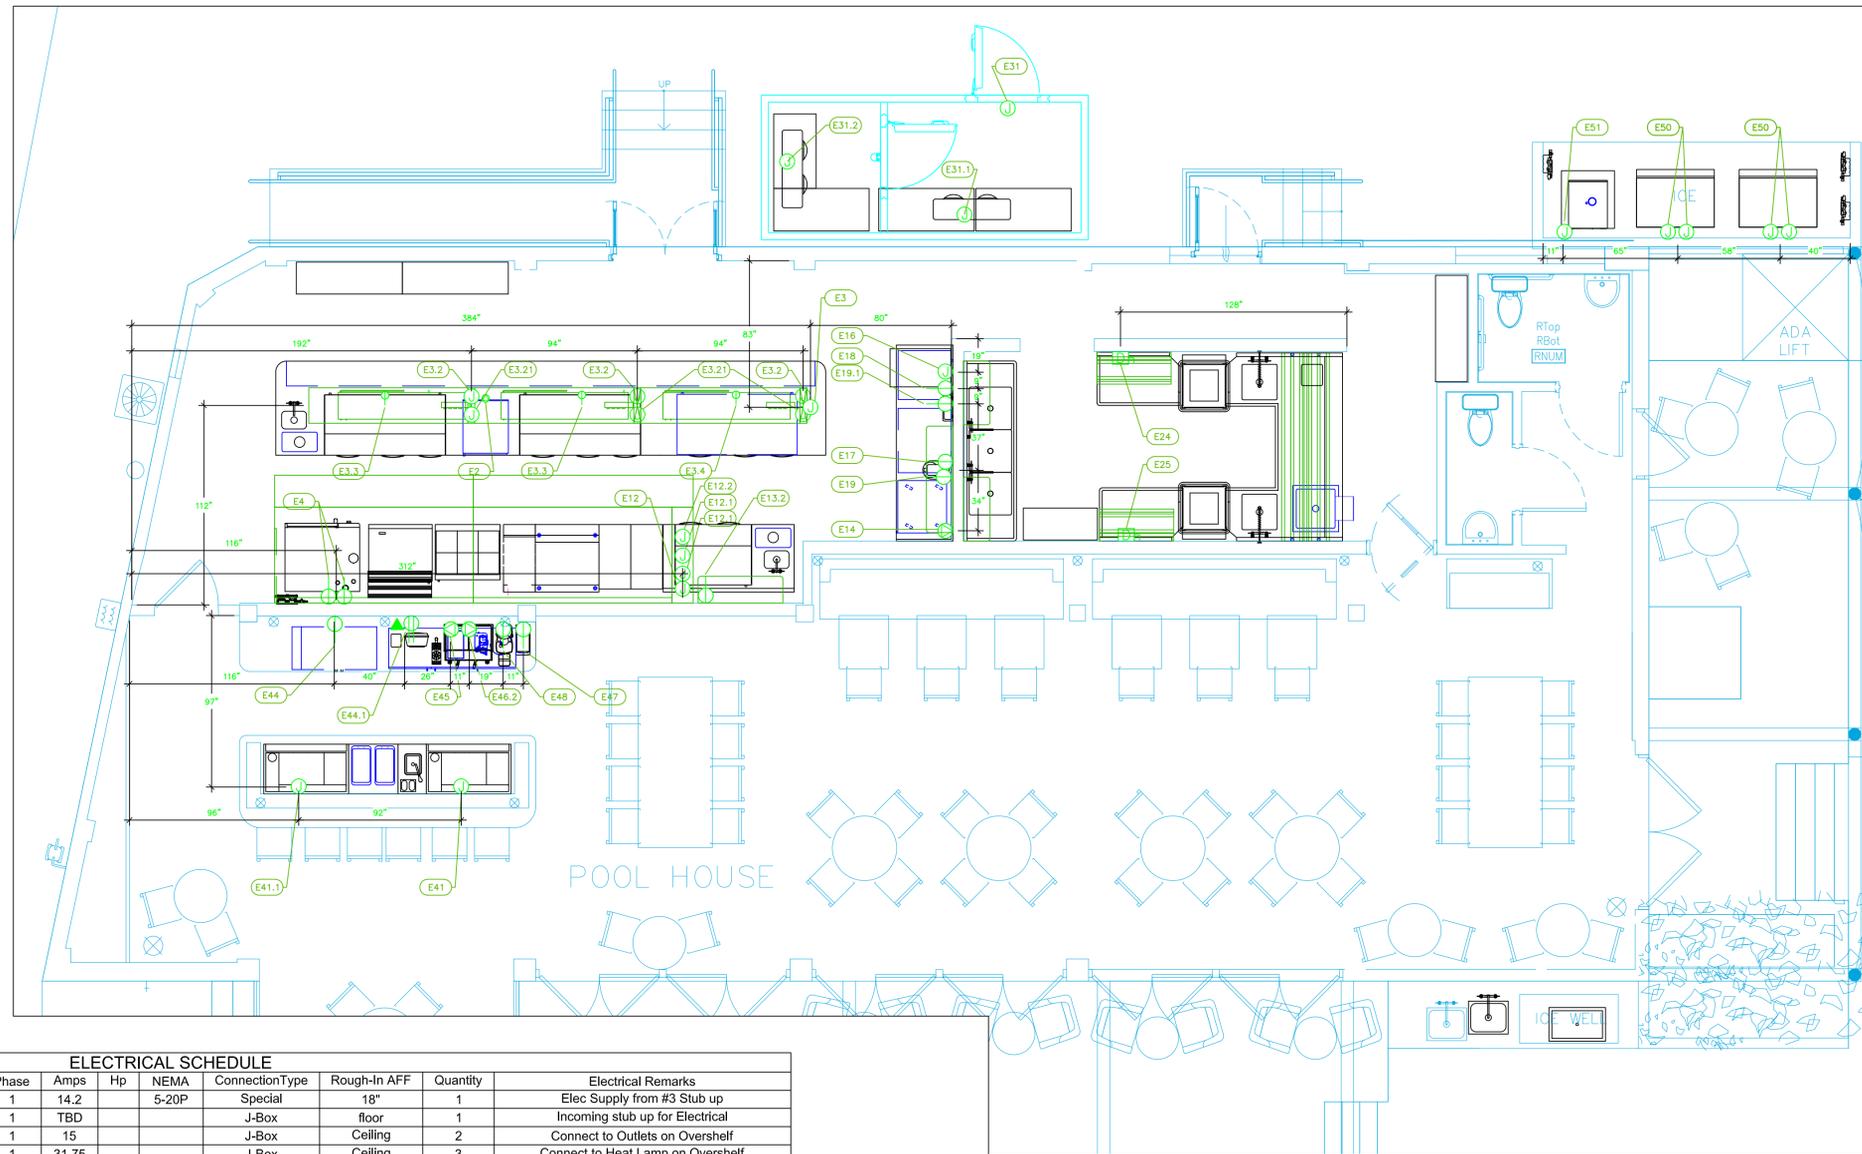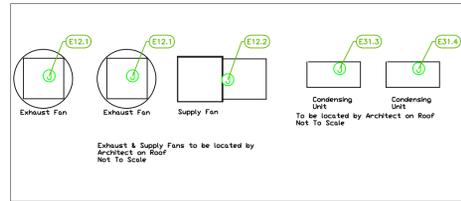


## ELECTRICAL SCHEDULE

ItemNo	Category	Voltage	Cycle	Phase	Amps	Hp	NEMA	ConnectionType	Rough-In AFF	Quantity	Electrical Remarks
2	Cabinet, Cook / Hold / Oven	120	60	1	14.2		5-20P	Special	18"	1	Elec Supply from #3 Stub up
3	Chefs Table	120	60	1	TBD			J-Box	floor	1	Incoming stub up for Electrical
3.2	Overshelf	120	60	1	15			J-Box	Ceiling	2	Connect to Outlets on Overshelf
3.21	Heat Lamp	120	60	1	31.75			J-Box	Ceiling	3	Connect to Heat Lamp on Overshelf
3.3	Sandwich / Salad Preparation Refrigerator	115	60	1	7	1/3	5-15P	Simplex	18"	2	Elec Supply from #3 Stub up
3.4	Undercounter Refrigerator	115	60	1	4.8	1/4	5-15P	Simplex	18"	1	Elec Supply from #3 Stub up
4	Combi Oven, Gas	208/240	60	1	4.0			Simplex	48"	1	Bottom Unit
		208/240	60	1	4.0			Simplex	48"	1	Top Unit
12	Main Hood	115	60	1	15.0			J-Box	108"	1	Elec for Lights in Hood
12.1	Exhaust Fan	208	60	1	20	1.5		J-Box	108"	2	Elec. at Hood Control Box
12.2	Supply Fan	208	60	1	20	3.		J-Box	108"	1	Elec. at Hood Control Box
13.2	Sandwich / Salad Preparation Refrigerator	115	60	1	5.1	1/4	5-15P	Simplex	18"	1	
14	Blast Chiller/Shock Freezer	208	60	1	7	3/4	6-15P	Special	18"	1	6-15P Plug
16	Soft Serve/Frozen Yogurt Machine	208-230	60	1	40			J-Box	48"	1	Review Spec sheet
17	Planetary Mixer	120	60	1	2.9	1/6		Simplex	48"	1	
18	Dipper Well	120	60	1	3.3		5-15P	Simplex	48"	1	
19	Undercounter Refrigerator	115	60	1	2	1/6	5-15P	Simplex	18"	1	
19.1	Reach-In Undercounter Freezer	115	60	1	2.3	1/4	5-15P	Simplex	18"	1	
20	Pastry Counter	115	60	1	15			Duplex	48"	1	Convenience Outlet See note E1
24	Dishwasher, Door Type, Ventless	230	60	1	82.7			Disconnect	18"	1	
25	Dishwasher, Door Type, Ventless	230	60	1	82.7			Disconnect	18"	1	
31	Walk-in	115	60	1	15			J-box	ceiling	1	Elec. for lights in walk-in
31.1	Evaporator	115	60	1	15			J-box	ceiling	1	Interconnect with Condenser
31.2	Evaporator	208	60	1	9.2			J-box	ceiling	1	interconnect with Condenser
31.3	Remote Condenser Unit	208	60	1	15			J-box	18"	1	Location by Architect
31.4	Remote Condenser Unit	208	60	1	15			J-box	18"	1	Location by Architect
41	Underbar Ice Bin / UC Ref	120	60	1	TBD			J-Box	18"	1	Hard Wire
41.1	Underbar Ice Bin / UC FRE	120	60	1	TBD			J-Box	18"	1	Hard Wire
44	Back Bar Cabinet, Refrigerated	120	60	1	2.75	1/8	5-15P	Simplex	18"	1	
44.1	Cabinet	120	60	1	15			Duplex	18"	1	Power for POS
45	Espresso Cappuccino Machine	208-240	60	1	22		6-30P	Special	18"	1	Data for POS
46.2	Water Boiler	230	60	1	24.35		L6-30P	Special	18"	1	6-30P Plug
47	Coffee Grinder	110	60	1	8		5-15P	Simplex	18"	1	
48	Coffee Grinder	110	60	1	2.92			Simplex	18"	1	
50	Ice Maker, Cube-Style	115	60	1	11.5			J-Box	60"	4	

## LEGEND - ELECTRICAL CONNECTIONS

- DUPLEX RECEPT., 15-AMP, 120-VOLT, GROUND TYPE, HORIZONTAL MOUNT
- SIMPLEX RECEPT., 120-VOLT, GROUND TYPE, HORIZONTAL MOUNT
- SPECIAL PURPOSE OUTLET, GROUND TYPE, HORIZONTAL MOUNT
- JUNCTION BOX, DIRECT CONNECTION
- DISCONNECT SWITCH, DIRECT CONNECTION
- FLOOR/CEILING RECEPTACLE AS INDICATED
- (2) Telephone + (2) Data
- FIELD CONNECTIONS
- HARD WIRE CONNECTION POINT AT MACHINE

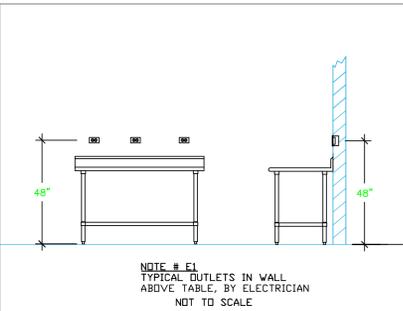

NOTE # E2. ALL NATIONAL, STATE, AND LOCAL CODES SHALL APPLY

NOTE # E3. ALL ELECTRICAL CONNECTIONS AND HARDWARE REQUIRED TO BE PROVIDED BY ELECTRICAL CONTRACTOR

NOTE # E4. ALL JUNCTION BOXES, OUTLETS, ETC. TO BE LOCATED SO AS TO NOT INTERFERE WITH EQUIPMENT

NOTE # E5. ALL RELAYS, CONTRACTORS, STARTERS, AND SWITCHES REQUIRED FOR EXHAUST & SUPPLY FANS TO BE PROVIDED BY ELECTRICAL CONTRACTOR UNLESS SPECIFIED

NOTE # E6. ELECTRICAL CONTRACTOR TO INTERCONNECT DISHMACHINE TO EXHAUST FAN FOR DISHMACHINE SO THAT THE FAN RUNS WHEN THE DISHMACHINE IS IN OPERATION.

NOTE # E7. ELECTRICAL CONTRACTOR TO INSTALL TABLE LIMIT SWITCH TO END OF CLEAN DISHTABLE TO THAT MACHINE STOPS WHEN SWITCH IS DEPRESSED.

NOTE # E8. ELECTRICAL CONTRACTOR TO CONNECT DRAIN LINE HEATER, PAN HEATER AND DODR HEATER FOR WALK-IN FREEZER.

## Equipment ELECTRICAL Service Requirements

All Dimensions to be verified on the job site. Actual locations for floor drains, and any ventilating equipment to be determined by Engineer. Mechanical, Plumbing & Electrical to be checked and verified by Customers MEP Engineer. Remote Condensing Units to be located by Architect. Exhaust & Supply fans to be located by Architect.

**Soho House**  
**Miami Pool House**  
**Kitchen & Bars**  
**Wynwood, Florida**





2055 W 73rd Street, Miami, FL 33016  
 Ph:(305)826-8696 Fax:(305)826-9131

12	Updated backgrounds, underbar equipment custom	7-20-22
13	Elevations, Cooler Shops, Cottage Bar, Hood	8-21-22
14	Added CDB1 "Additional Items"	8-25-22
15	Added Dins for Field Measurements	10-14-22
No.	Revision/Issue	Date

Date  
**Oct 14, 2022**  
 Drawn By  
**Dayne Gauntlett**  
 Scale  
**1/4" = 1'0"**

Sheet  
**FS-3.1**


# LOFT & COTTAGE

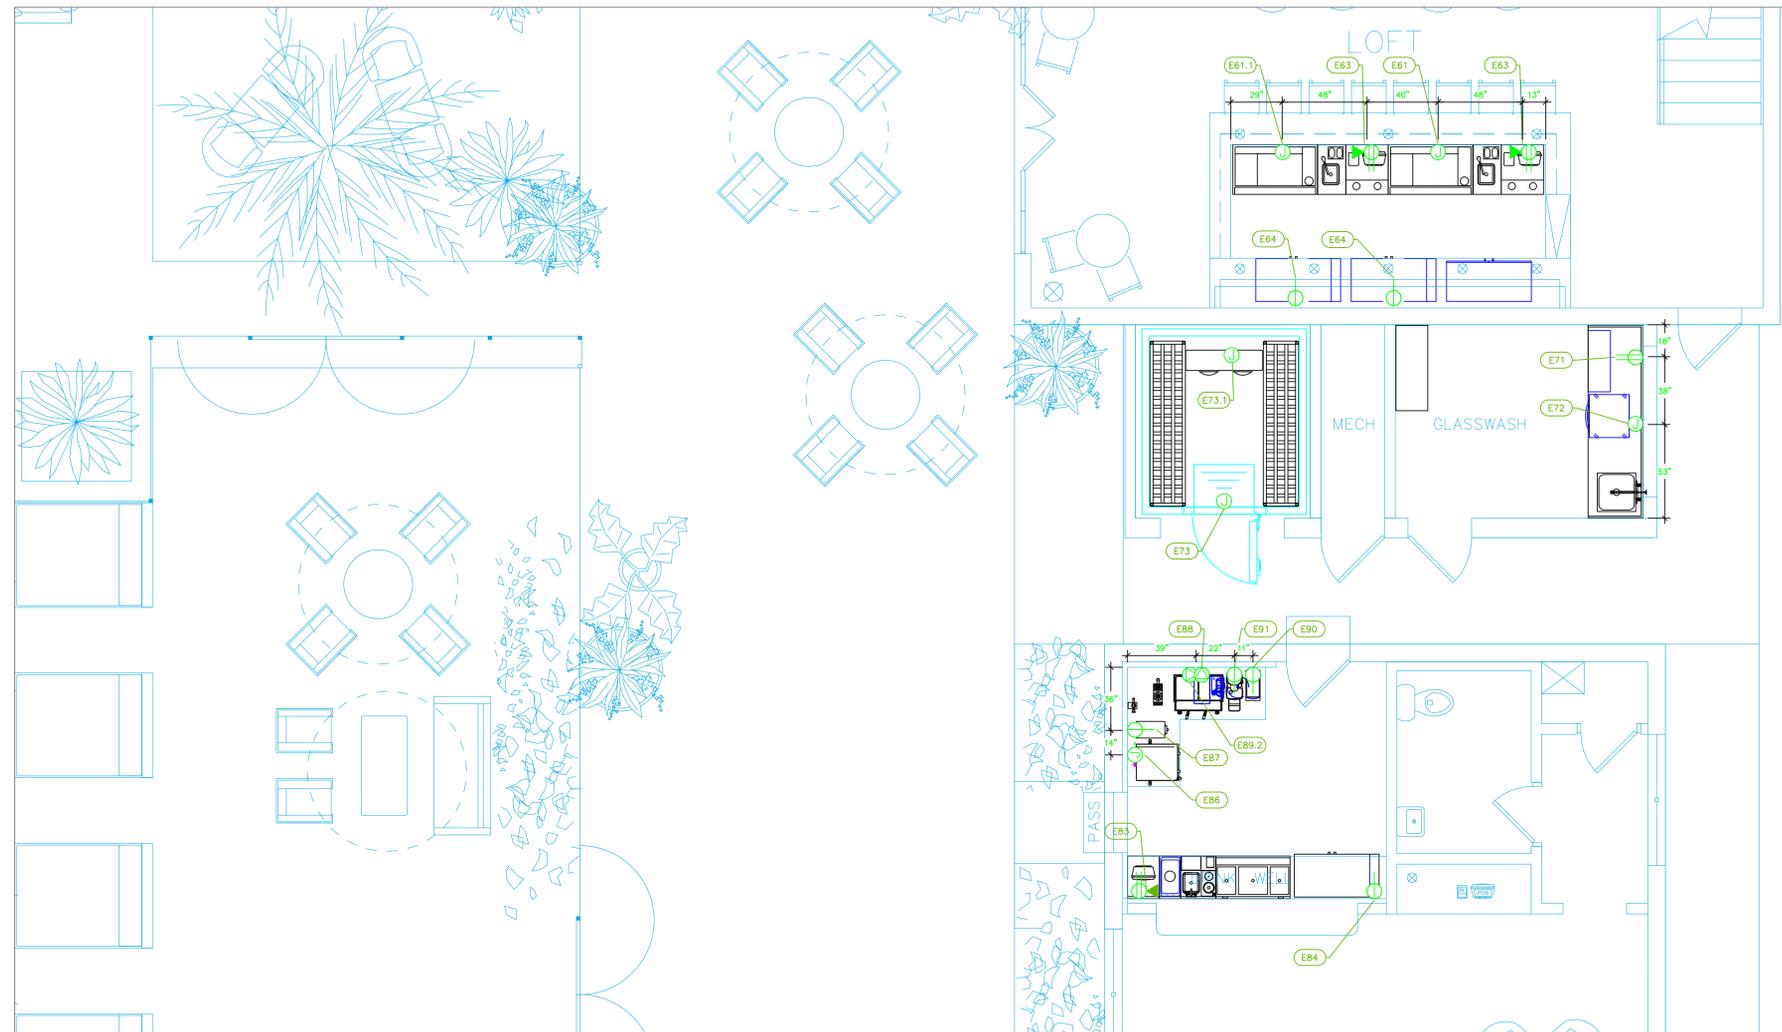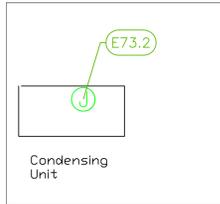

ELECTRICAL SCHEDULE											
ItemNo	Category	Voltage	Cycle	Phase	Amps	Hp	NEMA	ConnectionType	Rough-In AFF	Quantity	Electrical Remarks
51	Ice Flaker	115	60	1	15.2			J-Box	60"	1	
61	Underbar Ice Bin / UC Ref	120	60	1	TBD			J-Box	18"	1	Hard Wire
61.1	Underbar Ice Bin / UC Fre	120	60	1	TBD			J-Box	18"	1	Hard Wire
63	Underbar POS Station	120	60	1	15			Duplex	18"	2	Power for POS
								DATA	18"	2	Data for POS
64	Back Bar Cabinet, Refrigerated	120	60	1	2.75	1/8	5-15P	Simplex	18"	2	
64.1	Cabinet	120	60	1	15			Duplex	18"	1	
71	Work Table, with Prep Sink(s)	120	60	1	15			Duplex	48"	1	Convenience Outlet, See Note E1
72	Glasswasher, Undercounter / Underbar	230	60	1	26.7	1		J-Box	18"	1	
73	Walk-in	115	60	1	15			J-box	ceiling	1	Elec. for lights in walk-in
73.1	Evaporator	115	60	1	15			J-box	ceiling	1	interconnect with Condenser
73.2	Remote Condenser Unit	208	60	1	15			J-box	18"	1	Location by Architect
81	Underbar Ice Bin / UC Ref	120	60	1	TBD			J-Box	18"	1	Hard Wire
83	Underbar POS Station	120	60	1	15			Duplex	18"	1	Power for POS
								DATA	18"	1	Data for POS
84	Back Bar Cabinet, Refrigerated	120	60	1	2.75	1/8	5-15P	Simplex	18"	1	
86	Coffee Tea Brewer	120/240	60	1	25			J-Box	18"	1	
87	Coffee Grinder	120	60	1	11	3/4	5-15P	Simplex	18"	1	
88	Espresso Cappuccino Machine	208-240	60	1	22			Special	18"	1	6-30P Plug
89.2	Water Boiler	230	60	1	24.35			L6-30P	Special	1	L6-30P Plug
90	Coffee Grinder	110	60	1	8			Simplex	18"	1	
91	Coffee Grinder	110	60	1	2.92			Simplex	18"	1	

### LEGEND - ELECTRICAL CONNECTIONS

- DUPLEX RECEPT., 15-AMP, 120-VOLT, GROUND TYPE, HORIZONTAL MOUNT
- SIMPLEX RECEPT., 120-VOLT, GROUND TYPE, HORIZONTAL MOUNT
- SPECIAL PURPOSE OUTLET, GROUND TYPE, HORIZONTAL MOUNT
- JUNCTION BOX, DIRECT CONNECTION
- DISCONNECT SWITCH, DIRECT CONNECTION
- FLOOR/CEILING RECEPTACLE AS INDICATED
- (2) Telephone + (2) Data
- FIELD CONNECTIONS
- HARD WIRE CONNECTION POINT AT MACHINE

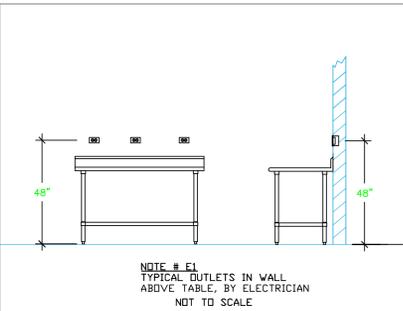

NOTE # E1  
TYPICAL OUTLETS IN WALL  
ABOVE TABLE, BY ELECTRICIAN  
NOT TO SCALE

NOTE # E2  
ALL NATIONAL, STATE, AND LOCAL  
CODES SHALL APPLY

NOTE # E3  
ALL ELECTRICAL CONNECTIONS  
AND HARDWARE REQUIRED TO BE  
PROVIDED BY ELECTRICAL  
CONTRACTOR

NOTE # E4  
ALL JUNCTION BOXES, OUTLETS,  
ETC. TO BE LOCATED SO AS TO  
NOT INTERFERE WITH EQUIPMENT

NOTE # E5  
ALL RELAYS, CONTRACTORS,  
STARTERS, AND SWITCHES  
REQUIRED FOR EXHAUST & SUPPLY  
FANS TO BE PROVIDED BY  
ELECTRICAL CONTRACTOR  
UNLESS SPECIFIED

NOTE # E6  
ELECTRICAL CONTRACTOR TO  
INTERCONNECT DISHMACHINE TO  
EXHAUST FAN FOR DISHMACHINE  
SO THAT THE FAN RUNS WHEN  
THE DISHMACHINE IS IN  
OPERATION.

NOTE # E7  
ELECTRICAL CONTRACTOR TO  
INSTALL TABLE LIMIT SWITCH TO  
END OF CLEAN DISHTABLE TO  
THAT MACHINE STOPS WHEN  
SWITCH IS DEPRESSED.

NOTE # E8  
ELECTRICAL CONTRACTOR TO  
CONNECT DRAIN LINE HEATER,  
PAN HEATER AND DDDR HEATER  
FOR WALK-IN FREEZER.

## Equipment ELECTRICAL Service Requirements

All Dimensions to be verified on the job site.  
Actual locations for floor drains, and any ventilating  
equipment to be determined by Engineer.  
Mechanical, Plumbing & Electrical to be checked and verified  
by Customers MEP Engineer.  
Remote Condensing Units to be located by Architect.  
Exhaust & Supply fans to be located by Architect.

**Soho House**  
**Miami Pool House**  
**Kitchen & Bars**  
**Wynwood, Florida**



SOHO HOUSE



INTERNATIONAL INC.



2055 W 73rd Street, Miami, FL 33016  
Ph:(305)826-8696 Fax:(305)826-9131

12	Updated backgrounds, underbar equipment custom	7-20-22
13	Elevations, Cooler Shops, Cottage Bar, Hood	8-21-22
14	Added CDB1 "Additional Items"	8-25-22
15	Added Dins for Field Measurements	10-14-22
No.	Revision/Issue	Date

Date  
**Oct 14, 2022**  
Drawn By  
**Dayne Gauntlett**  
Scale  
**1/4" = 1'0"**

Sheet  
**FS-3.2**

# POOL HOUSE

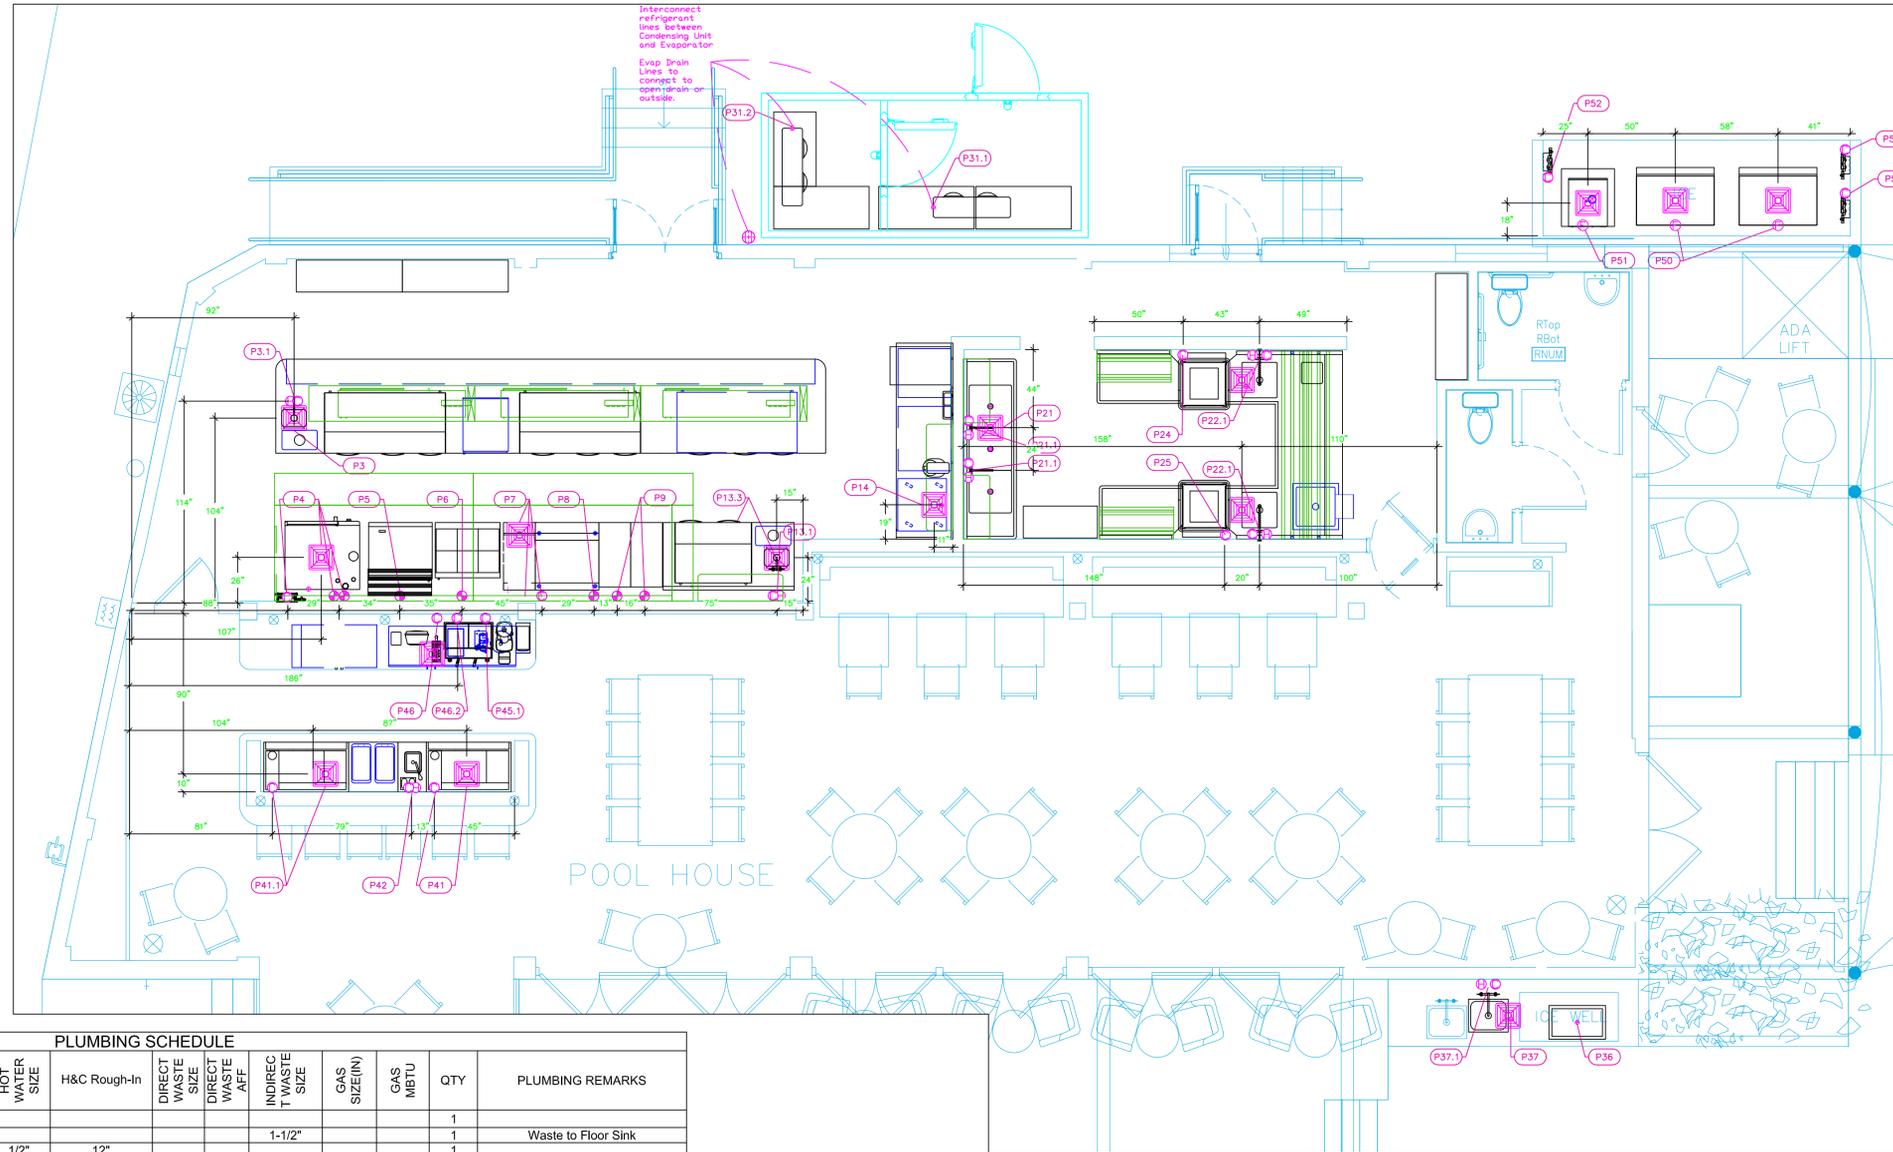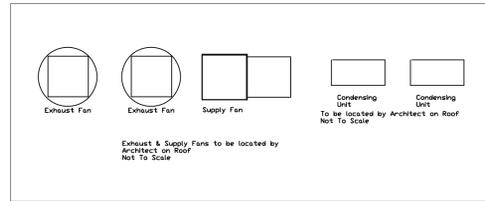

## PLUMBING SCHEDULE

ITEM NO.	DESCRIPTION	COLD WATER SIZE	HOT WATER SIZE	H&C Rough-In	DIRECT WASTE SIZE	DIRECT WASTE AFF	INDIRECT WASTE SIZE	GAS SIZE(IN)	GAS MBTU	QTY	PLUMBING REMARKS
3	Chefs Table									1	
	Weld-in Sink						1-1/2"			1	Waste to Floor Sink
3.1	Deck Mount Faucet	1/2"	1/2"	12"						1	
4	Combi Oven, Gas	3/4"		12"			2"	3/4"	106.5	1	Top Unit, Water through Filter Bottom Unit, Water through Filter
5	Charbroiler, Gas, Countertop						2"	3/4"	106.5	1	
6	Hotplate, Countertop, Gas						2"	3/4"	120.0	1	
7	Pasta Cooker, Gas		1/2"	12"			1-1/4"	1/2"	45.0	1	
8	HD Range, 36" Manual Griddle						2"	3/4"	140.0	1	
9	Gas Floor Fryer						2"	3/4"	122.0	2	
13	Cabinet with Sink						1"			1	Condensate Drain
	Weld-in Sink						1-1/2"			1	Waste to Floor Sink
13.1	Deck Mount Faucet	1/2"	1/2"	12"						1	
14	Blast Chiller/Shock Freezer						1"			1	
21	Three (3) Compartment Sink						(3) 1-1/2"			1	Waste to Floor Sink
21.1	Wall / Splash Mount Faucet	1/2"	1/2"	12"						2	
22	Soiled Dishtable						1-1/2"			1	Waste to Floor Sink
22.1	Pre-Rinse Faucet Assembly	1/2"	1/2"	12"						2	
23	Soak Sink						2"			1	
24	Dishwasher, Door Type, Ventless	3/4"		12"			1-1/2"			1	Waste to Floor Sink
25	Dishwasher, Door Type, Ventless	3/4"		12"			1-1/2"			1	Waste to Floor Sink
31.1	Evaporator						1"			1	Condensate Waste
31.2	Evaporator						1"			1	Condensate Waste
31.3	Remote Condenser Unit									1	interconnect refrig with Evap
31.4	Remote Condenser Unit									1	interconnect refrig with Evap
36	Drop-In Ice Bin						1-1/2"			1	Waste to Floor Sink
37	Undermount Sink						1-1/2"			1	Waste to Floor Sink
37.1	Deck Mount Faucet	1/2"	1/2"	12"						1	
41	Underbar Ice Bin / UC Ref	1/2"		24"			1/2"			1	Waste to Floor Sink
41.1	Underbar Ice Bin / UC FRE	1/2"		24"			1/2"			1	Waste to Floor Sink
42	Underbar Hand Sink Unit						1-1/2"			1	Waste to Floor Sink
44.1	Pantry Faucet	3/8"	3/8"	12"						1	
44.1	Cabinet									1	Floor Sink for Coffee Equipment
45	Espresso Cappuccino Machine	3/8"		n/a						1	Water from Filter
45.1	Reverse Osmosis System	3/8"		12"						1	Water to Coffee Equipment
46	Glass Rinser, Parts & Accessories	1/2"		12"			1/2"			1	Waste to Floor Sink
46.1	Water Dispensing Tower						1/2"			1	Water from Boiler
46.2	Water Boiler	3/8"		12"						1	Water to Dispensing Tower
50	Ice Maker, Cube-Style	1/2"		n/a			3/4"			4	Water from Filter
	Ice Bin for Ice Machines						3/4"			2	Waste to Floor Sink
51	Ice Flaker	1/2"		n/a			3/4"			1	Water from Filter
	Ice Bin for Ice Machines						3/4"			1	Waste to Floor Sink
52	Water Filtration System, for Ice Machines	3/4"		60"			3/4"			3	Water to Ice Machines

### LEGEND -- PLUMBING CONNECTIONS

- HW-HOT WATER, OR CW-COLD WATER
- GAS
- WASTE, DIRECT-CONNECTED
- WASTE, INDIRECT to Floor Sink, or Floor Dr
- FUNNEL FLOOR DRAIN Josam 30000-E3
- FLOOR DRAIN Josam 30000-A3
- FLOOR SINK Zurn FD-2370-pv-P4-F
- FILTERED WATER, at machine.

### NOTE # P4

ALL NATIONAL, STATE, AND LOCAL CODES SHALL APPLY

NOTE # P5  
ALL PLUMBING CONNECTIONS TO BE EXTENDED AND INTERCONNECTED TO EQUIPMENT AND ALL HARDWARE REQUIRED TO BE PROVIDED BY PLUMBING CONTRACTOR

NOTE # P6  
PLUMBING CONTRACTOR TO VERIFY THAT ALL EQUIPMENT IS INSTALLED WITH THE APPROPRIATE GAS PRESSURE AND REGULATORS

NOTE # P7  
ALL WASTE LINES AND CONDENSATE LINES TO BE EXTEND FROM EQUIPMENT TO FLOOR DRAINS BY PLUMBING CONTRACTOR.

## Equipment PLUMBING Service Requirements

All Dimensions to be verified on the job site. Actual locations for floor drains, and any ventilating equipment to be determined by Engineer. Mechanical, Plumbing & Electrical to be checked and verified by Customers MEP Engineer. Remote Condensing Units to be located by Architect. Exhaust & Supply fans to be located by Architect.

**Soho House**  
**Miami Pool House**  
**Kitchen & Bars**  
**Wynwood, Florida**




2055 W 73rd Street, Miami, FL 33016  
Ph:(305)826-8696 Fax:(305)826-9131


No.	Revision/Issue	Date
12	Updated backgrounds, underbar equipment custom	7-20-22
13	Elevations, Cooler Shops, Cottage Bar, Hood	8-21-22
14	Added COBI "Additional Items"	8-25-22
15	Added Dins for Field Measurements	10-14-22

Date  
**Oct 14, 2022**  
Drawn By  
**Dayne Gauntlett**  
Scale  
**1/4" = 1'0"**




Sheet  
**FS-4.1**

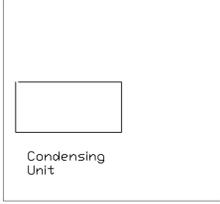

# LOFT & COTTAGE

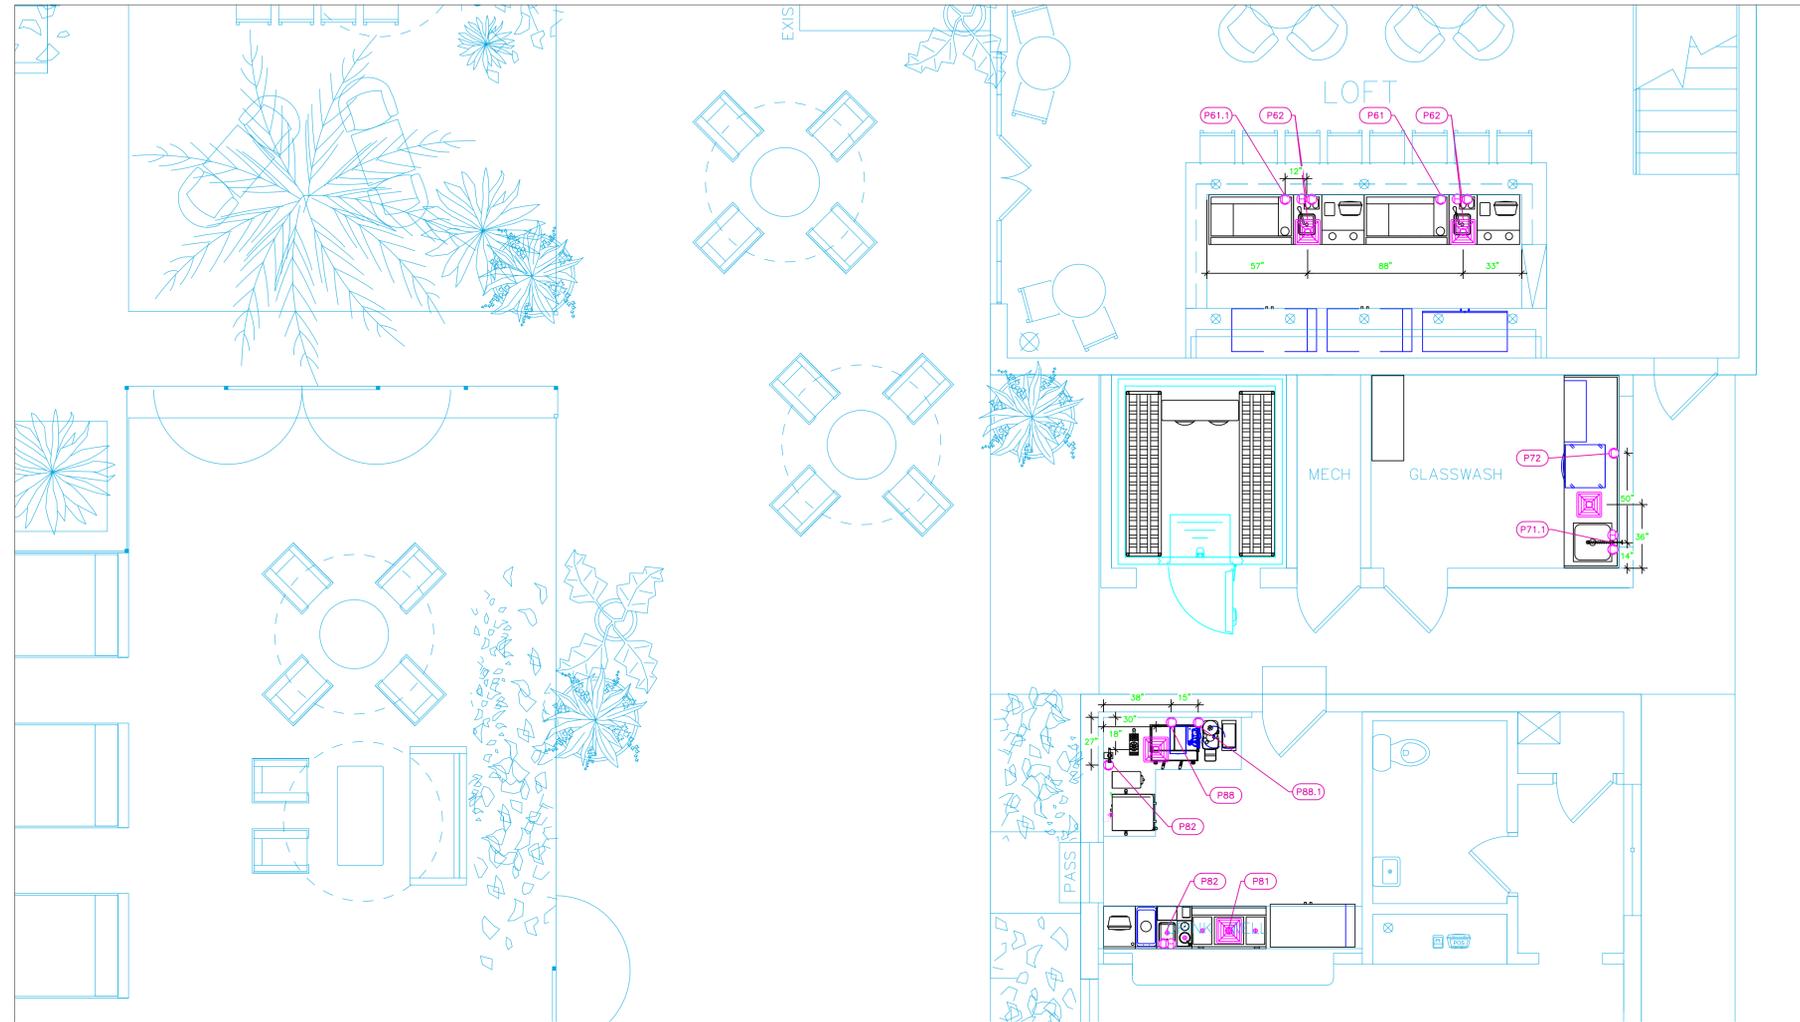

PLUMBING SCHEDULE											
ITEM NO.	DESCRIPTION	COLD WATER SIZE	HOT WATER SIZE	H&C Rough-In	DIRECT WASTE SIZE	INDIRECT WASTE SIZE	INDIRECT WASTE AFF.	GAS SIZE (IN)	GAS MBTU	QTY	PLUMBING REMARKS
61	Underbar Ice Bin / UC Ref	1/2"		24"		1/2"				1	Waste to Floor Sink
61.1	Underbar Ice Bin / UC Fre	1/2"		24"		1/2"				1	Waste to Floor Sink
62	Underbar Hand Sink Unit					1-1/2"				2	Waste to Floor Sink
64.1	Pantry Faucet	3/8"	3/8"	12"						2	
71	Cabinet									1	Floor Sink for Coffee Equipment
71.1	Work Table, with Prep Sink(s)									1	
72	Weld-In Sink					1-1/2"				1	Waste to Floor Sink
71.1	Pre-Rinse Faucet Assembly	1/2"	1/2"	12"						1	
72	Glasswasher, Undercounter / Underbar	3/4"		12"		5/8"				1	Water size note: 3/4" male GHT (connect to true 1/2" ID Line)
73.1	Evaporator					1"				1	Condensate Waste
73.2	Remote Condenser Unit									1	Interconnect refrig with Evap
81	Underbar Ice Bin / UC Ref	1/2"		24"		1/2"				1	Waste to Floor Sink
82	Underbar Hand Sink Unit					1-1/2"				2	Waste to Floor Sink
	Pantry Faucet	3/8"	3/8"	12"						2	
86	Coffee Tea Brewer	3/8"	3/8"	n/a						1	Water from Filter
87.1	Water Filtration System, for Coffee Brewers	3/8"		12"						1	Water to Coffee Machine
88	Espresso Cappuccino Machine	3/8"		n/a						1	Water from Filter
88.1	Reverse Osmosis System	3/8"		12"						1	Water to Coffee Equipment
89	Glass Rinser, Parts & Accessories	1/2"		12"		1/2"				1	Waste to Floor Sink
89.1	Water Dispensing Tower									1	Water from Boiler
89.2	Water Boiler	3/8"		12"						1	Water to Dispensing Tower

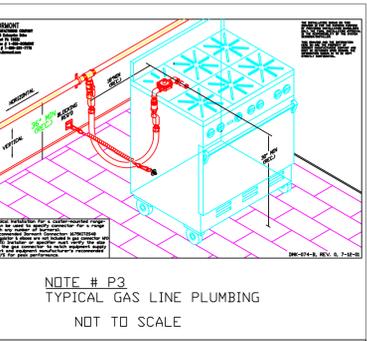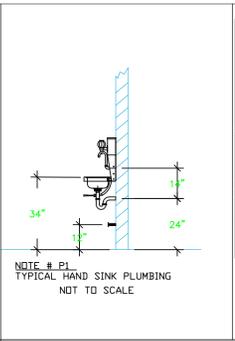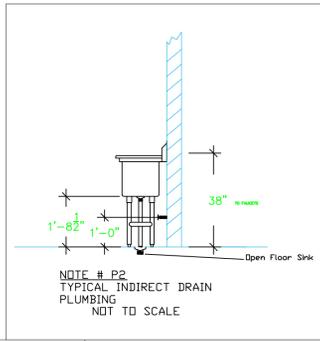

### LEGEND -- PLUMBING CONNECTIONS

- HW-HOT WATER, OR CW-COLD WATER
- GAS
- WASTE, DIRECT-CONNECTED
- WASTE, INDIRECT to Floor Sink, or Floor Dr
- ⊕ FLOOR DRAIN Josam 30000-E3
- ⊕ FLOOR DRAIN Josam 30000-A3
- ⊕ FLOOR SINK Zurn FD-2370-y-PV4-F
- FILTERED WATER, at machine.

NOTE # P4. ALL NATIONAL, STATE, AND LOCAL CODES SHALL APPLY

NOTE # P5. ALL PLUMBING CONNECTIONS TO BE EXTENDED AND INTERCONNECTED TO EQUIPMENT AND ALL HARDWARE REQUIRED TO BE PROVIDED BY PLUMBING CONTRACTOR

NOTE # P6. PLUMBING CONTRACTOR TO VERIFY THAT ALL EQUIPMENT IS INSTALLED WITH THE APPROPRIATE GAS PRESSURE AND REGULATORS

NOTE # P7. ALL WASTE LINES AND CONDENSATE LINES TO BE EXTEND FROM EQUIPMENT TO FLOOR DRAINS BY PLUMBING CONTRACTOR.

## Equipment PLUMBING Service Requirements

All Dimensions to be verified on the job site. Actual locations for floor drains, and any ventilating equipment to be determined by Engineer. Mechanical, Plumbing & Electrical to be checked and verified by Customers MEP Engineer. Remote Condensing Units to be located by Architect. Exhaust & Supply fans to be located by Architect.

**Soho House**  
Miami Pool House  
Kitchen & Bars  
Wynwood, Florida

SOHO HOUSE

**uni-source**  
SUPPLY  
INTERNATIONAL INC.

2055 W 73rd Street, Miami, FL 33016  
Ph:(305)826-8696 Fax:(305)826-9131

12	Updated backgrounds, underbar equipment custom	7-20-22
13	Elevations, Cooler, Shops, Cottage Bar, Hood	8-21-22
14	Added COB1 "Additional Items"	8-25-22
15	Added Dims for Field Measurements	10-14-22
No.	Revision/Issue	Date

Date  
**Oct 14, 2022**  
Drawn By  
**Dayne Gauntlett**  
Scale  
**1/4" = 1'0"**

Sheet  
**FS-4.2**