


EQUIPMENT SCHEDULE					
ItemNo	Category	Mfr	Model	Quantity	Equipment Remarks
91	Ice Bin for Ice Machines	Follett	SG500S-30	1	Existing
93	Rapid Cook Oven	Merrychef	E3	1	Existing
93.1	Work Table, Stainless Steel Top	Advance Tabco	KMS-362	1	
95	Reach-In Refrigerator	True Mfg. - General Foodservice	STR1R-1S-HC	2	Existing
96	Soiled Dishtable	Advance Tabco	DTU-U60-60L	1	Existing
96.1	Pre-Rinse Faucet Assembly	Krowne	17-108WL	1	Existing
97	Work Table, Stainless Steel Top	Advance Tabco	KMS-308	1	Existing
98	Sandwich / Salad Preparation Refrigerator	True Mfg. - General Foodservice	TSSU-72-08-HC	1	Existing
101	Ventless Exhaust System	Wells	WVU-72	1	
102	Range, 36", 2 French Hot Plates, 24" Griddle	Vulcan	EV36S-2FP24G208	1	
103	Electric Floor Fryer	Vulcan	1ER50A	2	

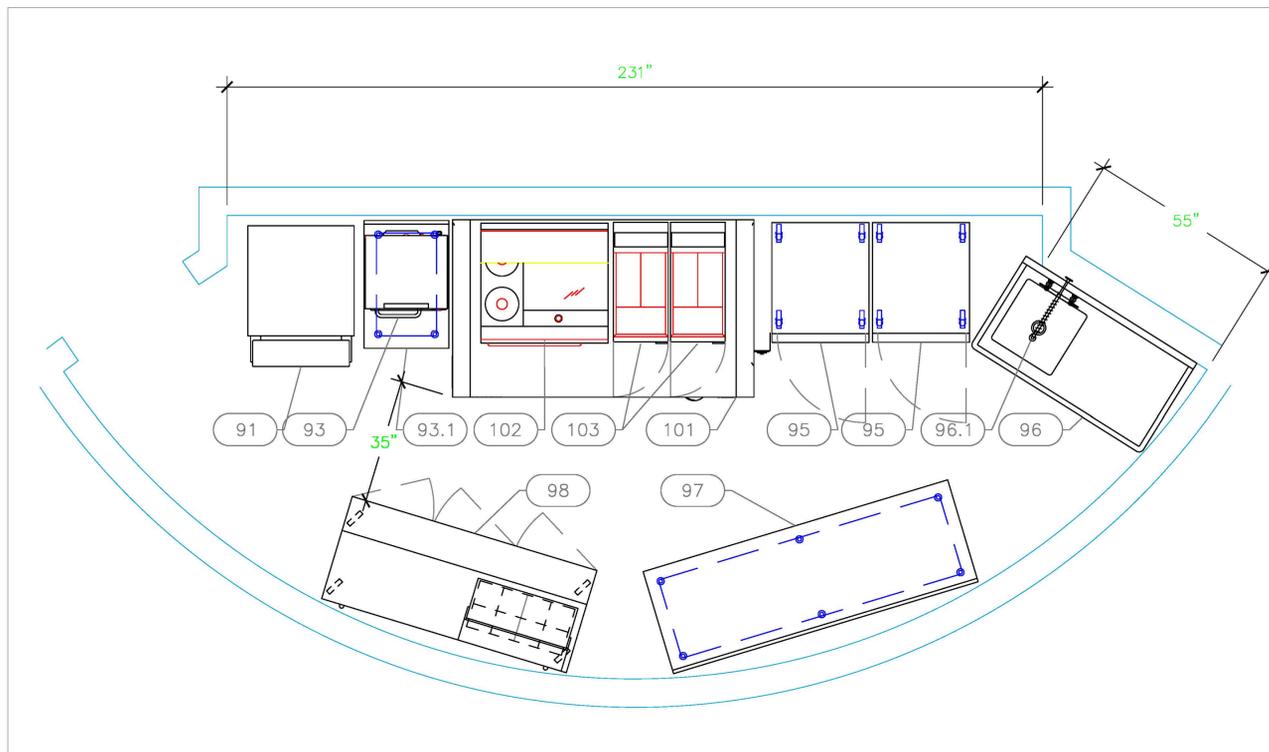

EQUIPMENT LAYOUT

All Dimensions to be verified on the job site.
 Actual locations for floor drains, and any ventilating equipment to be determined by Engineer.
 Mechanical, Plumbing & Electrical to be checked and verified by Customers MEP Engineer.
 Remote Condensing Units to be located by Architect.
 Exhaust & Supply fans to be located by Architect.

Baha Mar
Out Island Kitchen
 Nassau, Bahamas



INTERNATIONAL INC.


2055 W 73rd Street, Miami, FL 33016
 Ph: (305)826-8696 Fax: (305)826-9131

1	Approved Layout	5-12-23
2	Switched to Electric Equipment	5-15-23
3	Switched hood to Ventless	8-21-23
4	Added Electrical Sheet	4-24-24
No.	Revision/Issue	Date

Date
April 24, 2024
 Drawn By
Dayne Gauntlett
 Scale
1/2" = 1'0"


Sheet
FS-1.0

ELECTRICAL SCHEDULE											
ItemNo	Category	Voltage	Cycle	Phase	Amps	Hp	NEMA	ConnectionType	Rough-In AFF	Quantity	Electrical Remarks
91	Ice Bin for Ice Machines	Existing	Existing	Existing						1	Existing
93	Rapid Cook Oven	Existing	Existing	Existing						1	Existing
95	Reach-In Refrigerator	Existing	Existing	Existing						2	Existing
98	Sandwich / Salad Preparation Refrigerator	Existing	Existing	Existing						1	Existing
101	Ventless Exhaust System	208	60	1	3.5	1		J-Box	108"	1	
102	Range, 36", 2 French Hot Plates, 24" Griddle	208	50/60	3	51.6			J-Box	18"	1	
103	Electric Floor Fryer	208	50/60	3	47.0			J-Box	18"	2	

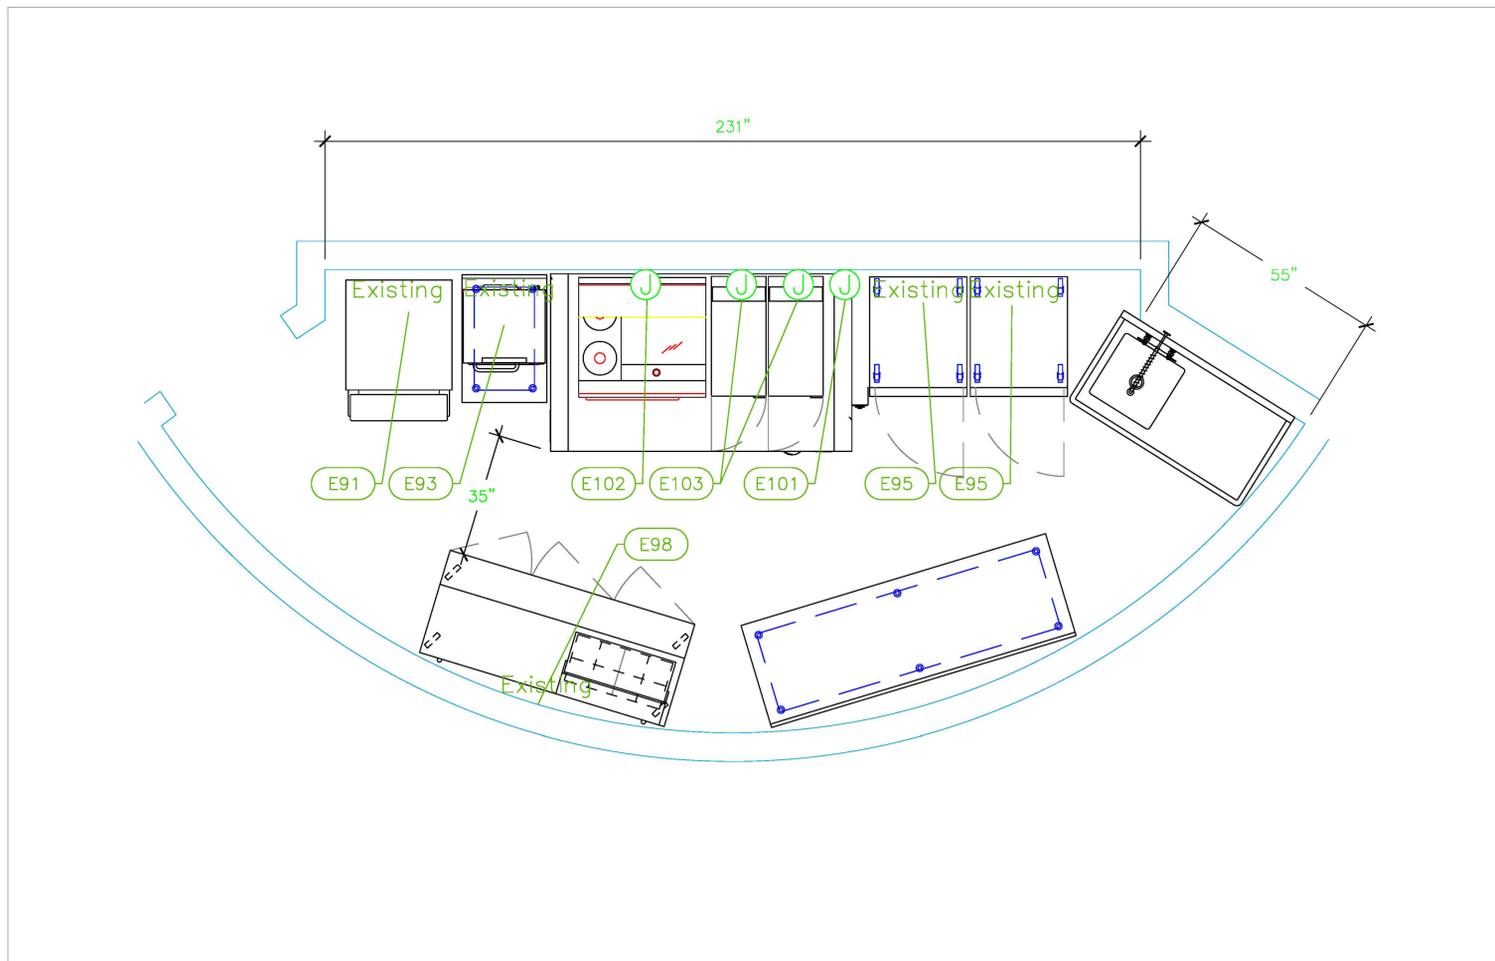

LEGEND - ELECTRICAL CONNECTIONS

- DUPLEX RECEPT., 15-AMP, 120-VOLT, GROUND TYPE, HORIZONTAL MOUNT
- SIMPLEX RECEPT., 120-VOLT, GROUND TYPE, HORIZONTAL MOUNT
- SPECIAL PURPOSE OUTLET, GROUND TYPE, HORIZONTAL MOUNT
- JUNCTION BOX, DIRECT CONNECTION
- DISCONNECT SWITCH, DIRECT CONNECTION
- FLOOR/CEILING RECEPTACLE AS INDICATED
- (2) Telephone + (2) Data
- FIELD CONNECTIONS
- HARD WIRE CONNECTION POINT AT MACHINE

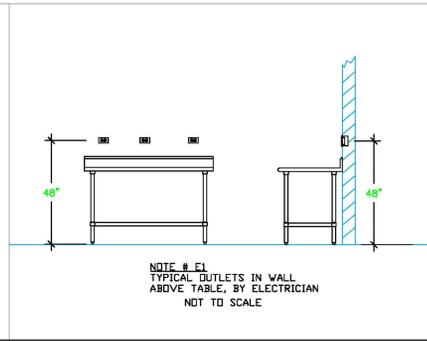

NOTE # E2.
ALL NATIONAL, STATE, AND LOCAL CODES SHALL APPLY.

NOTE # E3.
ALL ELECTRICAL CONNECTIONS AND HARDWARE REQUIRED TO BE PROVIDED BY ELECTRICAL CONTRACTOR.

NOTE # E4.
ALL JUNCTION BOXES, OUTLETS, ETC. TO BE LOCATED SO AS TO NOT INTERFERE WITH EQUIPMENT.

NOTE # E5.
ALL RELAYS, CONTRACTORS, STARTERS, AND SWITCHES REQUIRED FOR EXHAUST & SUPPLY FANS TO BE PROVIDED BY ELECTRICAL CONTRACTOR UNLESS SPECIFIED.

NOTE # E6.
ELECTRICAL CONTRACTOR TO INTERCONNECT DISHMACHINE TO EXHAUST FAN FOR DISHMACHINE SO THAT THE FAN RUNS WHEN THE DISHMACHINE IS IN OPERATION.

NOTE # E7.
ELECTRICAL CONTRACTOR TO INSTALL TABLE LIMIT SWITCH TO END OF CLEAN DISHABLE TO THAT MACHINE STOPS WHEN SWITCH IS DEPRESSED.

NOTE # E8.
ELECTRICAL CONTRACTOR TO CONNECT DRAIN LINE HEATER, PAN HEATER AND DOOR HEATER FOR WALK-IN FREEZER.

Equipment ELECTRICAL Service Requirements

All Dimensions to be verified on the job site. Actual locations for floor drains, and any ventilating equipment to be determined by Engineer. Mechanical, Plumbing & Electrical to be checked and verified by Customers MEP Engineer. Remote Condensing Units to be located by Architect. Exhaust & Supply fans to be located by Architect.

Baha Mar
Out Island Kitchen
Nassau, Bahamas

INTERNATIONAL INC.
2055 W 73rd Street, Miami, FL 33016
Ph:(305)826-8696 Fax:(305)826-9131

No.	Revision/Issue	Date
1	Approved Layout	5-12-23
2	Switched to Electric Equipment	5-15-23
3	Switched hood to Ventless	8-21-23
4	Added Electrical Sheet	4-24-24





Date
April 24, 2024

Drawn By
Dayne Gauntlett

Scale
1/2" = 1'0"

Sheet
FS-3.1

PLUMBING SCHEDULE											
ITEM NO.	DESCRIPTION	COLD WATER SIZE	HOT WATER SIZE	H&C Rough-In	DIRECT WASTE SIZE	DIRECT WASTE AFF	INDIRECT WASTE SIZE	GAS SIZE(IN)	GAS MBTU	QTY	PLUMBING REMARKS
91	Ice Bin for Ice Machines	Existing		Existing			Existing			1	Existing
96	Soiled Dishtable						Existing			1	Existing
96.1	Pre-Rinse Faucet Assembly	Existing	Existing	Existing						1	Existing

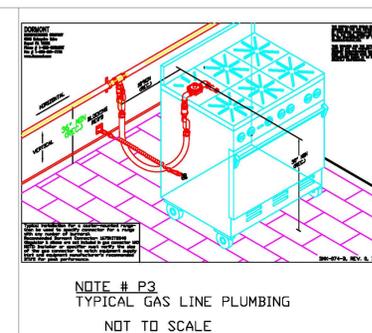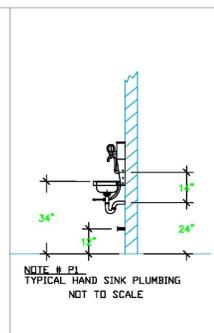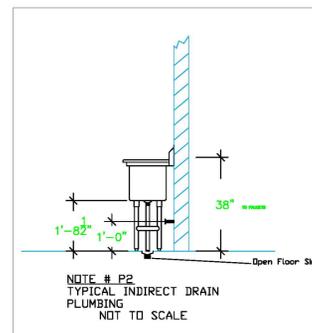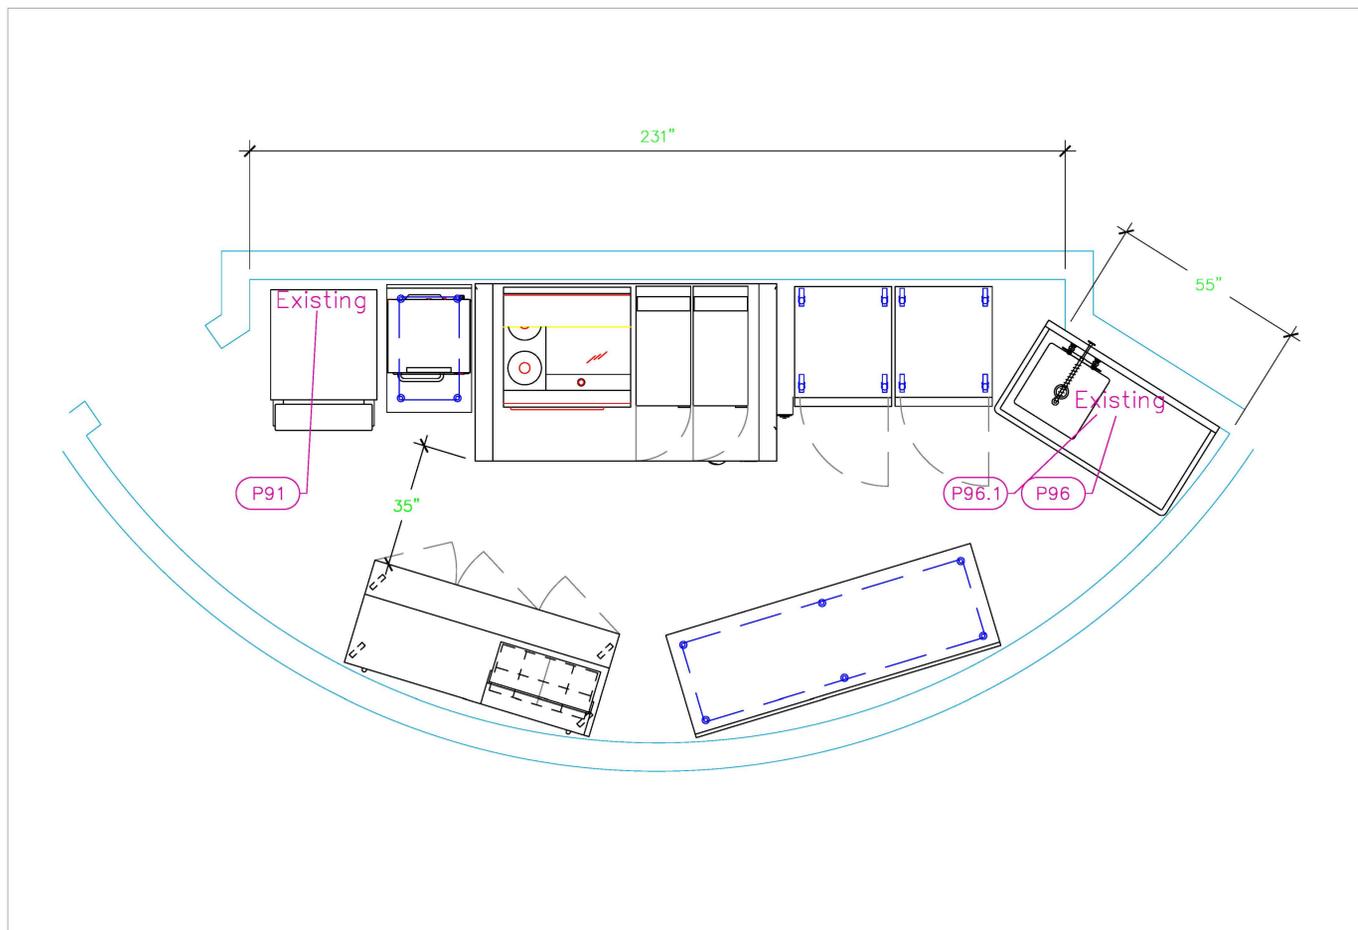

LEGEND -- PLUMBING CONNECTIONS

- HW-HOT WATER, OR CW-COLD WATER
- GAS
- WASTE, DIRECT-CONNECTED
- WASTE, INDIRECT to Floor Sink, or Floor Dr
- FUNNEL FLOOR DRAIN Josam 30000-E3
- FLOOR DRAIN Josam 30000-A3
- FLOOR SINK Proflo PF42856 or similar
- FILTERED WATER, at machine.

NOTE # P4. ALL NATIONAL, STATE, AND LOCAL CODES SHALL APPLY

NOTE # P5. ALL PLUMBING CONNECTIONS TO BE EXTENDED AND INTERCONNECTED TO EQUIPMENT AND ALL HARDWARE REQUIRED TO BE PROVIDED BY PLUMBING CONTRACTOR

NOTE # P6. PLUMBING CONTRACTOR TO VERIFY THAT ALL EQUIPMENT IS INSTALLED WITH THE APPROPRIATE GAS PRESSURE AND REGULATORS

NOTE # P7. ALL WASTE LINES AND CONDENSATE LINES TO BE EXTEND FROM EQUIPMENT TO FLOOR DRAINS BY PLUMBING CONTRACTOR.

Equipment PLUMBING Service Requirements

All Dimensions to be verified on the job site. Actual locations for floor drains, and any ventilating equipment to be determined by Engineer. Mechanical, Plumbing & Electrical to be checked and verified by Customers MEP Engineer. Remote Condensing Units to be located by Architect. Exhaust & Supply fans to be located by Architect.

Baha Mar
Out Island Kitchen
Nassau, Bahamas



INTERNATIONAL INC.
 2055 W 73rd Street, Miami, FL 33016
 Ph:(305)826-8696 Fax:(305)826-9131

No.	Revision/Issue	Date
1	Approved Layout	5-12-23
2	Switched to Electric Equipment	5-15-23
3	Switched hood to Ventless	8-21-23
4	Added Electrical Sheet	4-24-24

Date
April 24, 2024
 Drawn By
Dayne Gauntlett
 Scale
1/2" = 1'0"

Sheet
FS-4.1