






PLUMBING SCHEDULE											
ITEM NO.	DESCRIPTION	COLD WATER SIZE	HOT WATER SIZE	H&C Rough-In	DIRECT WASTE SIZE	DIRECT WASTE AFF	INDIRECT WASTE SIZE	GAS SIZE (IN)	GAS MBTU	QTY	PLUMBING REMARKS
61	Ice Bin with Bottle Wells						1-1/2"			1	Waste to Floor Sink
62	Underbar Sink Units	1/2"	1/2"	12"			1-1/2"			2	4" faucet, Sink
		1/2"		12"			1-1/2"			2	Rinser, Dipperwell
		1/2"		12"						2	Dipperwell
65	Glasswasher, Undercounter / Underbar	3/4"		12"			5/8"			1	Waste to Floor Sink
66	Hand Sink	1/2"	1/2"	12"			1"			1	Waste to Floor Sink
67	underbar corner						1"			1	Waste to Floor Sink
68	Ice Bin with Bottle Wells						1/2"			1	Waste to Floor Sink
69	Glass Rack						1"			1	drain in drainboard top
73	Espresso Cappuccino Machine	1/4"		12"			3/4"			1	Waste to Floor Sink
86	Work Table, Stainless Steel Top									1	
	Weld-in Sink						1-1/2"			1	Waste to Floor Sink
	Drop-In Sink				1-1/2"					1	(1) set of 1/2" faucet holes, 4" OC
86.1	Deck Mount Faucet	1/2"	1/2"	12"						1	
86.2	Deck Mount Faucet	1/2"	1/2"	12"						1	
90	Pizza Bake Oven, Deck-Type, Gas							3/4"	116	1	See Note P3

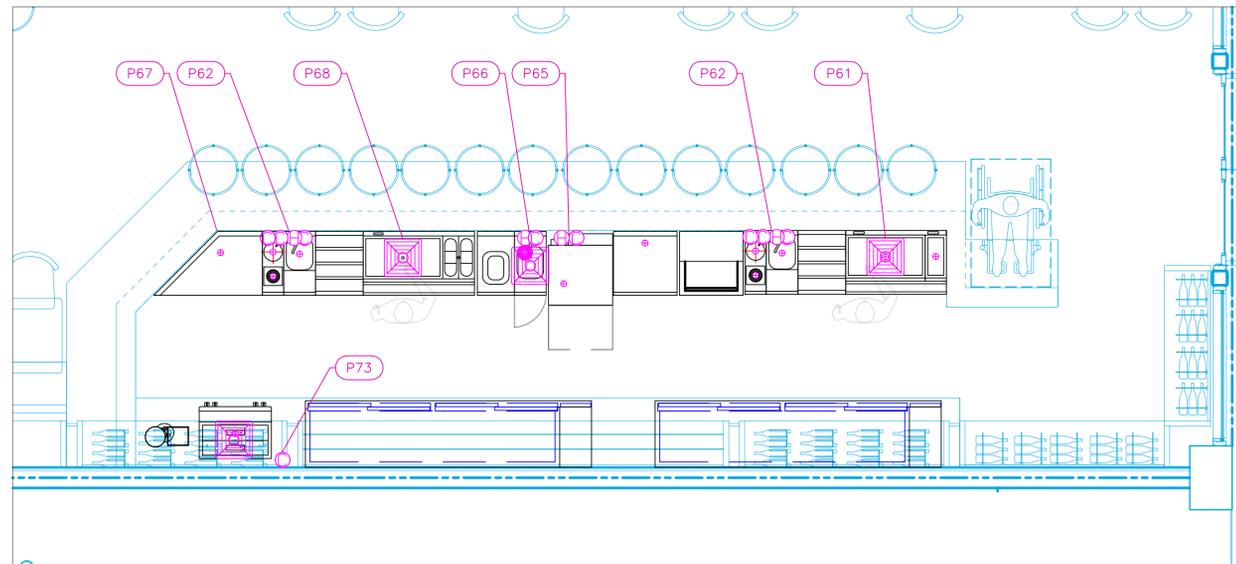

Bar

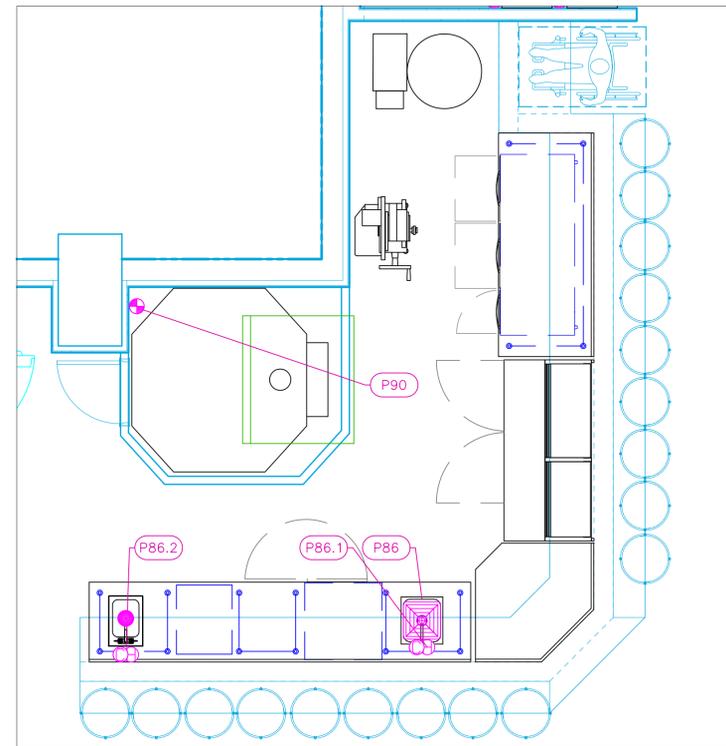

Pizza Bar

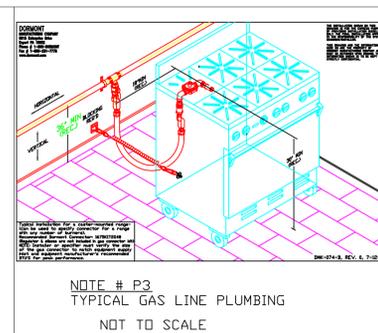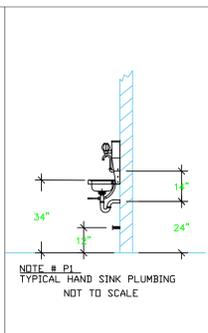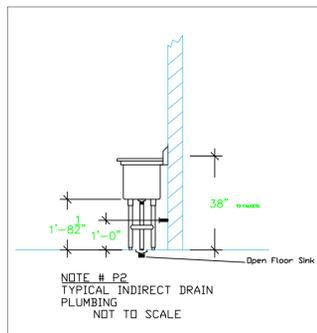

LEGEND -- PLUMBING CONNECTIONS

- ○ HW--HOT WATER, OR CW--COLD WATER
- GAS
- WASTE, DIRECT--CONNECTED
- WASTE, INDIRECT to Floor Sink, or Floor Drain
- FLOOR DRAIN Josam 30000-E3
- FLOOR DRAIN Josam 30000-A3
- FLOOR SINK Proflo PF42856 or similar
- FILTERED WATER, at machine.

NOTE # P4.
ALL NATIONAL, STATE, AND LOCAL
CODES SHALL APPLY

NOTE # P5.
ALL PLUMBING CONNECTIONS TO
BE EXTENDED AND
INTERCONNECTED TO EQUIPMENT
AND ALL HARDWARE REQUIRED TO
BE PROVIDED BY PLUMBING
CONTRACTOR

NOTE # P6.
PLUMBING CONTRACTOR TO VERIFY
THAT ALL EQUIPMENT IS
INSTALLED WITH THE
APPROPRIATE GAS PRESSURE AND
REGULATORS

NOTE # P7.
ALL WASTE LINES AND
CONDENSATE LINES TO BE EXTEND
FROM EQUIPMENT TO FLOOR
DRAINS BY PLUMBING CONTRACTOR.

**Equipment
PLUMBING
Service Requirements**

All Dimensions to be verified on the job site.
Actual locations for floor drains, and any ventilating
equipment to be determined by Engineer.
Mechanical, Plumbing & Electrical to be checked and verified
by Customers MEP Engineer.
Remote Condensing Units to be located by Architect.
Exhaust & Supply fans to be located by Architect.

**Museum Garage
Le Specialita Kitchen & Bar
Miami, Florida**



INTERNATIONAL INC.
2055 W 73rd Street, Miami, FL 33016
Ph:(305)826-8696 Fax:(305)826-9131

No.	Revision/Issue	Date
11	Added New Pizza Bar, and updated Bar	4-4-24
12	Added Captive Aire shops, and MEP requirements.	4-12-24
13	Added Hand sink to #86 & changed # 5&6 per Janes	5-7-24
14	Changed Bar, and Pass Line (10-14)	6-27-24

Date
June 27, 2024
Drawn By
Dayne Gauntlett
Scale
3/8" = 1'

Sheet
FS-4.2