

EQUIPMENT SCHEDULE					
ItemNo	Category	Mfr	Model	Quantity	Equipment Remarks
1	Back Bar Cabinet, Refrigerated	Turbo Air	TBB-24-48SGD-N	1	Existing
2	Bottle Cooler	True Mfg. - General Foodservice	TD-36-12-S-HC	1	Existing
4	Underbar Sink Units	Krowne	KR19-53C	1	Existing
5	Drainboard	Krowne	KR19-GS18	1	Existing
6	Ice Bin	Krowne	KR19-12	1	Existing
7	Ice Bin	Krowne	KR19-30	1	Existing
8	Dishwasher, Undercounter	Jackson WWS	DISHSTAR HT-E-SEER	1	
9	Hand Sink	Krowne	KR24-SD12C	1	
10	Bottle Storage Unit	Krowne	KR24-24RD	1	
10.1	Bottle Storage Unit	Krowne	KR24-30RD	1	
11	Work Center	Krowne	KR24-PC18	2	
12	Underbar Add-On Unit	Krowne	KR24-T12	3	
13	Stainless Corner Cabinet	Custom Fab	Q1493-13	1	
13.1	Stainless Corner Cabinet	Custom Fab	Q1493-13.1	1	
14	Cocktail Station	Krowne	KR24-MX70-10	1	
15	Blender Station	Krowne	KR29-18FD	1	
15.1	Ice Crusher Chopper, Countertop	Hamilton Beach	HBS1400	1	By Owner/Operator
16	Back Bar Cabinet, Refrigerated, Pass-Thru	Krowne	KPT72L	1	
17	Bottle Cooler	Krowne	BC36-SS	1	
18	Glass Froster	Krowne	FMC24	1	
19	Beer Drainer	Krowne	KR24-RS24	1	
19.1	Coffee Tea Brewer	BUNN	52400.0100	1	By Owner/Operator
20	Frozen Drink Machine, Non-Carbonated, Cylinder Type	Spaceman	6795-C	1	By Owner/Operator
21	Drainboard	Krowne	KR24-SD30	1	
23	Drainboard, Beer Drainer	Krowne	KR24-BD12	2	
24	Back Bar Cabinet, Refrigerated	Micro Matic	MBB78S-E	1	
25	Draft Beer / Wine Dispensing Tower	Micro Matic	D4743DTKR	2	
25.1	Drip Tray	Micro Matic	DP-920D	2	
26	Draft Beer System Power Pack	Micro Matic	MMPP4301-PKG	1	
27	Cabinet	Custom Fab	CABINET	1	

## EQUIPMENT LAYOUT

All Dimensions to be verified on the job site.  
Actual locations for floor drains, and any ventilating equipment to be determined by Engineer.  
Mechanical, Plumbing & Electrical to be checked and verified by Customers MEP Engineer.  
Remote Condensing Units to be located by Architect.  
Exhaust & Supply fans to be located by Architect.

Wymara Resorts & Villas  
Pink Bar  
Providenciales, T&C

WYMARA  
RESORT AND VILLAS  
TURKS + CAICOS

uni-source  
SUPPLY


INTERNATIONAL INC.

2055 W 73rd Street, Miami, FL 33016  
Ph: (305)826-8696 Fax: (305)826-9131


No.	Revision/Issue	Date
3	Added MEP Information	8-13-22
4	Update after comments from customer	8-15-22
5	Added MEP Dimensions	9-06-22
6	Added #27, adjusted beer conduit at #27, top cutout	9-07-22

Date  
Sept 07, 2022  
Drawn By  
Dayne Gauntlett  
Scale  
3/8" = 1'0"


Sheet  
FS-1.1

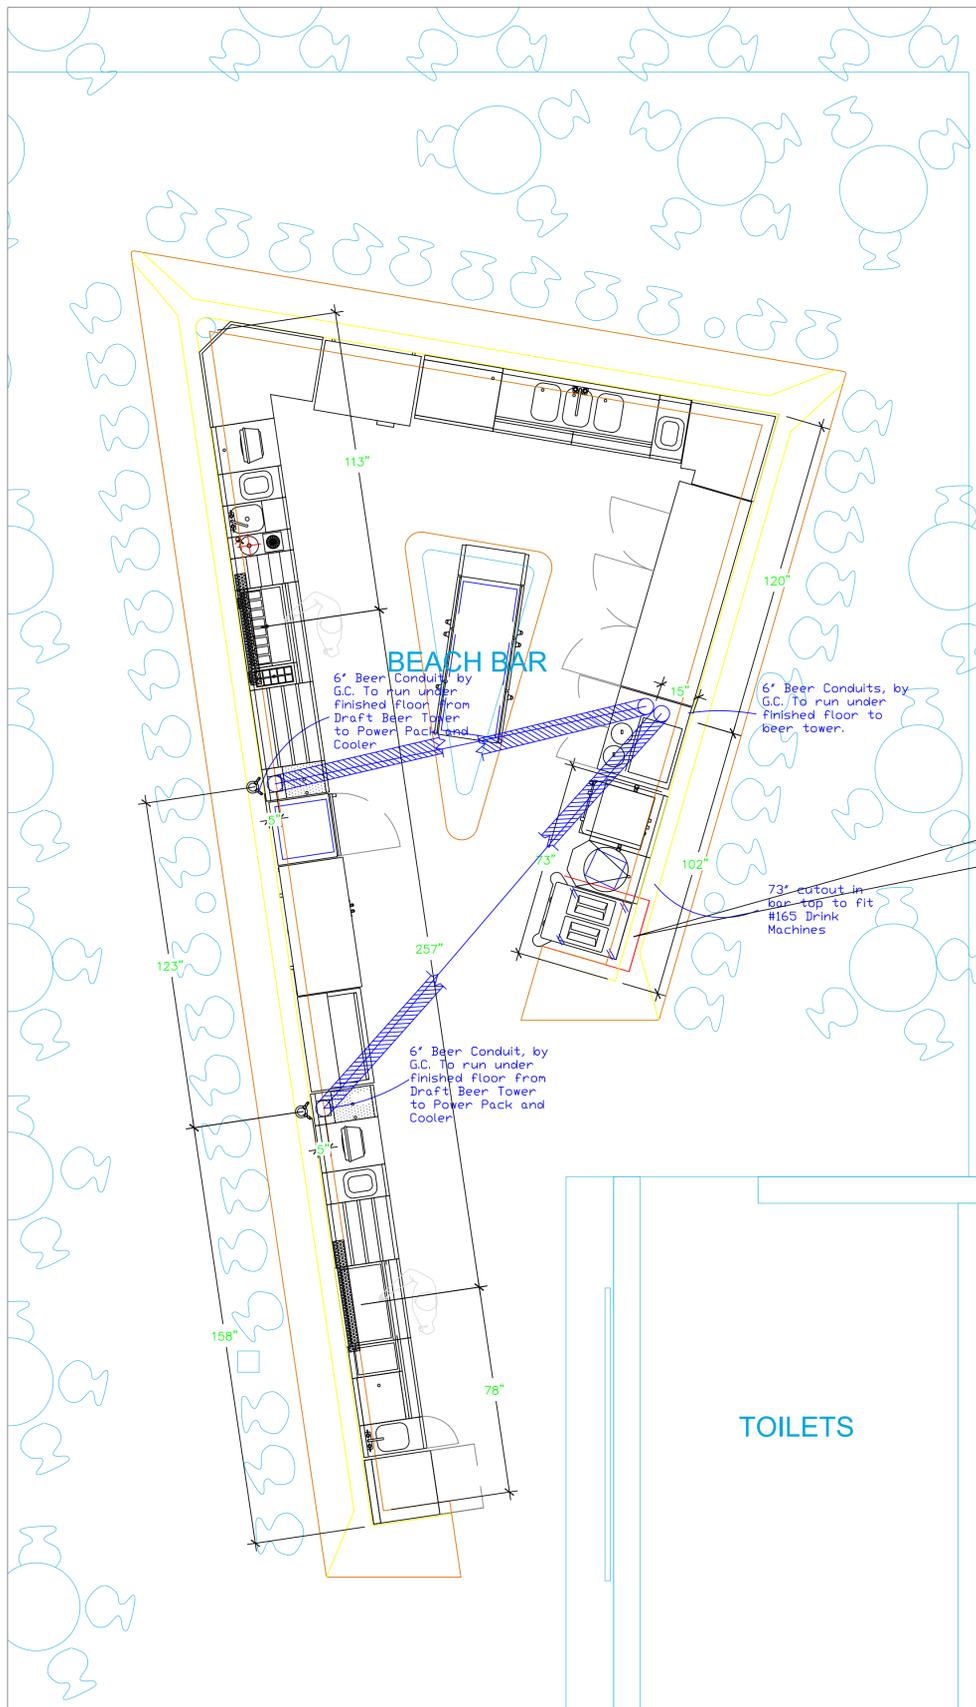

Mechanical Schedule								
ITEM NO.	QTY	DISCRIPTION	EXHAUST (L X W)	EXHAUST (CFM)	SUPPLY (L X W)	SUPPLY (CFM)	Ventilation Remarks	Unit
15	1	Blender Station					Bar top needs to be cut out at this machine	ea
15.1	1	Ice Crusher Chopper, Countertop					Bar top needs to be cut out at this machine	ea
16	1	Back Bar Cabinet, Refrigerated, Pass-Thru					Refrigerator to be coordinated with Millwork	ea
19	1	Beer Drainer					Bar top needs to be cut out at this machine	ea
19.1	1	Coffee Tea Brewer					Bar top needs to be cut out at this machine	ea
20	1	Frozen Drink Machine, Non-Carbonated, Cylinder Type					Bar top needs to be cut out at this machine	ea
25	2	Draft Beer / Wine Dispensing Tower					Beverage Conduit 6"	ea
26	1	Draft Beer System Power Pack					Beverage Conduit 6"	ea

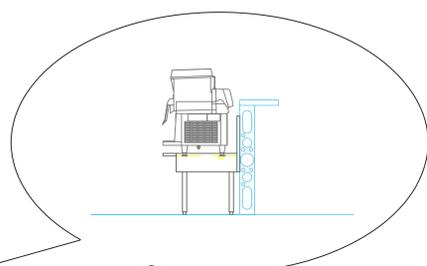

- LEGEND - MECHANICAL**
- EXHAUST DUCT COLLAR
  - SUPPLY DUCT COLLAR
  - INWALL BACKING FOR WALL SHELVES
  - RECESSED FLOOR
  - RAISED EQUIPMENT PAD

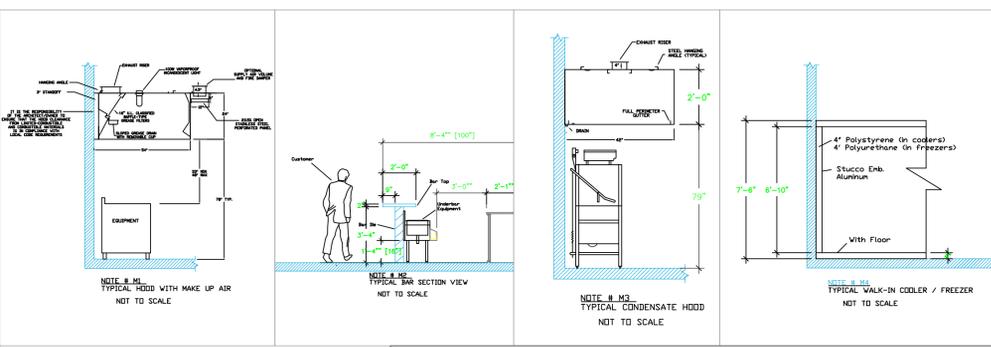

**NOTE # M5**  
SHOP DRAWING WILL BE PROVIDED BY MANUFACTURER FOR HOOD, EXHAUST FANS, & SUPPLY FANS, UNCE ORDER IS PLACE WITH.

**NOTE # M6**  
ARCHITECT OR ENGINEER TO SIZE AND LOCATE, CONTRACTOR TO PROVIDE ALL OPENINGS FOR DUCTS, PLUMBING LINES, ELECTRICAL LINES, AND REFRIGERATION LINES, AS REQUIRED BY EQUIPMENT.

**NOTE # M7**  
SUPPLY FANS TO BE LOCATED A MINIMUM OF 10' FROM EXHAUST FANS.

**NOTE # M8**  
CEILING HEIGHTS TO BE VERIFIED FOR SUFFICIENT CLARENCE FOR EQUIPMENT.

**NOTE # M9**  
GENERAL CONTRACTOR TO PROVIDE 2" PLYWOOD WALL BACKING FROM 30" TO 78" AFF FOR ALL WALL MOUNTED EQUIPMENT.

**NOTE # M10**  
CEILING HEIGHTS TO BE VERIFIED FOR SUFFICIENT CLARENCE FOR EQUIPMENT.

**NOTE # M11**  
REFRIGERATION CONTRACTOR TO HANG EVAPORATORS FOR WALK-IN, RUN & CHARGE LINES BETWEEN EVAP. & CONDENSING UNIT.

## Equipment MECHANICAL Service Requirements

All Dimensions to be verified on the job site. Actual locations for floor drains, and any ventilating equipment to be determined by Engineer. Mechanical, Plumbing & Electrical to be checked and verified by Customers MEP Engineer. Remote Condensing Units to be located by Architect. Exhaust & Supply Fans to be located by Architect.

**Wymara Resorts & Villas**  
*Pink Bar*  
**Providenciales, T&C**

**WYMARARA**  
RESORT AND VILLAS  
TURKS + CAICOS

**uni-source**  
SUPPLY  
INTERNATIONAL INC.

2055 W 73rd Street, Miami, FL 33016  
Ph: (305) 826-8696 Fax: (305) 826-9131


3	Added MEP Information	8-13-22
4	Update after comments from customer	8-15-22
5	Added MEP Dimensions	9-06-22
6	Added #27, adjusted beer conduit at #27, top cutout	9-07-22
No.	Revision/Issue	Date

Date  
**Sept 07, 2022**

Drawn By  
**Dayne Gauntlett**

Scale  
**3/8" = 1'0"**


Sheet  
**FS-2.1**

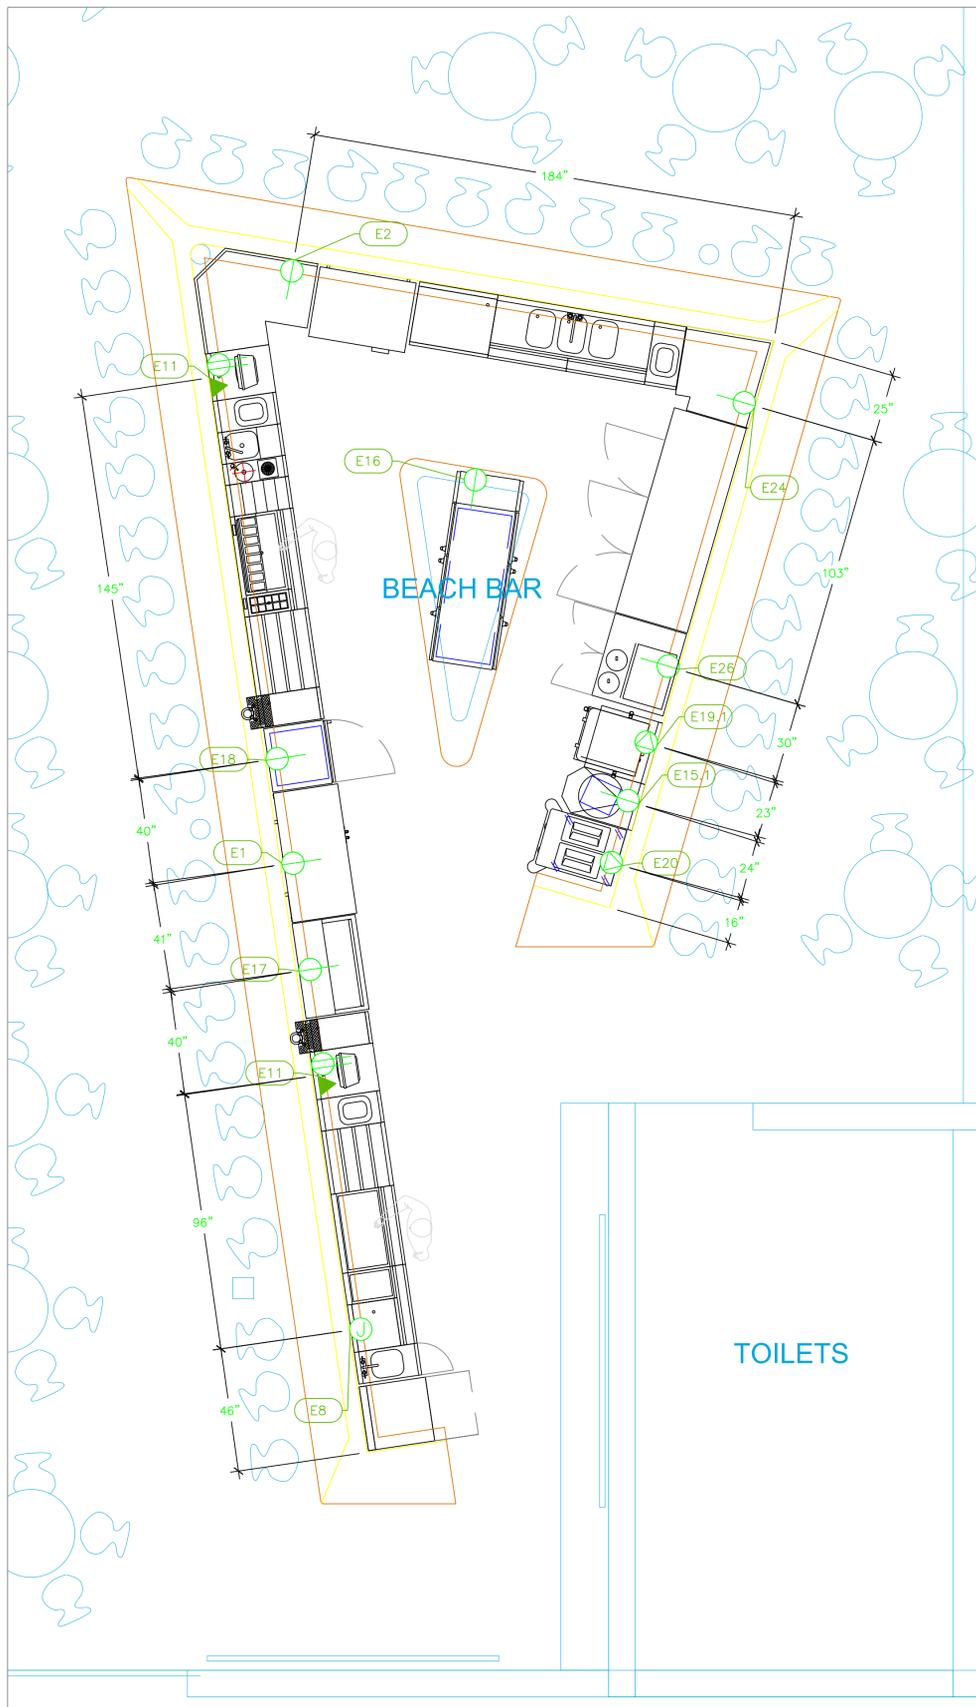

ELECTRICAL SCHEDULE											
ItemNo	Category	Voltage	Cycle	Phase	Amps	Hp	NEMA	ConnectionType	Rough-In AFF	Quantity	Electrical Remarks
1	Back Bar Cabinet, Refrigerated	115	60	1	2.6	1/3	5-15P	Simplex	18"	1	
2	Bottle Cooler	115	60	1	1.4	1/10	5-15P	Simplex	18"	1	
8	Dishwasher, Undercounter	208	60	1	24.7	1		J-Box	18"	1	
11	Work Center	115	60	1	15			Duplex	16"	2	
								DATA	16"	2	
14.1	Soda System, Parts & Fittings	110	60	1	15			Simplex	18"	1	Confirm elec with Soda Gun Manufacturer
15.1	Ice Crusher Chopper, Countertop	120	60	1	15	3		Simplex	14"	1	Confirm Electrical with Owner
16	Back Bar Cabinet, Refrigerated, Pass-Thru	115	60	1	4.8	1/4	5-15P	Simplex	18"	1	
17	Bottle Cooler	115	60	1	4.0	1/5	5-15P	Simplex	18"	1	Do not plug into GFI outlet
18	Glass Froster	115	60	1	5.2	1/3	5-15P	Simplex	18"	1	Do not plug into GFI outlet
19.1	Coffee Tea Brewer	120/240	60	1	25			Special	14"	1	Confirm Electrical with Owner
20	Frozen Drink Machine, Non-Carbonated, Cylinder Type	208-230	60	1	24		L6-30P	Special	18"	1	
24	Back Bar Cabinet, Refrigerated	115	60	1	3	1/3	5-15P	Simplex	18"	1	
26	Draft Beer System Power Pack	115	60	1	5.0	1/4	5-15P	Simplex	18"	1	

**LEGEND - ELECTRICAL CONNECTIONS**

- DUPLEX RECEPT., 15-AMP, 120-VOLT, GROUND TYPE, HORIZONTAL MOUNT
- SIMPLEX RECEPT., 120-VOLT, GROUND TYPE, HORIZONTAL MOUNT
- SPECIAL PURPOSE OUTLET, GROUND TYPE, HORIZONTAL MOUNT
- JUNCTION BOX, DIRECT CONNECTION
- DISCONNECT SWITCH, DIRECT CONNECTION
- FLOOR/CEILING RECEPTACLE AS INDICATED
- (2) Telephone + (2) Data
- FIELD CONNECTIONS
- HARD WIRE CONNECTION POINT AT MACHINE

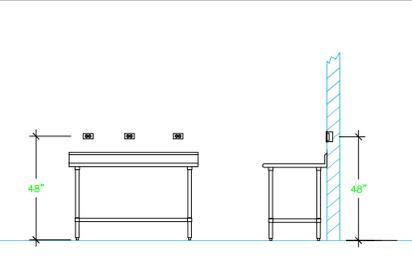

**NOTE # E2**  
ALL NATIONAL, STATE, AND LOCAL CODES SHALL APPLY.

**NOTE # E3**  
ALL ELECTRICAL CONNECTIONS AND HARDWARE REQUIRED TO BE PROVIDED BY ELECTRICAL CONTRACTOR.

**NOTE # E4**  
ALL JUNCTION BOXES, OUTLETS, ETC. TO BE LOCATED SO AS TO NOT INTERFERE WITH EQUIPMENT.

**NOTE # E5**  
ALL RELAYS, CONTRACTORS, STARTERS, AND SWITCHES REQUIRED FOR EXHAUST & SUPPLY FANS TO BE PROVIDED BY ELECTRICAL CONTRACTOR UNLESS SPECIFIED.

**NOTE # E6**  
ELECTRICAL CONTRACTOR TO INTERCONNECT DISHMACHINE TO EXHAUST FAN FOR DISHMACHINE SO THAT THE FAN RUNS WHEN THE DISHMACHINE IS IN OPERATION.

**NOTE # E7**  
ELECTRICAL CONTRACTOR TO INSTALL TABLE LIMIT SWITCH TO END OF CLEAN DISHTABLE TO THAT MACHINE STOPS WHEN SWITCH IS DEPRESSED.

**NOTE # E8**  
ELECTRICAL CONTRACTOR TO CONNECT DRAIN LINE HEATER, PAN HEATER AND DODR HEATER FOR WALK-IN FREEZER.

## Equipment ELECTRICAL Service Requirements

All Dimensions to be verified on the job site. Actual locations for floor drains, and any ventilating equipment to be determined by Engineer. Mechanical, Plumbing & Electrical to be checked and verified by Customers MEP Engineer. Remote Condensing Units to be located by Architect. Exhaust & Supply fans to be located by Architect.

**Wymara Resorts & Villas**  
*Pink Bar*  
**Providenciales, T&C**

**WYMARA**  
RESORT AND VILLAS  
TURKS + CAICOS

**uni-source**  
SUPPLY  
INTERNATIONAL INC.

2055 W 73rd Street, Miami, FL 33016  
Ph:(305)826-8696 Fax:(305)826-9131


3	Added MEP Information	8-13-22
4	Update after comments from customer	8-15-22
5	Added MEP Dimensions	9-06-22
6	Added #27, adjusted beer conduit at #27, top cutout	9-07-22
No.	Revision/Issue	Date

Date  
**Sept 07, 2022**


Drawn By  
**Dayne Gauntlett**

Scale  
**3/8" = 1'0"**

Sheet  
**FS-3.1**

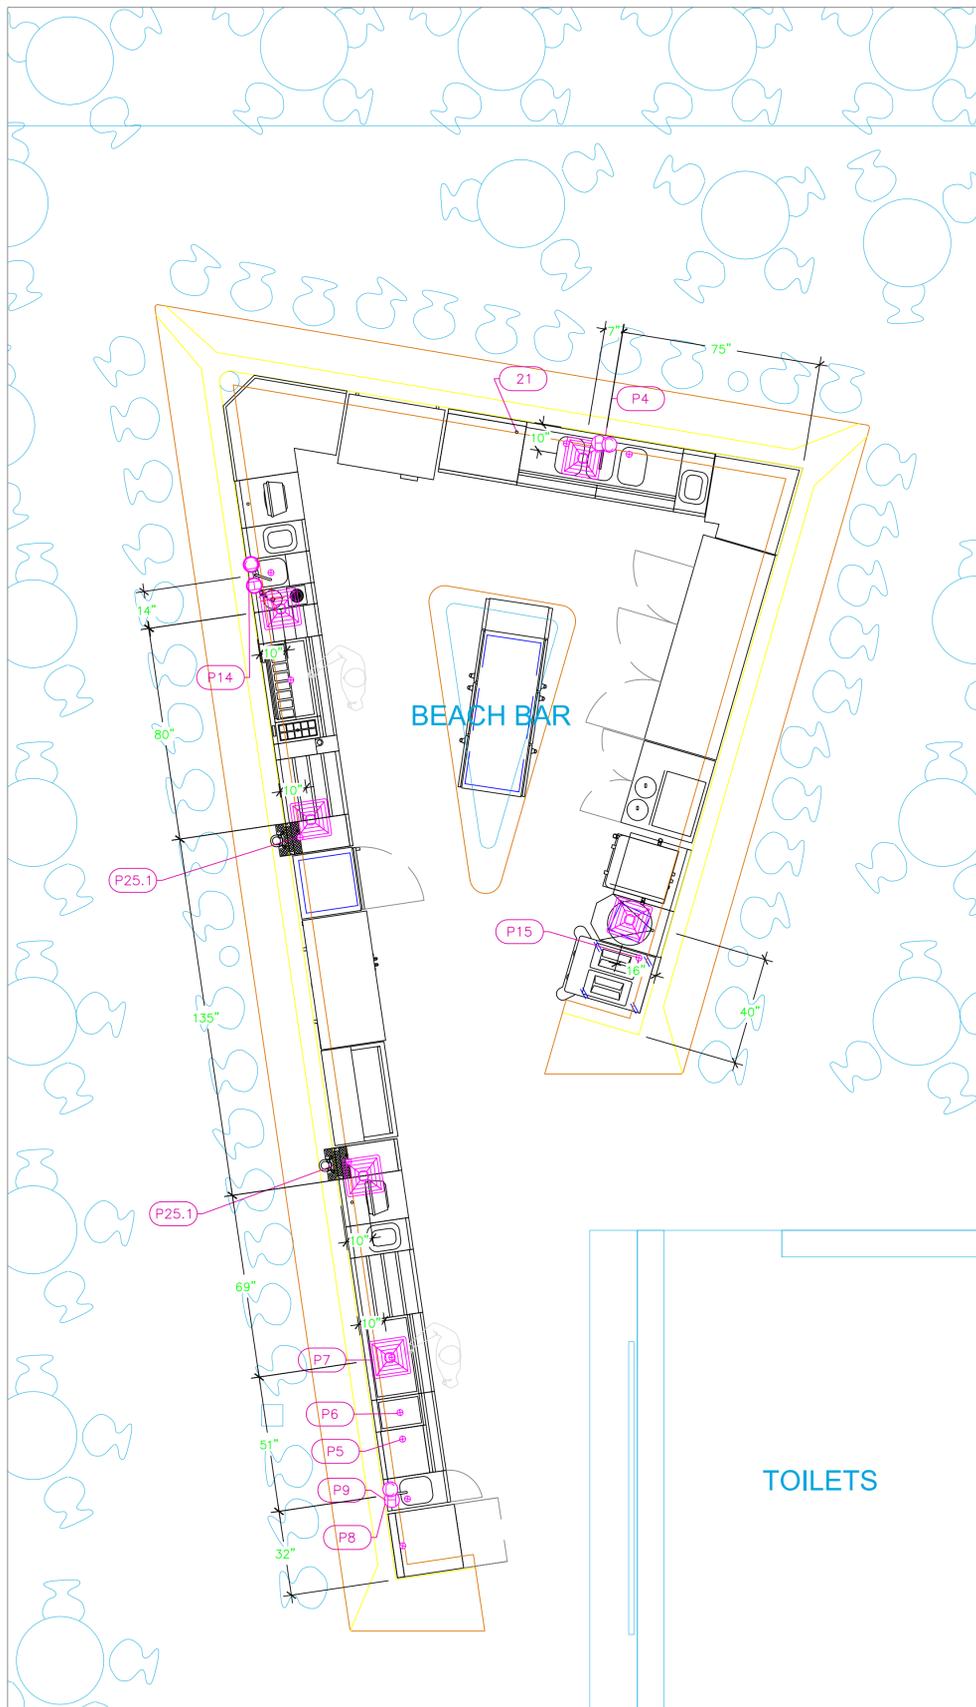

PLUMBING SCHEDULE											
ITEM NO.	DESCRIPTION	COLD WATER SIZE	HOT WATER SIZE	H&C Rough-In	DIRECT WASTE SIZE	DIRECT WASTE AFF	INDIRECT WASTE SIZE	GAS SIZE (IN)	GAS METU	QTY	PLUMBING REMARKS
4	Underbar Sink Units	1/2"	1/2"	12"			(3) 1-1/2"			1	Waste to Floor Sink
5	Drainboard						1"			1	Waste to Floor Sink
6	Ice Bin						1"			1	Waste to Floor Sink
7	Ice Bin						1"			1	Waste to Floor Sink
8	Dishwasher, Undercounter	3/4"		12"			1-3/8" OD			1	Water size note: 3/4" male GHT (connect to true 1/2" ID Line)
9	Hand Sink	1/2"	1/2"	12"	1"					1	
14	Cocktail Station	1/2"	1/2"	12"			1-1/2"			1	Waste to Floor Sink
19	Beer Drainer						1"			1	Waste to Floor Sink
19.1	Coffee Tea Brewer	3/8"		12"						1	
21	Drainboard						1"			1	Waste to Floor Sink
23	Drainboard						1"			2	Waste to Floor Sink
25	Draft Beer / Wine Dispensing Tower						1/2"			2	Waste to Floor Sink
25.1	Drip Tray						1/2"			2	Waste to Floor Sink

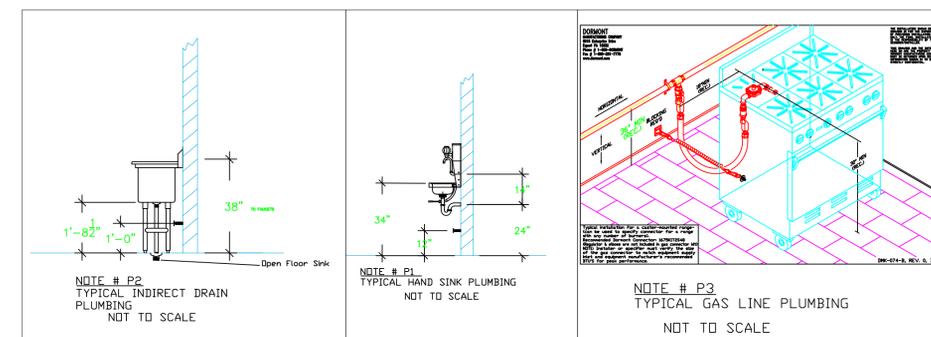

- LEGEND -- PLUMBING CONNECTIONS**
- HW-HOT WATER, OR CW-COLD WATER
  - GAS
  - WASTE, DIRECT-CONNECTED
  - WASTE, INDIRECT to Floor Sink, or Floor Dr
  - FUNNEL FLOOR DRAIN Josam 30000-E3
  - FLOOR DRAIN Josam 30000-A3
  - FLOOR SINK Zurn FD-2370-y-PV4-F
  - FILTERED WATER, at machine.

**NOTE # P4.**  
ALL NATIONAL, STATE, AND LOCAL CODES SHALL APPLY

**NOTE # P5.**  
ALL PLUMBING CONNECTIONS TO BE EXTENDED AND INTERCONNECTED TO EQUIPMENT AND ALL HARDWARE REQUIRED TO BE PROVIDED BY PLUMBING CONTRACTOR

**NOTE # P6.**  
PLUMBING CONTRACTOR TO VERIFY THAT ALL EQUIPMENT IS INSTALLED WITH THE APPROPRIATE GAS PRESSURE AND REGULATORS

**NOTE # P7.**  
ALL WASTE LINES AND CONDENSATE LINES TO BE EXTEND FROM EQUIPMENT TO FLOOR DRAINS BY PLUMBING CONTRACTOR.

## Equipment PLUMBING Service Requirements

All Dimensions to be verified on the job site. Actual locations for floor drains, and any ventilating equipment to be determined by Engineer. Mechanical, Plumbing & Electrical to be checked and verified by Customers MEP Engineer. Remote Condensing Units to be located by Architect. Exhaust & Supply fans to be located by Architect.

**Wymara Resorts & Villas**  
*Pink Bar*  
**Providenciales, T&C**

**WYMARA**  
RESORT AND VILLAS  
TURKS + CAICOS

**uni-source**  
SUPPLY  
INTERNATIONAL INC.

2055 W 73rd Street, Miami, FL 33016  
Ph:(305)826-8696 Fax:(305)826-9131

No.	Revision/Issue	Date
3	Added MEP Information	8-13-22
4	Update after comments from customer	8-15-22
5	Added MEP Dimensions	9-06-22
6	Added #27, adjusted beer conduit at #27, top cutout	9-07-22

Date  
**Sept 07, 2022**

Drawn By  
**Dayne Gauntlett**

Scale  
**3/8" = 1'0"**

Sheet  
**FS-4.1**