


**Baha Mar  
Podcast Studio  
Nassau, Bahamas**



INTERNATIONAL INC.

2055 W 73rd Street, Miami, FL 33016  
Ph: (305)826-8696 Fax: (305)826-9131

EQUIPMENT SCHEDULE					
ItemNo	Category	Mfr	Model	Quantity	Equipment Remarks
1	Undermount Sink	Advance Tabco	1014A-10	1	
1.1	Deck Mount Faucet	Krowne	15-408L	1	
2	Refrigerated Merchandiser	Everest Refrigeration	EMGR10B	1	
3	Blender, Bar	Hamilton Beach	HBH855	2	
4	Espresso Cappuccino Machine	Espresso Soci	E98 UP A/2	1	
4.1	Water Filtration System, Parts & Accessories	Krowne	KR-HS3-KIT	1	
5	Coffee Grinder	Espresso Soci	ENEA ON-DEMAND GRINDER	1	
6	Back Bar Cabinet, Refrigerated	Glastender	C1SL36-L-LR	1	
21	Comer Angle Filler	Krowne	KR24-DRC90	1	
22	Cocktail Station	Krowne	KR24-MX60-10	1	
23	Underbar Add-On Unit	Krowne	KR24-T12	1	
24	Work Center	Krowne	KR24-PC18	1	
25	Drainboard	Krowne	KR24-SD24	1	
26	Glasswasher, Undercounter / Underbar	Krowne	GWH-24	1	
27	Waste Cabinet	Krowne	KR24-SD12C	1	
28	Back Bar Cabinet, Refrigerated	Glastender	C1SL48-L-LR	1	
31	Display Case, Pastry, Countertop	Cal-Mil	22323-55	1	
32	Ice Maker, Cube-Style	Hoshizaki	IM-500SAB	1	
	Ice Bin for Ice Machines	Hoshizaki	B-700SF	1	
32.1	Water Filtration System, Parts & Accessories	Krowne	KR-HS3-KIT	1	
33	Shelving Unit, All Plastic	Quantum	QP183650VS-5	1	
34	Reach-In Refrigerator	Continental Refrigerator	2RESN	1	
35	Work Table, Cabinet Base Hinged Doors	Advance Tabco	HK-SS-307M	1	
36	Shelving, Wall Mounted	Advance Tabco	WS-15-84-16-X	2	
37	Undercounter Refrigerator	Continental Refrigerator	UC24SN	1	

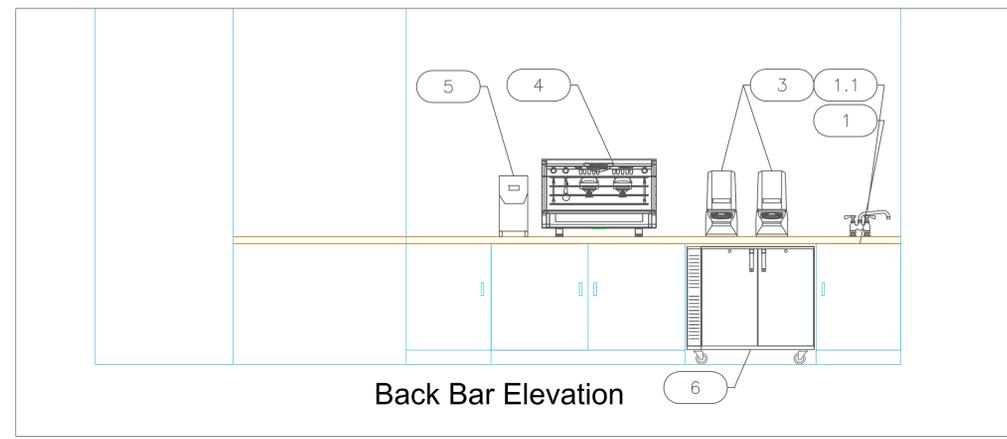

Back Bar Elevation


# EQUIPMENT LAYOUT

All Dimensions to be verified on the job site.  
Actual locations for floor drains, and any ventilating equipment to be determined by Engineer.  
Mechanical, Plumbing & Electrical to be checked and verified by Customers MEP Engineer.  
Remote Condensing Units to be located by Architect.  
Exhaust & Supply fans to be located by Architect.

No.	Revision/Issue	Date
5	Added Equipment modifications.	8-21-25
6	Added 1 additional item #2	9-11-25
7	Added equipment modifications	12-5-25
8	Added equipment modifications	01-8-25

Date  
**Jan 8, 2026**  
Drawn By  
**Dayne Gauntlett**  
Scale  
**1/2" = 1'0"**

Sheet  
**FS-1.0**

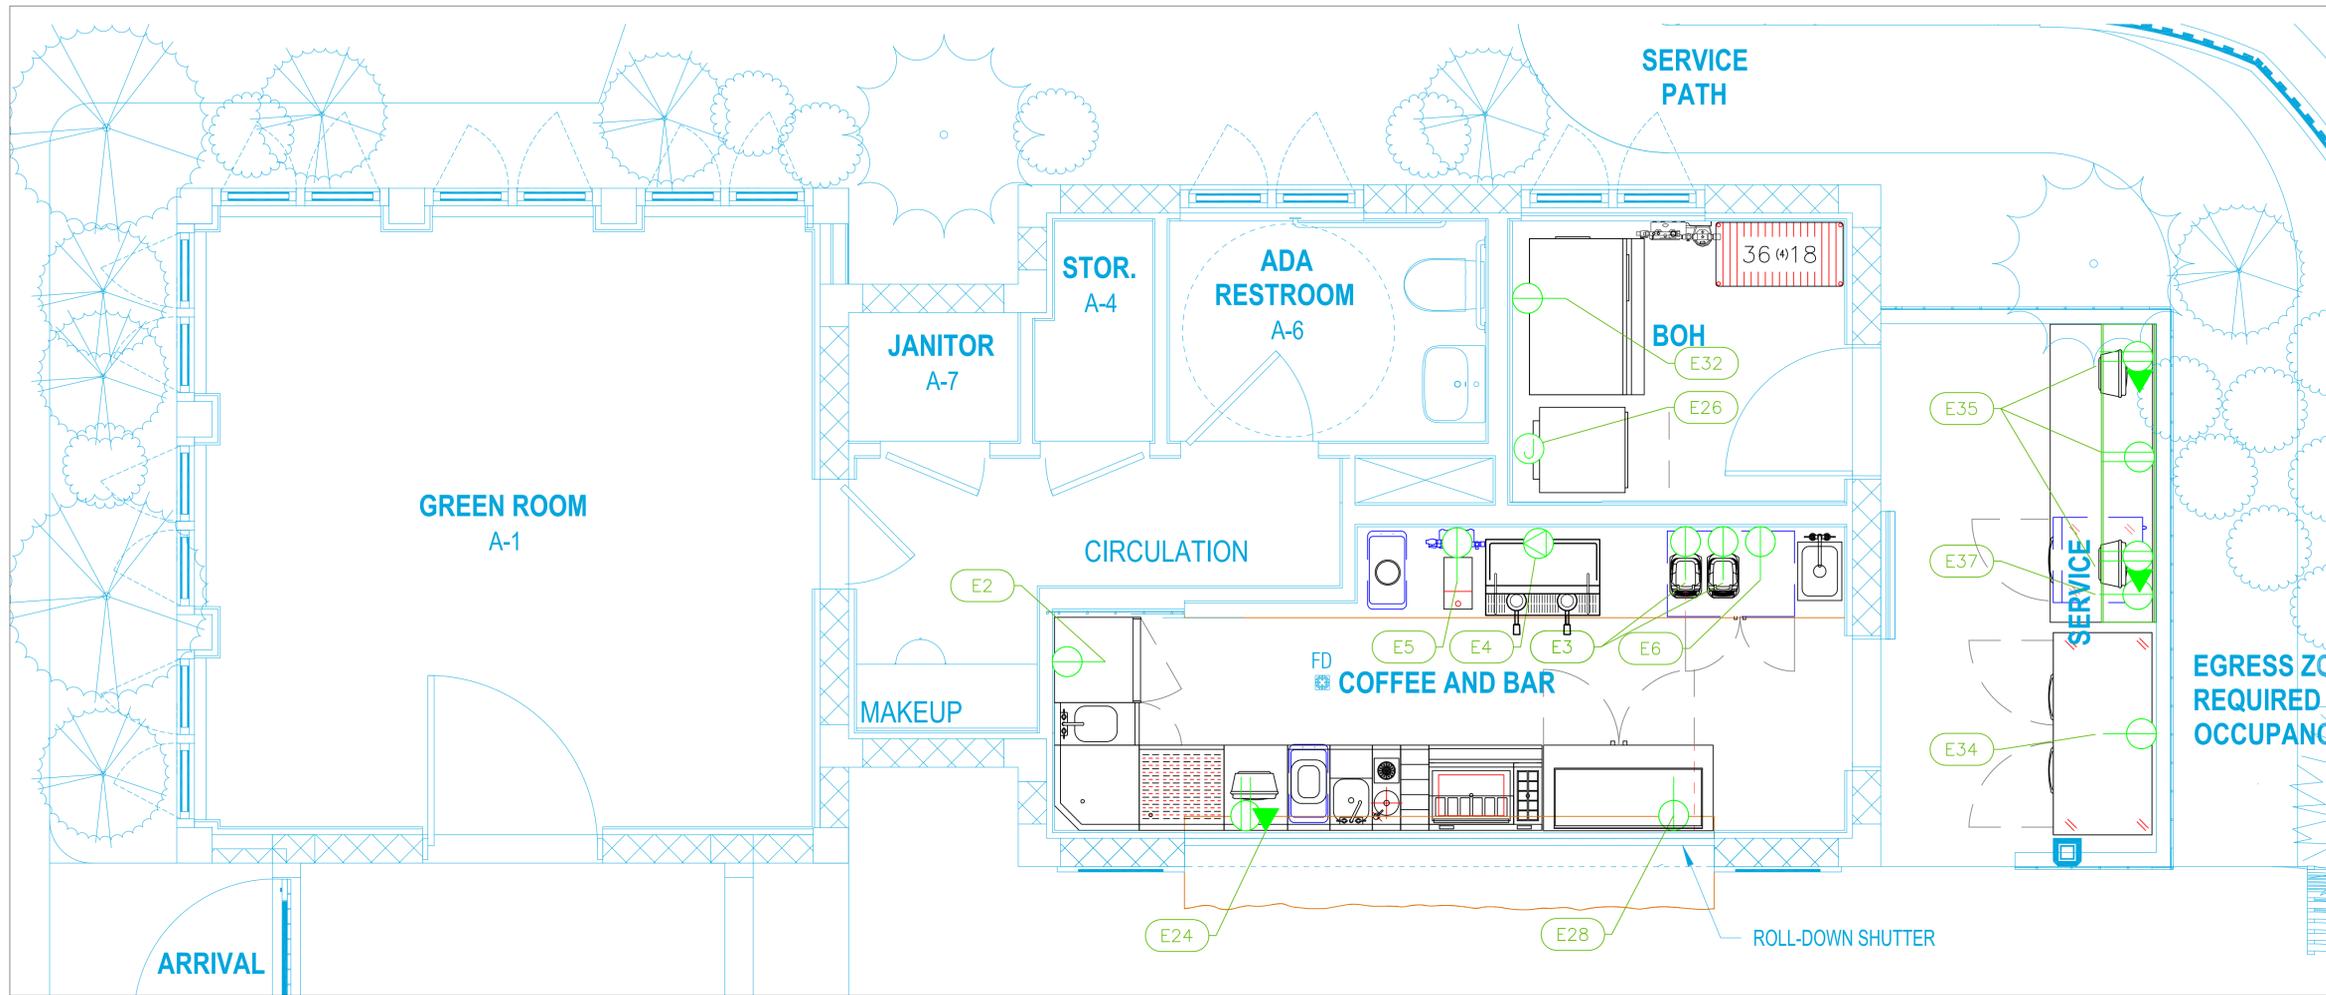

**Baha Mar**  
Podcast Studio  
Nassau, Bahamas




2055 W 73rd Street, Miami, FL 33016  
Ph:(305)826-8696 Fax:(305)826-9131

ELECTRICAL SCHEDULE												
ItemNo	Category	Voltage	Cycle	Phase	Amps	Hp	NEMA	ConnectionType	Rough-In AFF	Quantity	Electrical Remarks	
2	Refrigerated Merchandiser	115	60	1	2.5	1/4	5-15P	Simplex	48"	1		
3	Blender, Bar	120	60	1	13.5	3		Simplex	48"	2		
4	Espresso Cappuccino Machine	220	60	1				Special	48"	1		
5	Coffee Grinder	110	60	1				Simplex	48"	1		
6	Back Bar Cabinet, Refrigerated	120	60	1	2.75	1/8	5-15P	Simplex	18"	1		
24	Work Center	120	60	1	15			Duplex	18"	1		
								DATA	18"	1		
26	Glasswasher, Undercounter / Underbar	208-240	60	1	32			J-Box	18"	1		
28	Back Bar Cabinet, Refrigerated	120	60	1	2.75	1/8	5-15P	Simplex	18"	1		
32	Ice Maker, Cube-Style	115	60	1	11.5			Simplex	18"	1		
34	Reach-In Refrigerator	115	60	1	7.5	1/3	5-15P	Simplex	18"	1		
35	Work Table, Cabinet Base Hinged Doors	115	60	1	15			Duplex	48"	1		
								DATA	48"	1		
		115	60	1	15			Duplex	48"	1		
37	Undercounter Refrigerator	115	60	1	2.2	1/5	5-15P	Simplex	18"	1		

**LEGEND - ELECTRICAL CONNECTIONS**

- DUPLEX RECEPT., 15-AMP, 120-VOLT, GROUND TYPE, HORIZONTAL MOUNT
- SIMPLEX RECEPT., 120-VOLT, GROUND TYPE, HORIZONTAL MOUNT
- SPECIAL PURPOSE OUTLET, GROUND TYPE, HORIZONTAL MOUNT
- JUNCTION BOX, DIRECT CONNECTION
- DISCONNECT SWITCH, DIRECT CONNECTION
- FLOOR/CEILING RECEPTACLE AS INDICATED
- (2) Telephone + (2) Data
- FIELD CONNECTIONS
- HARD WIRE CONNECTION POINT AT MACHINE

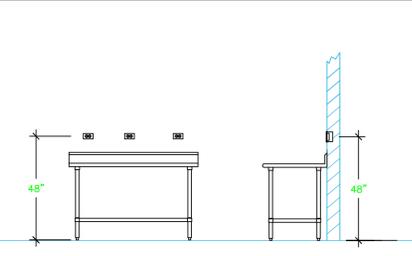

**NOTE # E2.**  
ALL NATIONAL, STATE, AND LOCAL CODES SHALL APPLY.

**NOTE # E3.**  
ALL ELECTRICAL CONNECTIONS AND HARDWARE REQUIRED TO BE PROVIDED BY ELECTRICAL CONTRACTOR.

**NOTE # E4.**  
ALL JUNCTION BOXES, OUTLETS, ETC. TO BE LOCATED SO AS TO NOT INTERFERE WITH EQUIPMENT.

**NOTE # E5.**  
ALL RELAYS, CONTRACTORS, STARTERS, AND SWITCHES REQUIRED FOR EXHAUST & SUPPLY FANS TO BE PROVIDED BY ELECTRICAL CONTRACTOR UNLESS SPECIFIED.

**NOTE # E6.**  
ELECTRICAL CONTRACTOR TO INTERCONNECT DISHMACHINE TO EXHAUST FAN FOR DISHMACHINE SO THAT THE FAN RUNS WHEN THE DISHMACHINE IS IN OPERATION.

**NOTE # E7.**  
ELECTRICAL CONTRACTOR TO INSTALL TABLE LIMIT SWITCH TO END OF CLEAN DISHABLE TO THAT MACHINE STOPS WHEN SWITCH IS DEPRESSED.

**NOTE # E8.**  
ELECTRICAL CONTRACTOR TO CONNECT DRAIN LINE HEATER, PAN HEATER AND DDBR HEATER FOR WALK-IN FREEZER.

## Equipment ELECTRICAL Service Requirements

All Dimensions to be verified on the job site. Actual locations for floor drains, and any ventilating equipment to be determined by Engineer. Mechanical, Plumbing & Electrical to be checked and verified by Customers MEP Engineer. Remote Condensing Units to be located by Architect. Exhaust & Supply fans to be located by Architect.


No.	Revision/Issue	Date
5	Added Equipment modifications.	8-21-25
6	Added 1 additional item #2	9-11-25
7	Added equipment modifications	12-5-25
8	Added equipment modifications	01-8-25

Date  
**Jan 8, 2026**

Drawn By  
**Dayne Gauntlett**

Scale  
**1/2" = 1'0"**

Sheet  
**FS-3.1**



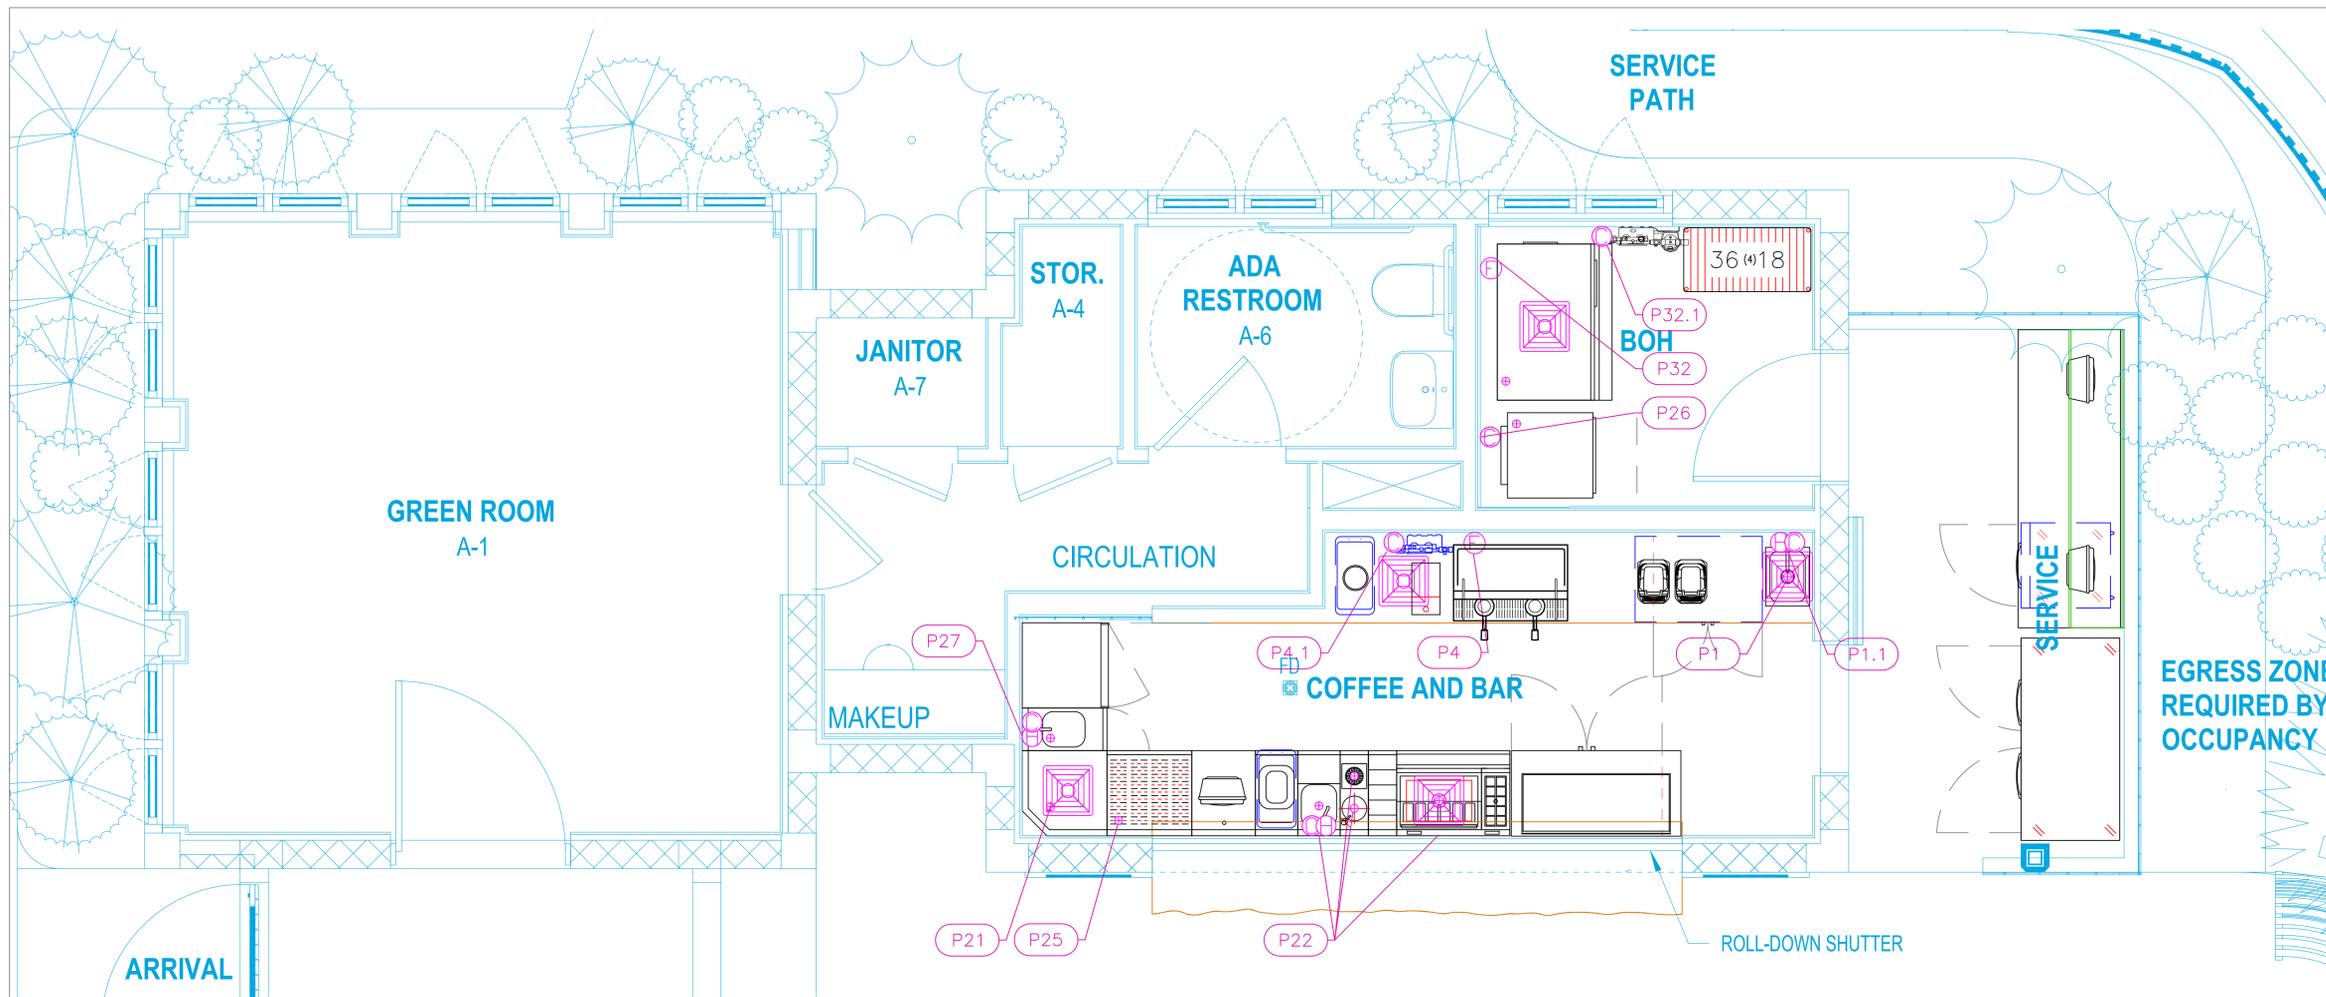


Baha Mar  
Podcast Studio  
Nassau, Bahamas

INTERNATIONAL INC.

2055 W 73rd Street, Miami, FL 33016  
Ph:(305)826-8696 Fax:(305)826-9131

PLUMBING SCHEDULE											
ITEM NO.	DESCRIPTION	COLD WATER SIZE	HOT WATER SIZE	H&C Rough-In	DIRECT WASTE SIZE	DIRECT WASTE AFF	INDIRECT WASTE SIZE	GAS SIZE(IN)	GAS MBTU	QTY	PLUMBING REMARKS
1	Undermount Sink						1-1/2"			1	Waste to Floor Sink
1.1	Deck Mount Faucet	1/2"	1/2"	12"						1	
4	Espresso Cappuccino Machine	3/8"		n/a						1	Water from filter
4.1	Water Filtration System, Parts & Accessories	1/2"		12"						1	Water to Coffee Machine
21	Corner Angle Filler						1"			1	Drainboard drain
22	Cocktail Station	1/2"	1/2"	12"			1-1/2"			1	Waste to Floor Sink
25	Drainboard						1"			1	Drainboard drain
26	Glasswasher, Undercounter / Underbar	1/2"		12"			5/8"			1	Waste to Floor Sink
27	Waste Cabinet	1/2"	1/2"	12"	1"		1"			1	Waste to Floor Sink
32	Ice Maker, Cube-Style	1/2"		n/a			3/4"			1	Water from Filter
	Ice Bin for Ice Machines						3/4"			1	Waste to Floor Sink
32.1	Water Filtration System, Parts & Accessories	1/2"		12"						1	

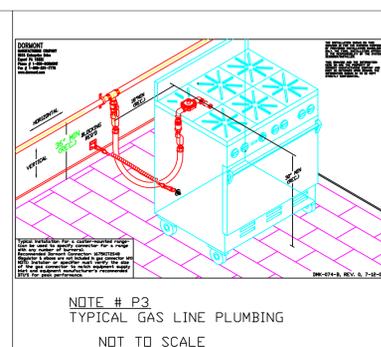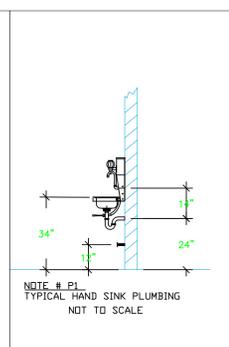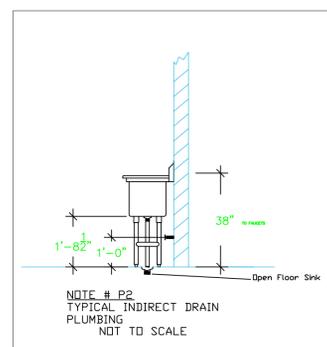

**LEGEND -- PLUMBING CONNECTIONS**

- HW--HOT WATER, OR CW--COLD WATER
- GAS
- WASTE, DIRECT-CONNECTED
- WASTE, INDIRECT to Floor Sink, or Floor Drain
- ⊕ FUNNEL FLOOR DRAIN Josam 30000-E3
- ⊕ FLOOR DRAIN Josam 30000-A3
- ⊕ FLOOR SINK Proflo PF42856 or Zurn FS12
- ⊕ FILTERED WATER, at machine.

NOTE # P4.  
ALL NATIONAL, STATE, AND LOCAL CODES SHALL APPLY

NOTE # P5.  
ALL PLUMBING CONNECTIONS TO BE EXTENDED AND INTERCONNECTED TO EQUIPMENT AND ALL HARDWARE REQUIRED TO BE PROVIDED BY PLUMBING CONTRACTOR

NOTE # P6.  
PLUMBING CONTRACTOR TO VERIFY THAT ALL EQUIPMENT IS INSTALLED WITH THE APPROPRIATE GAS PRESSURE AND REGULATORS

NOTE # P7.  
ALL WASTE LINES AND CONDENSATE LINES TO BE EXTEND FROM EQUIPMENT TO FLOOR DRAINS BY PLUMBING CONTRACTOR.

## Equipment PLUMBING Service Requirements

All Dimensions to be verified on the job site. Actual locations for floor drains, and any ventilating equipment to be determined by Engineer. Mechanical, Plumbing & Electrical to be checked and verified by Customers MEP Engineer. Remote Condensing Units to be located by Architect. Exhaust & Supply fans to be located by Architect.

5	Added Equipment modifications.	8-21-25
6	Added 1 additional item #2	9-11-25
7	Added equipment modifications	12-5-25
8	Added equipment modifications	01-8-25
No.	Revision/Issue	Date

Date  
**Jan 8, 2026**  
Drawn By  
**Dayne Gauntlett**  
Scale  
**1/2" = 1'0"**

Sheet  
**FS-4.1**