
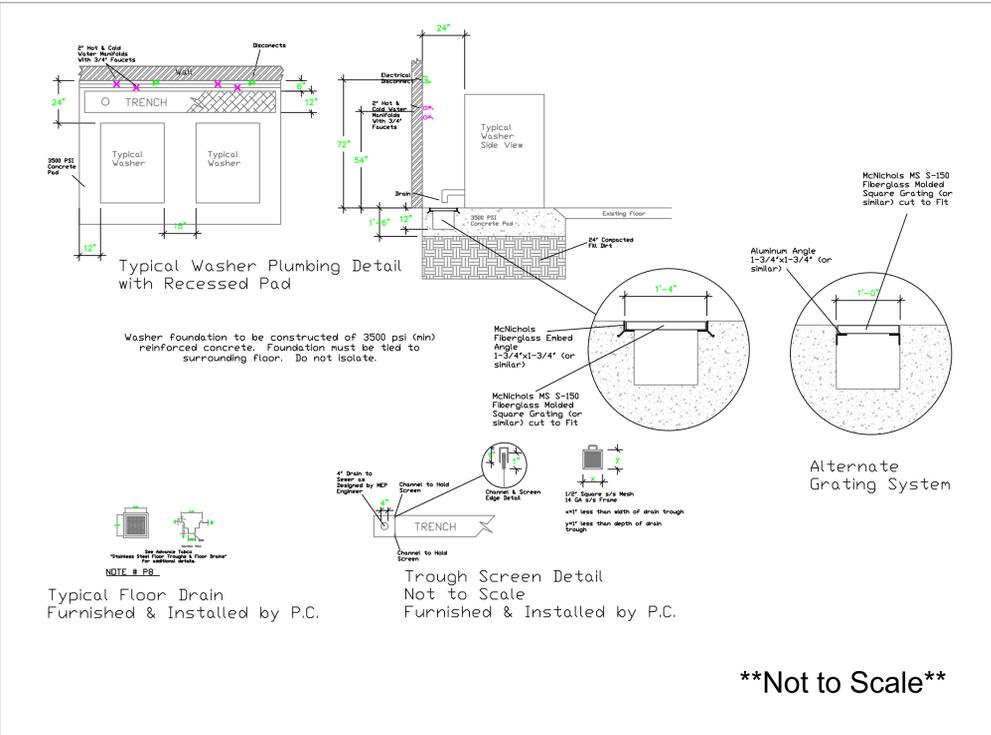


Laundry

EQUIPMENT SCHEDULE

ItemNo	Category	Mfr	Model	Quantity	Equipment Remarks
1	Laundry Dryer	UNIMAC	UTT30LFN0RXG6W0000	1	
2	Cabinet Hardmount Washer Extractor	UNIMAC	UCT020QN0FXU70B000	2	
2.1	Chemical Pump	Ecolab	CHEM	2	
3	Laundry Washer / Dryer Combo	UNIMAC	LTEE5ASP175TW01	1	
5	Microwave Oven, Shelf	Advance Tabco	MS-18-24	1	
5.1	Mini Boiler & Iron	EuroFinish	MVP-35B	1	
6	Laundry Ironer	UNIMAC	I25-120V-M	1	
7	One (1) Compartment Sink	Advance Tabco	FC-1-1818	1	
7.1	Wall / Splash Mount Faucet	Krowne	14-810L	1	
7.2	Shelving, Wall Mounted	Advance Tabco	WS-12-24	1	
8	Work Table, Stainless Steel Top	Advance Tabco	KMS-366	1	
21	Shelving Unit, Wire	Quantum	WR63-1848GY	3	
	Shelving Unit, Wire	Quantum	WR63-1836GY	3	

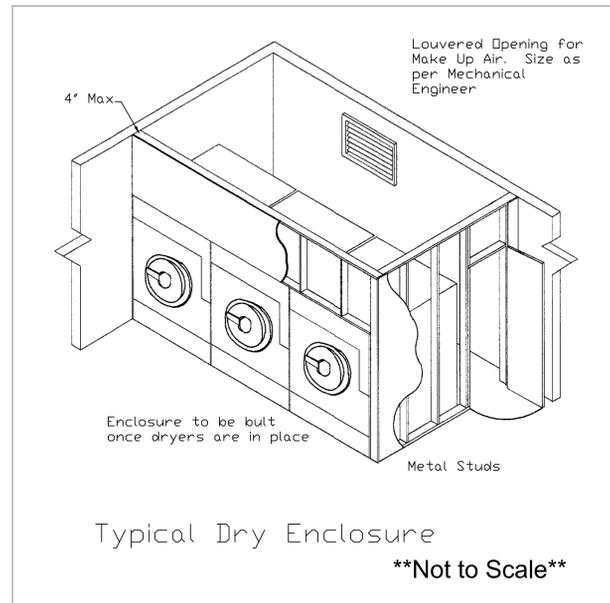

EQUIPMENT LAYOUT

All Dimensions to be verified on the job site. Actual locations for floor drains, and any ventilating equipment to be determined by Engineer. Mechanical, Plumbing & Electrical to be checked and verified by Customers MEP Engineer. Remote Condensing Units to be located by Architect. Exhaust & Supply fans to be located by Architect.

Beach House Laundry
Providenciales, T&C




INTERNATIONAL INC.
2055 W 73rd Street, Miami, FL 33016
Ph: (305)826-8696 Fax: (305)826-9131


1	Preliminary Layout	5-7-23
2	Added Ironer	6-26-23
3	Added MEP Equipment Requirements	5-31-24
4		
No.	Revision/Issue	Date

Date
May 31, 2024
Drawn By
Dayne Gauntlett
Scale
1/2" = 1'0"


Sheet
LA-1

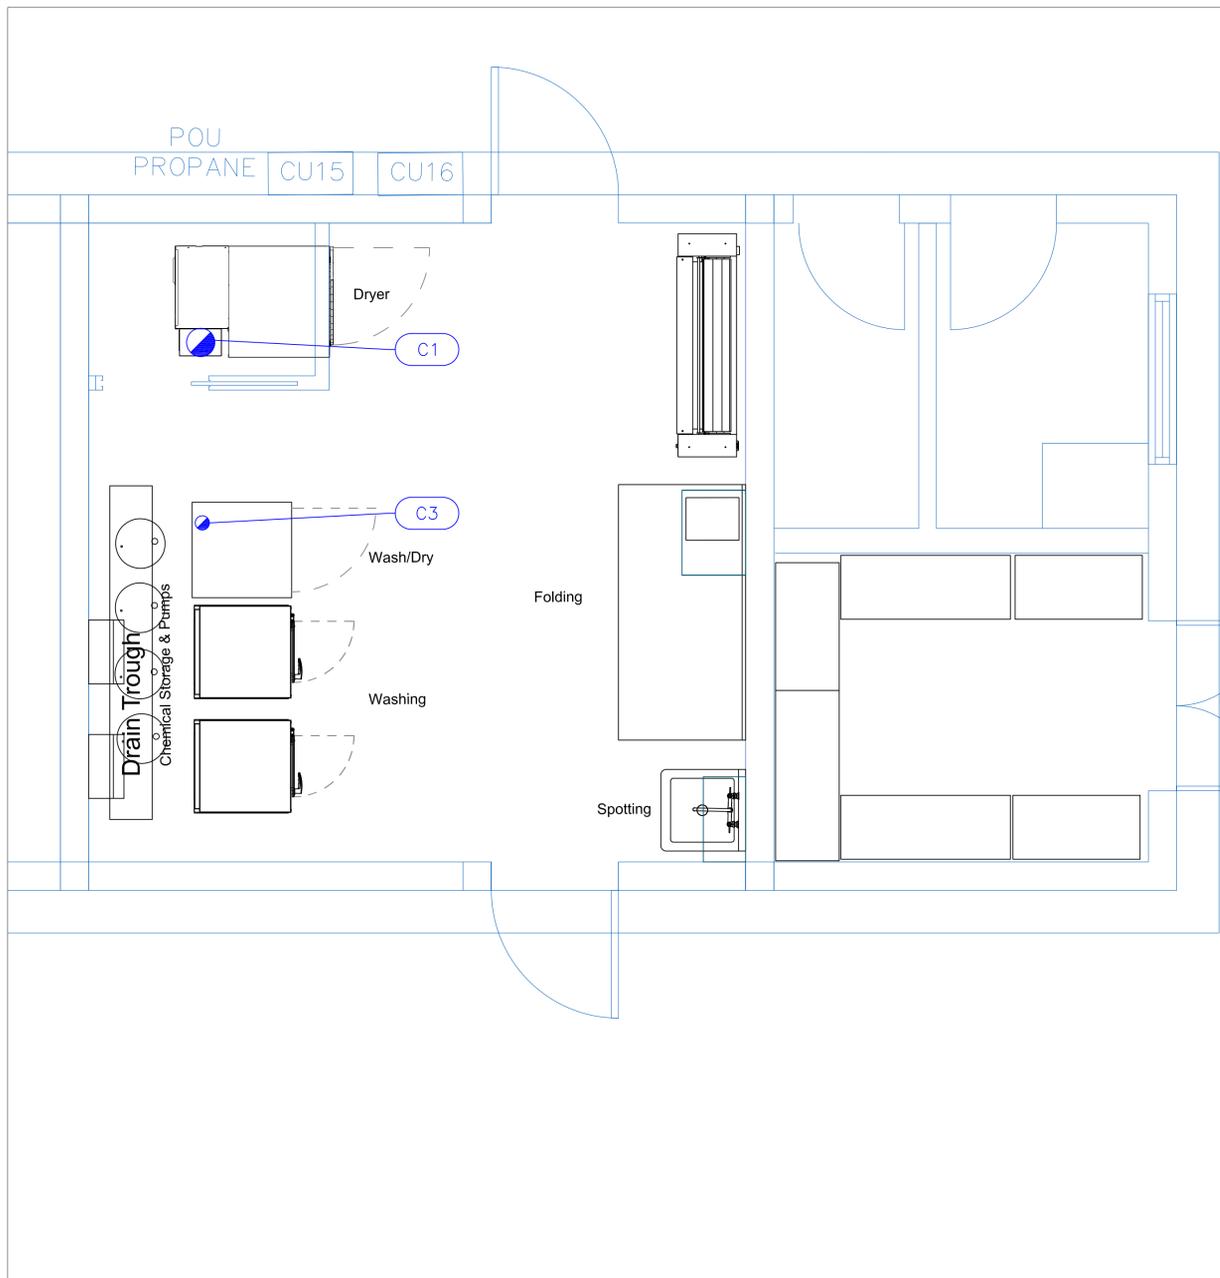

Mechanical Schedule								
ITEM NO.	QTY	DISCRIPTION	EXHAUST (L X W)	EXHAUST (CFM)	SUPPLY (L X W)	SUPPLY (CFM)	Ventilation Remarks	Unit
1	1	Laundry Dryer	(1) 8" Dia	(2) 400				ea
3	1	Laundry Washer / Dryer Combo	(1) 4" Dia	(1) 220				ea

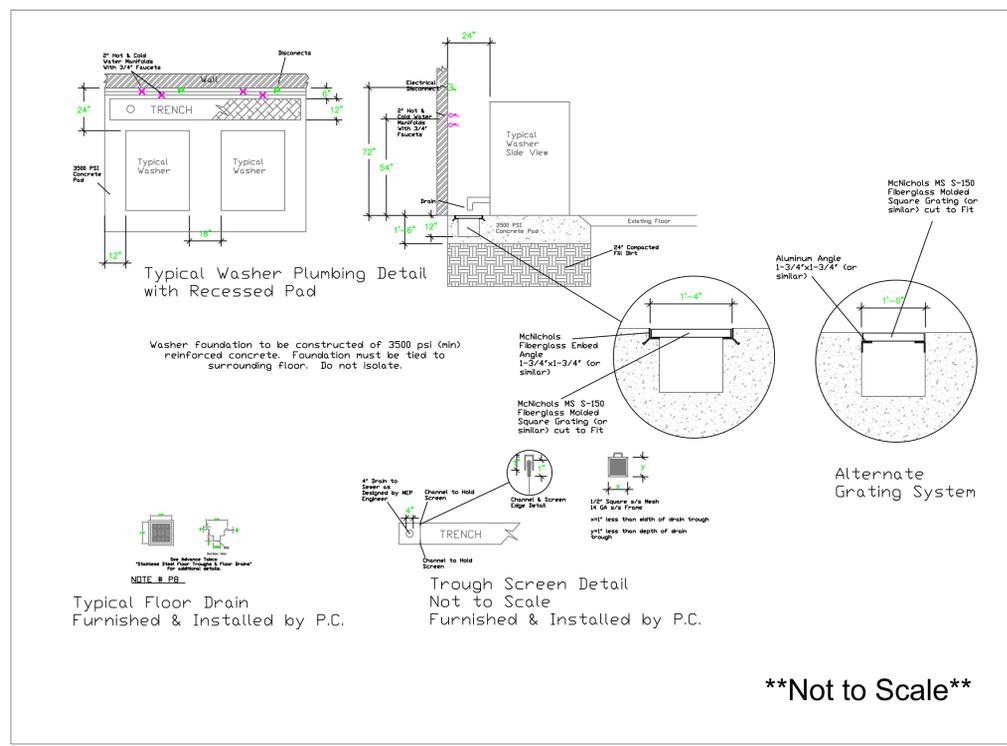

****Not to Scale****

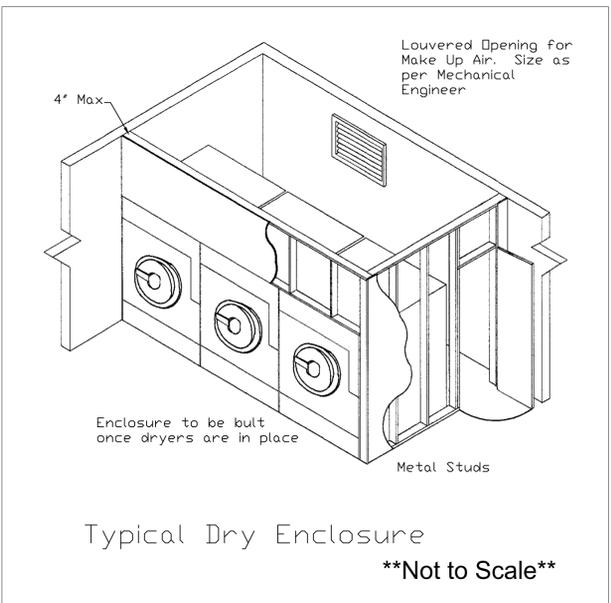

LEGEND - MECHANICAL

- EXHAUST DUCT COLLAR
- SUPPLY DUCT COLLAR
- INWALL BACKING FOR WALL SHELVES
- RECESSED FLOOR
- RAISED EQUIPMENT PAD

Equipment MECHANICAL Service Requirements

All Dimensions to be verified on the job site. Actual locations for floor drains, and any ventilating equipment to be determined by Engineer. Mechanical, Plumbing & Electrical to be checked and verified by Customers MEP Engineer. Remote Condensing Units to be located by Architect. Exhaust & Supply Fans to be located by Architect.

- NOTE # M5: ALL NATIONAL, STATE, AND LOCAL CODES SHALL APPLY.
- NOTE # M6: ARCHITECT OR ENGINEER TO SIZE AND LOCATE, CONTRACTOR TO PROVIDE ALL OPENINGS FOR DUCTS, PLUMBING LINES, ELECTRICAL LINES, AND REFRIGERATION LINES, AS REQUIRED BY EQUIPMENT.
- NOTE # M7: SUPPLY FANS TO BE LOCATED A MINIMUM OF 10' FROM EXHAUST FANS.
- NOTE # M8: SHOP DRAWING WILL BE PROVIDED BY MANUFACTURER FOR HEAD, EXHAUST FANS, & SUPPLY FANS, UNCE ORDER IS PLACE WITH.
- NOTE # M9: GENERAL CONTRACTOR TO PROVIDE 2" PLYWOOD WALL BACKING FROM 48" TO 78" AFF FOR ALL WALL MOUNTED EQUIPMENT.
- NOTE # M10: CEILING HEIGHTS TO BE VERIFIED FOR SUFFICIENT CLARENCE FOR EQUIPMENT.
- NOTE # M11: REFRIGERATION CONTRACTOR TO HANG EVAPORATORS FOR WALK-IN, RUN & CHARGE LINES BETWEEN EVAP. & CONDENSING UNIT.

Beach House Laundry
Providenciales, T&C




INTERNATIONAL INC.
2055 W 73rd Street, Miami, FL 33016
Ph:(305)826-8696 Fax:(305)826-9131

No.	Revision/Issue	Date
1	Preliminary Layout	6-7-23
2	Added Ironer	6-26-23
3	Added MEP Equipment Requirements	5-31-24
4		

Date
May 31, 2024
Drawn By
Dayne Gauntlett
Scale
1/2" = 1'0"


Sheet
LA-2

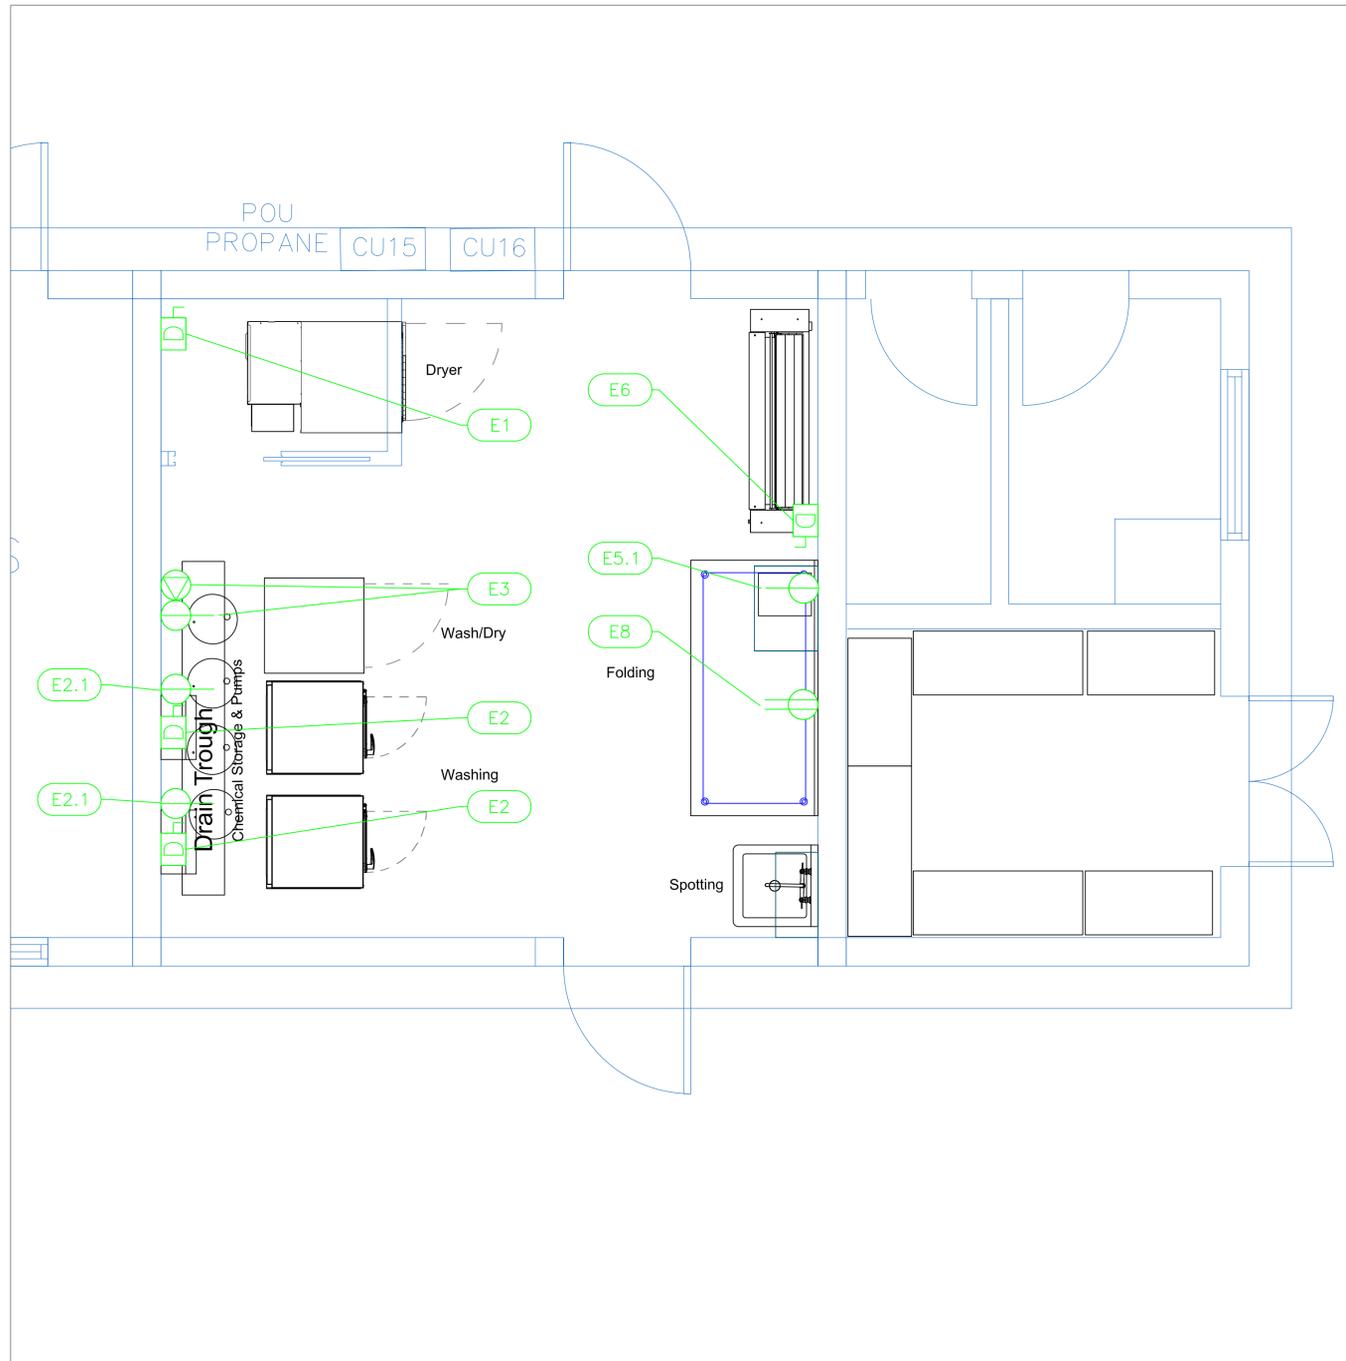

ELECTRICAL SCHEDULE											
ItemNo	Category	Voltage	Cycle	Phase	Amps	Hp	ConnectionType	Rough-In AFF	Quantity	Electrical Remarks	Unit
1	Laundry Dryer	120/208	60	1	16 / 8.0		Disconnect	72"	1		ea
2	Cabinet Hardmount Washer Extractor	208	60	1	6.0		Disconnect	72"	2		ea
2.1	Chemical Pump	120	60	1	15		Simplex	36"	2		ea
3	Laundry Washer / Dryer Combo	120	60	1	15		Simplex	72"	1	Washer	ea
		208	60	1	30		Special	72"	1	Dryer	ea
5.1	Mini Boiler & Iron	115	60	1	15		Simplex	18"	1		ea
6	Laundry Ironer	230	60	1	16		Disconnect	48"	1		ea
8	Work Table, Stainless Steel Top	115	60	1	15		Duplex	48"	1	Convenience Outlet, See Note E1	ea

LEGEND - ELECTRICAL CONNECTIONS

- DUPLEX RECEPT., 15-AMP, 120-VOLT, GROUND TYPE, HORIZONTAL MOUNT
- SIMPLEX RECEPT., 120-VOLT, GROUND TYPE, HORIZONTAL MOUNT
- SPECIAL PURPOSE OUTLET, GROUND TYPE, HORIZONTAL MOUNT
- JUNCTION BOX, DIRECT CONNECTION
- DISCONNECT SWITCH, DIRECT CONNECTION
- FLOOR/CEILING RECEPTACLE AS INDICATED
- (2) Telephone + (2) Data
- FIELD CONNECTIONS
- HARD WIRE CONNECTION POINT AT MACHINE

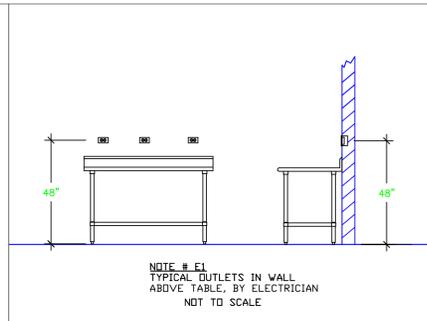

NOTE # E2
ALL NATIONAL, STATE, AND LOCAL CODES SHALL APPLY

NOTE # E3
ALL ELECTRICAL CONNECTIONS AND HARDWARE REQUIRED TO BE PROVIDED BY ELECTRICAL CONTRACTOR

NOTE # E4
ALL JUNCTION BOXES, OUTLETS, ETC. TO BE LOCATED SO AS TO NOT INTERFERE WITH EQUIPMENT

NOTE # E5
ALL RELAYS, CONTRACTORS, STARTERS, AND SWITCHES REQUIRED FOR EXHAUST & SUPPLY FANS TO BE PROVIDED BY ELECTRICAL CONTRACTOR UNLESS SPECIFIED

NOTE # E6
ELECTRICAL CONTRACTOR TO INTERCONNECT DISHMACHINE TO EXHAUST FAN FOR DISHMACHINE SO THAT THE FAN RUNS WHEN THE DISHMACHINE IS IN OPERATION.

NOTE # E7
ELECTRICAL CONTRACTOR TO INSTALL TABLE LIMIT SWITCH TO END OF CLEAN DISHTABLE TO THAT MACHINE STOPS WHEN SWITCH IS DEPRESSED.

NOTE # E8
ELECTRICAL CONTRACTOR TO CONNECT DRAIN LINE HEATER, PAN HEATER AND DDDR HEATER FOR WALK-IN FREEZER.

Equipment ELECTRICAL Service Requirements

All Dimensions to be verified on the job site. Actual locations for floor drains, and any ventilating equipment to be determined by Engineer. Mechanical, Plumbing & Electrical to be checked and verified by Customers MEP Engineer. Remote Condensing Units to be located by Architect. Exhaust & Supply fans to be located by Architect.

**Beach House
Laundry**
Providenciales, T&C





INTERNATIONAL INC.
2055 W 73rd Street, Miami, FL 33016
Ph:(305)826-8696 Fax:(305)826-9131

1	Preliminary Layout	6-7-23
2	Added Ironer	6-26-23
3	Added MEP Equipment Requirements.	5-31-24
4		
No.	Revision/Issue	Date

Date
May 31, 2024
Drawn By
Dayne Gauntlett
Scale
1/2" = 1'0"

Sheet
LA-3

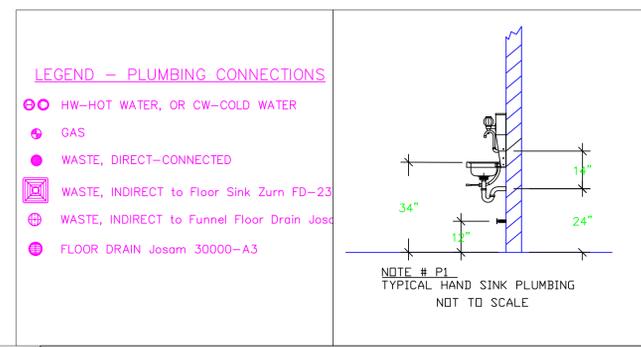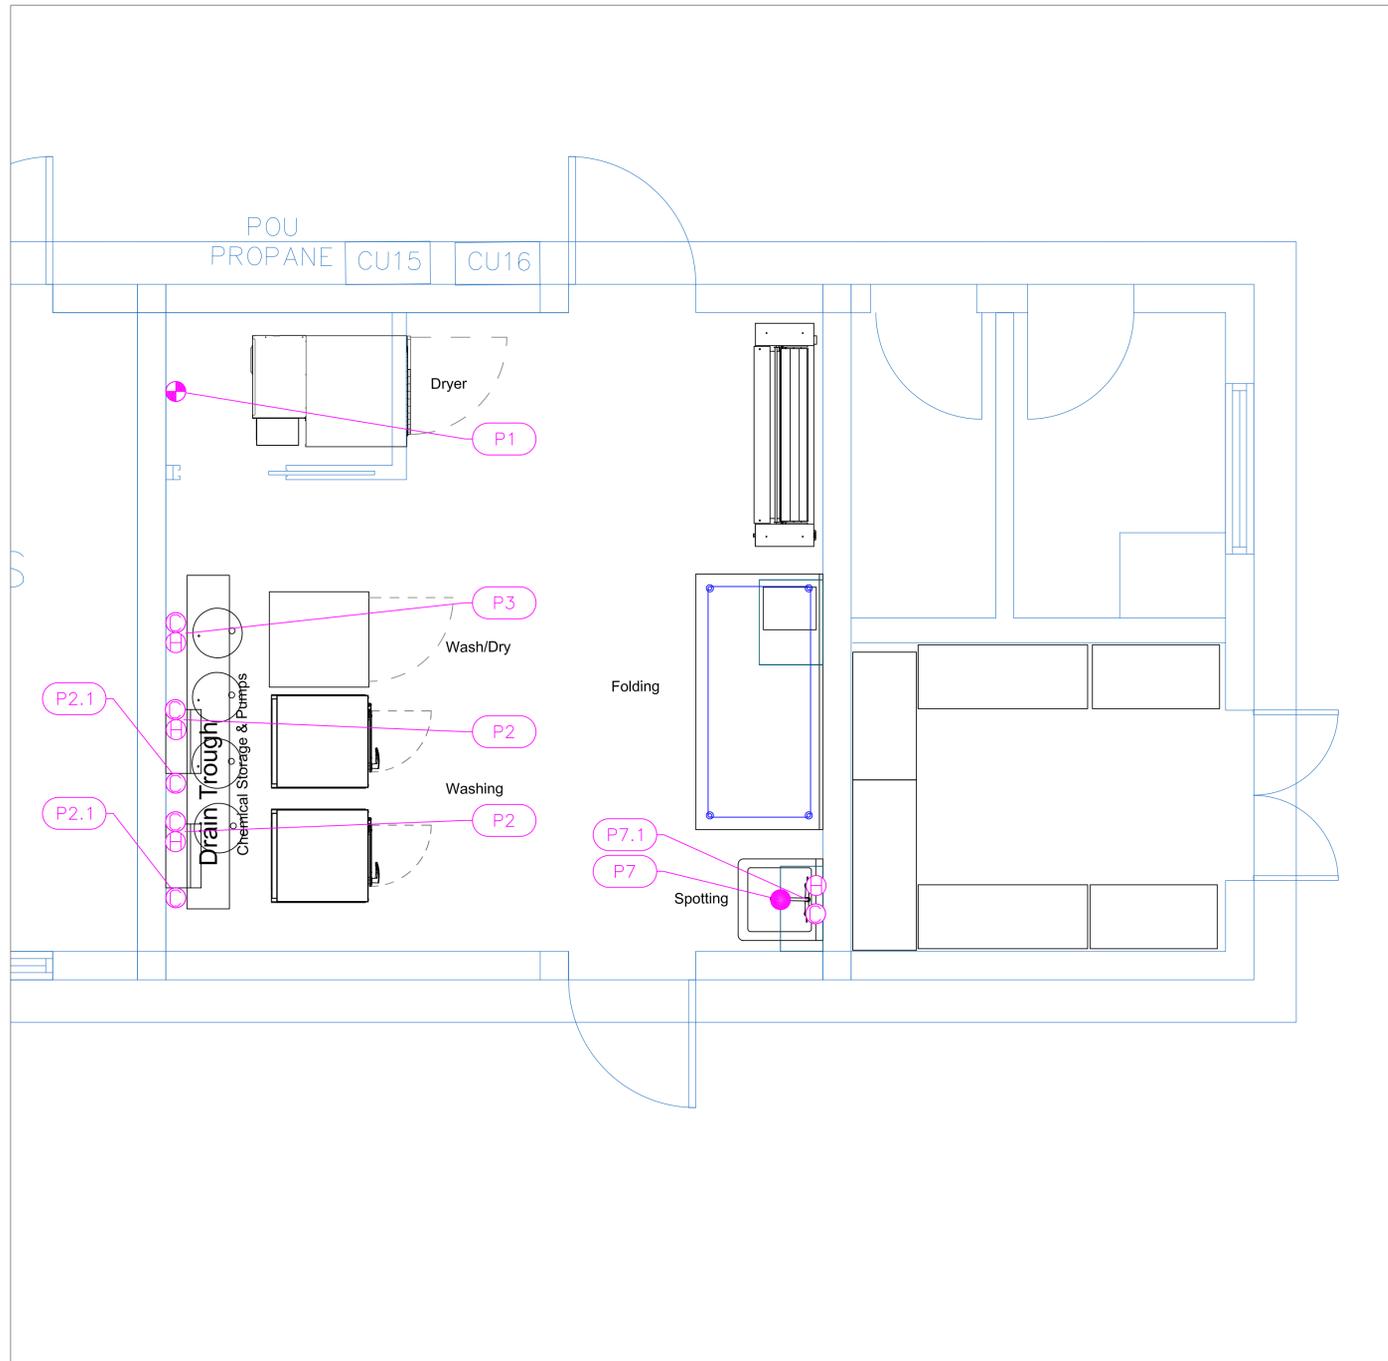

PLUMBING SCHEDULE												
ITEM NO.	DESCRIPTION	COLD WATER SIZE	HOT WATER SIZE	H&C Rough-In	DIRECT WASTE SIZE	DIRECT WASTE AFF	INDIRECT WASTE SIZE	GAS SIZE(IN)	GAS CONN. AFF	GAS MBTU	QTY	PLUMBING REMARKS
1	Laundry Dryer							1/2"	36"	73.0	1	
2	Cabinet Hardmount Washer Extractor	3/4"	3/4"	54"							2	
2.1	Chemical Pump	5/8"		24"							2	Garden Hose Bib
3	Laundry Washer / Dryer Combo	3/4"	3/4"	54"							1	
7	One (1) Compartment Sink						1-1/2				1	(1) set of 1/2" faucet holes, 8" OC
7.1	Wall / Splash Mount Faucet	1/2"	1/2"	12"							1	

NOTE # P4.
ALL NATIONAL, STATE, AND LOCAL CODES SHALL APPLY

NOTE # P5.
ALL PLUMBING CONNECTIONS TO BE EXTENDED AND INTERCONNECTED TO EQUIPMENT AND ALL HARDWARE REQUIRED TO BE PROVIDED BY PLUMBING CONTRACTOR

NOTE # P6.
PLUMBING CONTRACTOR TO VERIFY THAT ALL EQUIPMENT IS INSTALLED WITH THE APPROPRIATE GAS PRESSURE AND REGULATORS

NOTE # P7.
ALL WASTE LINES AND CONDENSATE LINES TO BE EXTEND FROM EQUIPMENT TO FLOOR DRAINS BY PLUMBING CONTRACTOR.

Equipment PLUMBING Service Requirements

Actual locations for floor drains, and any ventilating equipment to be determined by Engineer.
Mechanical, Plumbing & Electrical to be checked and verified by Customers MEP Engineer.
Remote Condensate Units to be located by Architect.
Exhaust & Supply fans to be located by Architect.

**Beach House
Laundry
Providenciales, T&C**

**uni-source
SUPPLY**
INTERNATIONAL INC.

2055 W 73rd Street, Miami, FL 33016
Ph:(305)826-8696 Fax:(305)826-9131

1	Preliminary Layout	5-7-23
2	Added Ironer	5-26-23
3	Added MEP Equipment Requirements.	5-31-24
4		
No.	Revision/Issue	Date

Date
May 31, 2024
Drawn By
Dayne Gauntlett
Scale
1/2" = 1'0"

Sheet
LA-4