


EQUIPMENT SCHEDULE					
ItemNo	Category	Mfr	Model	Quantity	Equipment Remarks
1	Washer Extractor	UNIMAC	UWL065K2M	2	
2	Washer Extractor	UNIMAC	UWL105K2M	1	
3	Drying Tumber	UNIMAC	UT075-L-RQ	2	
4	Drying Tumbler	UNIMAC	UT120-L-RQ	1	
5	Work Table, Stainless Steel Top	Advance Tabco	TSS-488	1	
6	Vacuum Board	EuroFinish	PND-1000AC	1	
6.1	Mini Boiler & Iron	EuroFinish	SVP-24	1	
7	One (1) Compartment Sink	Advance Tabco	FC-1-1620-18L	1	
9	Round Trip Carts	Steele	P8592	2	
11	Cart, Laundry	Steele	092014	3	
12	Wire Shelving Unit	Nexel	24606N	4	
13	Flatwork Ironer	UNIMAC	FCU 3200/500	1	

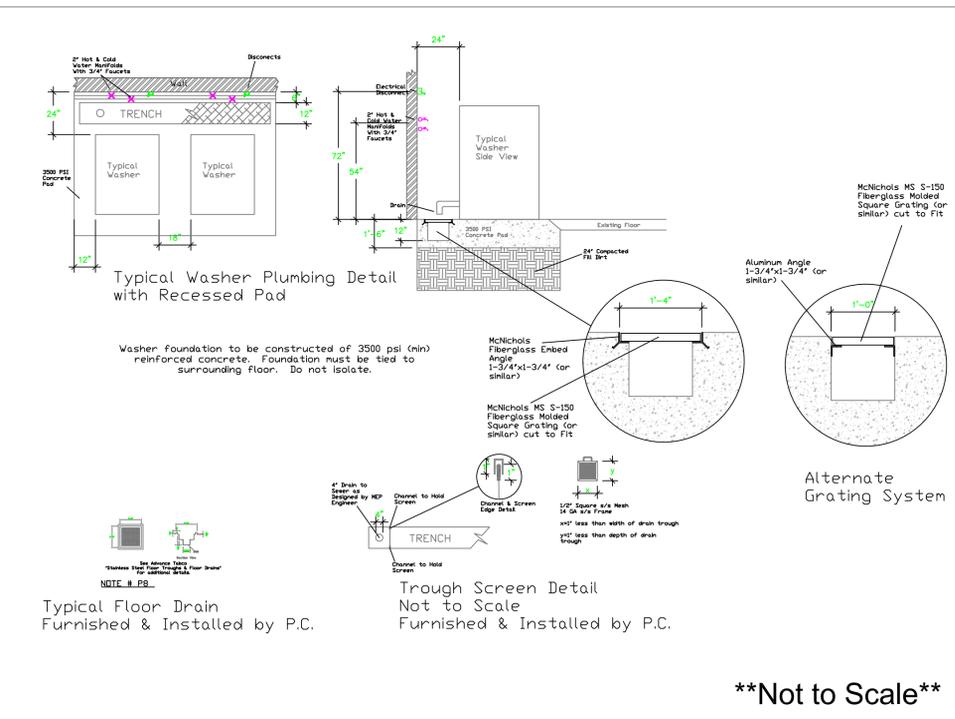

EQUIPMENT LAYOUT

All Dimensions to be verified on the job site. Actual locations for floor drains, and any ventilating equipment to be determined by Engineer. Mechanical, Plumbing & Electrical to be checked and verified by Customers MEP Engineer. Remote Condensing Units to be located by Architect. Exhaust & Supply fans to be located by Architect.

Alaia Resort
Laundry
San Pedro, Belize

uni-source
SUPPLY

INTERNATIONAL INC.

2055 W 73rd Street, Miami, FL 33016


Ph: (305)826-8696 Fax: (305)826-9131

No.	Revision/Issue	Date
2	Layout with Updated backgrounds	5-03-18
3	Adjusted layout with updated background	6-29-18
4	New Background, added Ironer & Office	7-17-18
5	MEP Drawings Added	8-31-18


Date
August 31, 2018
Drawn By
Dayne Gauntlett
Scale
1/2" = 1'0"

Sheet
AL-1

Not to Scale

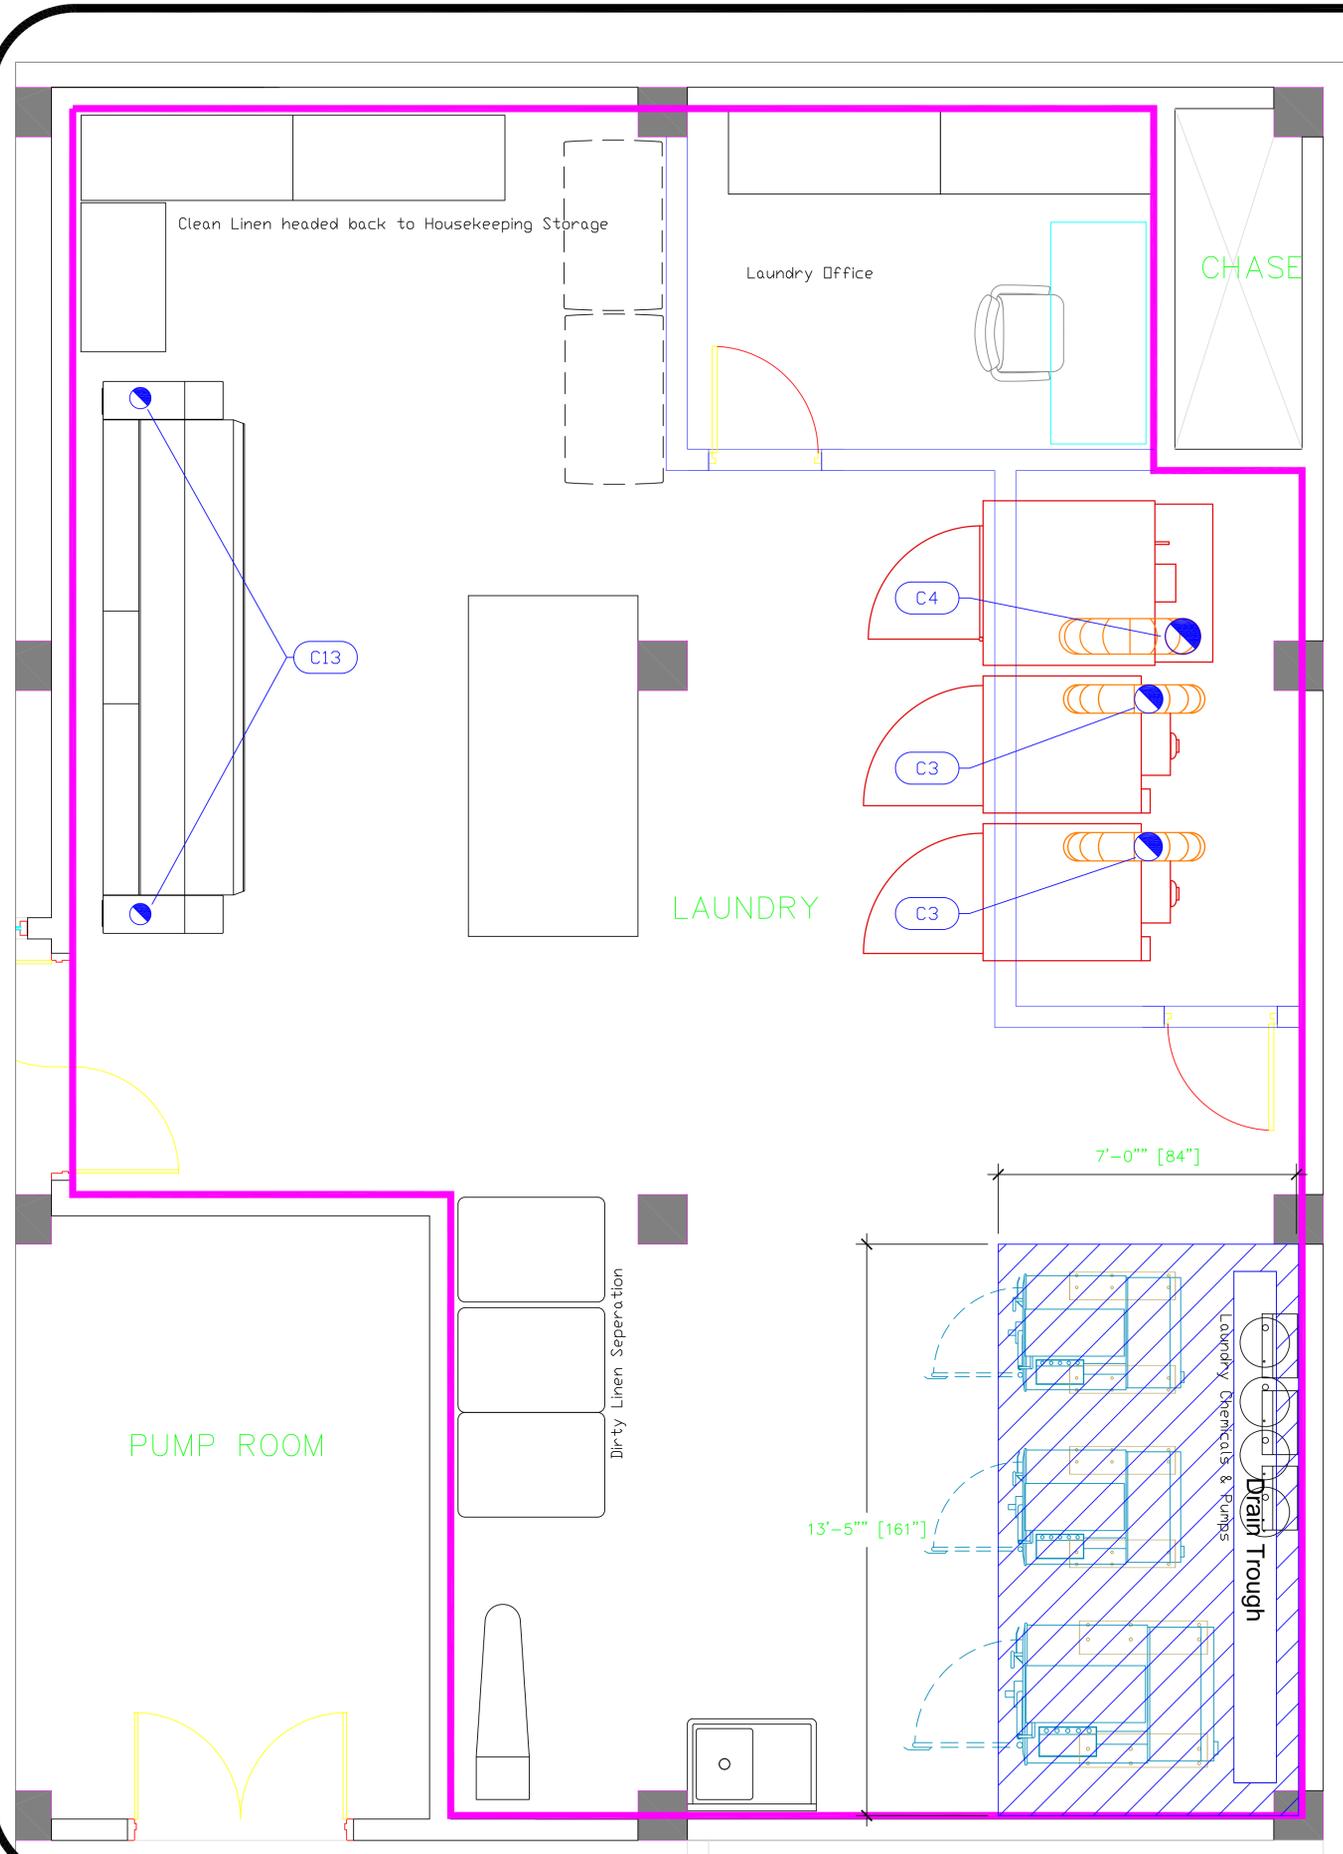

Mechanical Schedule							
ITEM NO.	QTY	DISCRPTION	EXHAUST (L X W)	EXHAUST (CFM)	SUPPLY (L X W)	SUPPLY (CFM)	Ventilation Remarks
1	2	Washer Extractor					Reinforced Concrete Pad
2	1	Washer Extractor					Reinforced Concrete Pad
3	2	Drying Tumbler	8" Dia	920			
4	1	Drying Tumbler	10" Dia	1600			
13	1	Flatwork Ironer	(2) 6"	(2) 583			

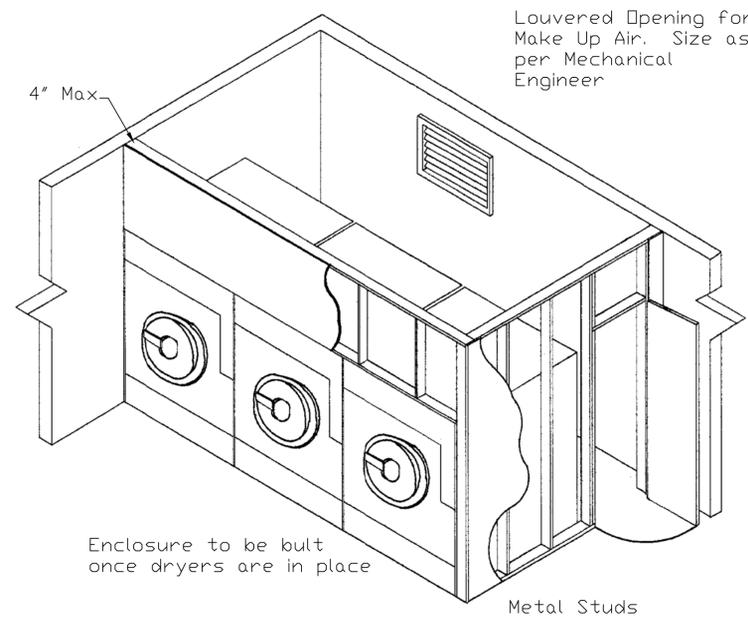

Typical Dry Enclosure

LEGEND - MECHANICAL

- EXHAUST DUCT COLLAR
- SUPPLY DUCT COLLAR
- INWALL BACKING FOR WALL SHELVES
- RECESSED FLOOR
- REINFORCED FLOOR Min.3500PSI
- RAISED EQUIPMENT PADI

NOTE # M5
ALL NATIONAL, STATE, AND LOCAL CODES SHALL APPLY

NOTE # M6
ARCHITECT OR ENGINEER TO SIZE AND LOCATE, CONTRACTOR TO PROVIDE ALL OPENINGS FOR DUCTS, PLUMBING LINES, ELECTRICAL LINES, AND REFRIGERATION LINES, AS REQUIRED BY EQUIPMENT.

NOTE # M7
SUPPLY FANS TO BE LOCATED A MINIMUM OF 10' FROM EXHAUST FANS.

NOTE # M8
SHIP DRAWING WILL BE PROVIDED BY MANUFACTURER FOR HOOD, EXHAUST FANS, & SUPPLY FANS, UNCE ORDER IS PLACE WITH.

NOTE # M9
GENERAL CONTRACTOR TO PROVIDE 1/2" PLYWOOD WALL BACKING FROM 48" TO 78" AFF FOR ALL WALL MOUNTED EQUIPMENT.

NOTE # M10
CEILING HEIGHTS TO BE VERIFIED FOR SUFFICIENT CLARENCE FOR EQUIPMENT.

NOTE # M11
REFRIGERATION CONTRACTOR TO HANG EVAPORATORS FOR WALK-IN, RUN & CHARGE LINES BETWEEN EVAP. & CONDENSING UNIT.

Equipment MECHANICAL Service Requirements

All Dimensions to be verified on the job site. Actual locations for floor drains, and any ventilating equipment to be determined by Engineer. Mechanical, Plumbing & Electrical to be checked and verified by Customers MEP Engineer. Remote Condensing Units to be located by Architect. Exhaust & Supply Fans to be located by Architect.

Alaia Resort
Laundry
San Pedro, Belize

uni-source
SUPPLY
INTERNATIONAL INC.

2055 W 73rd Street, Miami, FL 33016
Ph:(305)826-8696 Fax:(305)826-9131


No.	Revision/Issue	Date
2	Layout with Updated backgrounds	5-03-18
3	Adjusted layout with updated background	6-29-18
4	New Background, added Ironer & Dffice	7-17-18
5	MEP Drawings Added	8-31-18

Date
August 31, 2018

Drawn By
Dayne Gauntlett


Scale
1/2" = 1'0"

Sheet
AL-2

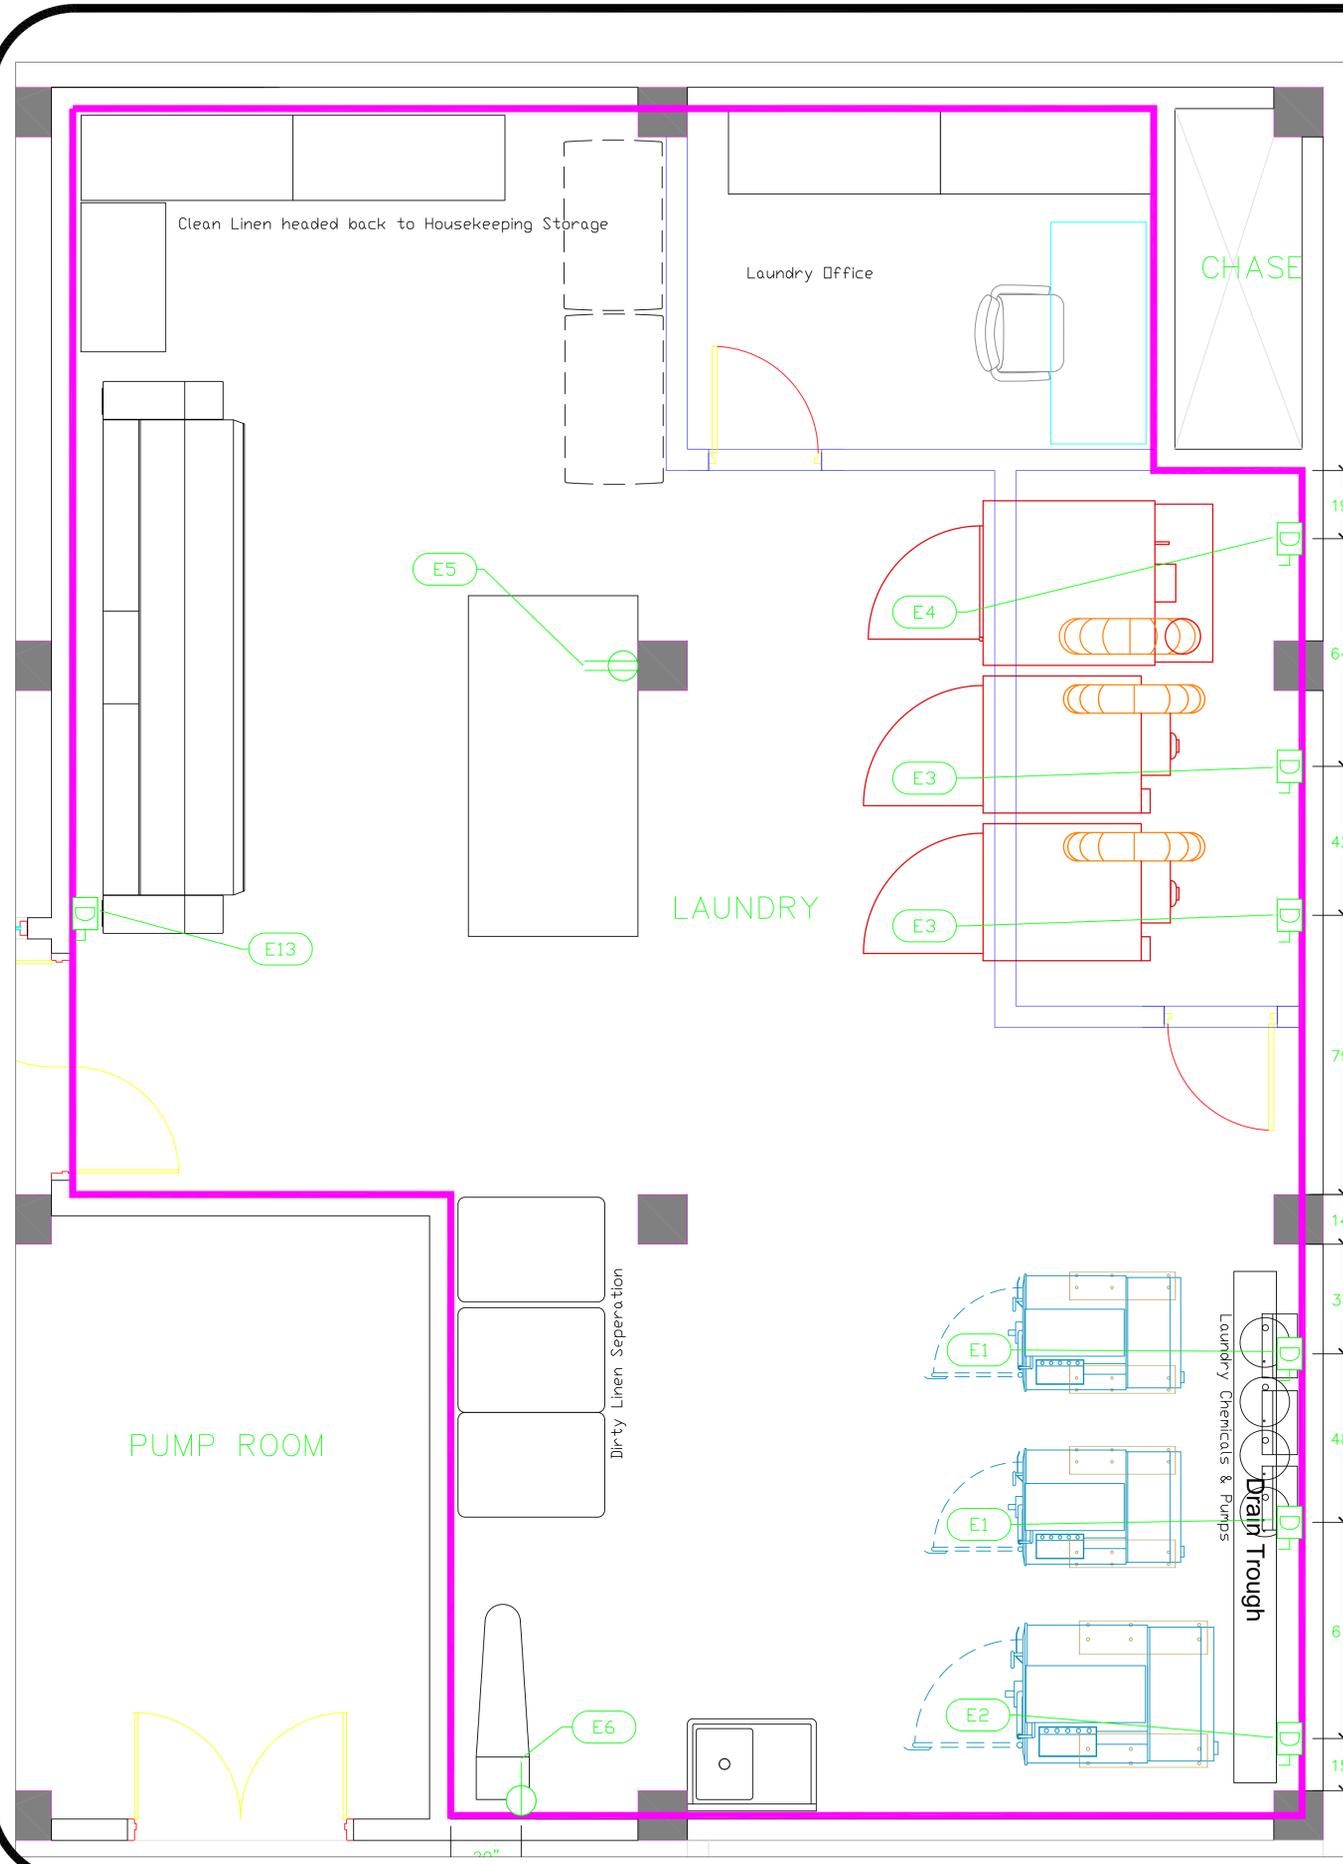

ELECTRICAL SCHEDULE											
ItemNo	Category	Voltage	Cycle	Phase	Amps	Hp	NEMA	ConnectionType	Rough-In AFF	Quantity	Electrical Remarks
1	Washer Extractor	208	60	3	9	5		Disconnect	72"	2	
2	Washer Extractor	208	60	3	14	7.5		Disconnect	72"	1	
3	Drying Tumbler	208	60	3	4.3			Disconnect	72"	2	
4	Drying Tumbler	208	60	3	7.7			Disconnect	72"	1	
5	Work Table, Stainless Steel Top	115	60	1	15			Duplex	48"	1	Convenience Outlet. See Note P1
6	Vacuum Board	115	60	1	6			Simplex	18"	1	
6.1	Mini Boiler & Iron	115	60	1	15			Simplex	18"	1	
13	Flatwork Ironer	208	60	3	2.6			Disconnect	72"	1	
99	Chemical Pump	120	60	1	15			Simplex	36"	1	

- LEGEND - ELECTRICAL CONNECTIONS**
- DUPLEX RECEPT., 15-AMP, 120-VOLT, GROUND TYPE, HORIZONTAL MOUNT
 - SIMPLEX RECEPT., 120-VOLT, GROUND TYPE, HORIZONTAL MOUNT
 - SPECIAL PURPOSE OUTLET, GROUND TYPE, HORIZONTAL MOUNT
 - JUNCTION BOX, DIRECT CONNECTION
 - DISCONNECT SWITCH, DIRECT CONNECTION
 - FLOOR/CEILING RECEPTACLE AS INDICATED
 - (2) Telephone + (2) Data
 - FIELD CONNECTIONS
 - HARD WIRE CONNECTION POINT AT MACHINE

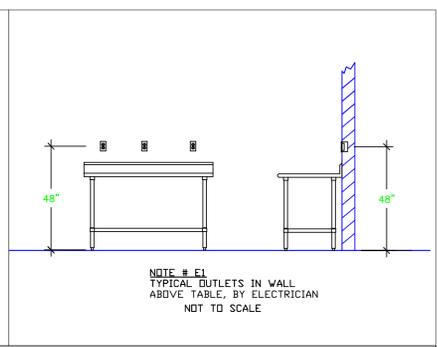

NOTE # E2
ALL NATIONAL, STATE, AND LOCAL CODES SHALL APPLY

NOTE # E3
ALL ELECTRICAL CONNECTIONS AND HARDWARE REQUIRED TO BE PROVIDED BY ELECTRICAL CONTRACTOR

NOTE # E4
ALL JUNCTION BOXES, OUTLETS, ETC. TO BE LOCATED SO AS TO NOT INTERFERE WITH EQUIPMENT

NOTE # E5
ALL RELAYS, CONTRACTORS, STARTERS, AND SWITCHES REQUIRED FOR EXHAUST & SUPPLY FANS TO BE PROVIDED BY ELECTRICAL CONTRACTOR UNLESS SPECIFIED

NOTE # E6
ELECTRICAL CONTRACTOR TO INTERCONNECT DISHMACHINE TO EXHAUST FAN FOR DISHMACHINE SO THAT THE FAN RUNS WHEN THE DISHMACHINE IS IN OPERATION.

NOTE # E7
ELECTRICAL CONTRACTOR TO INSTALL TABLE LIMIT SWITCH TO END OF CLEAN DISHTABLE TO THAT MACHINE STOPS WHEN SWITCH IS DEPRESSED.

NOTE # E8
ELECTRICAL CONTRACTOR TO CONNECT DRAIN LINE HEATER, PAN HEATER AND DOOR HEATER FOR WALK-IN FREEZER.

Equipment ELECTRICAL Service Requirements

All Dimensions to be verified on the job site. Actual locations for floor drains, and any ventilating equipment to be determined by Engineer, Mechanical, Plumbing & Electrical to be checked and verified by Customers MEP Engineer. Remote Condensing Units to be located by Architect. Exhaust & Supply fans to be located by Architect.


Alaia Resort
Laundry
San Pedro, Belize

uni-source SUPPLY
INTERNATIONAL INC.
2055 W 73rd Street, Miami, FL 33016
Ph:(305)826-8696 Fax:(305)826-9131

2	Layout with Updated backgrounds	5-03-18
3	Adjusted layout with updated background	6-29-18
4	New Background, added Ironer & Office	7-17-18
5	MEP Drawings Added	8-31-18
No.	Revision/Issue	Date

Date
August 31, 2018
Drawn By
Dayne Gauntlett
Scale
1/2" = 1'0"

Sheet
AL-3

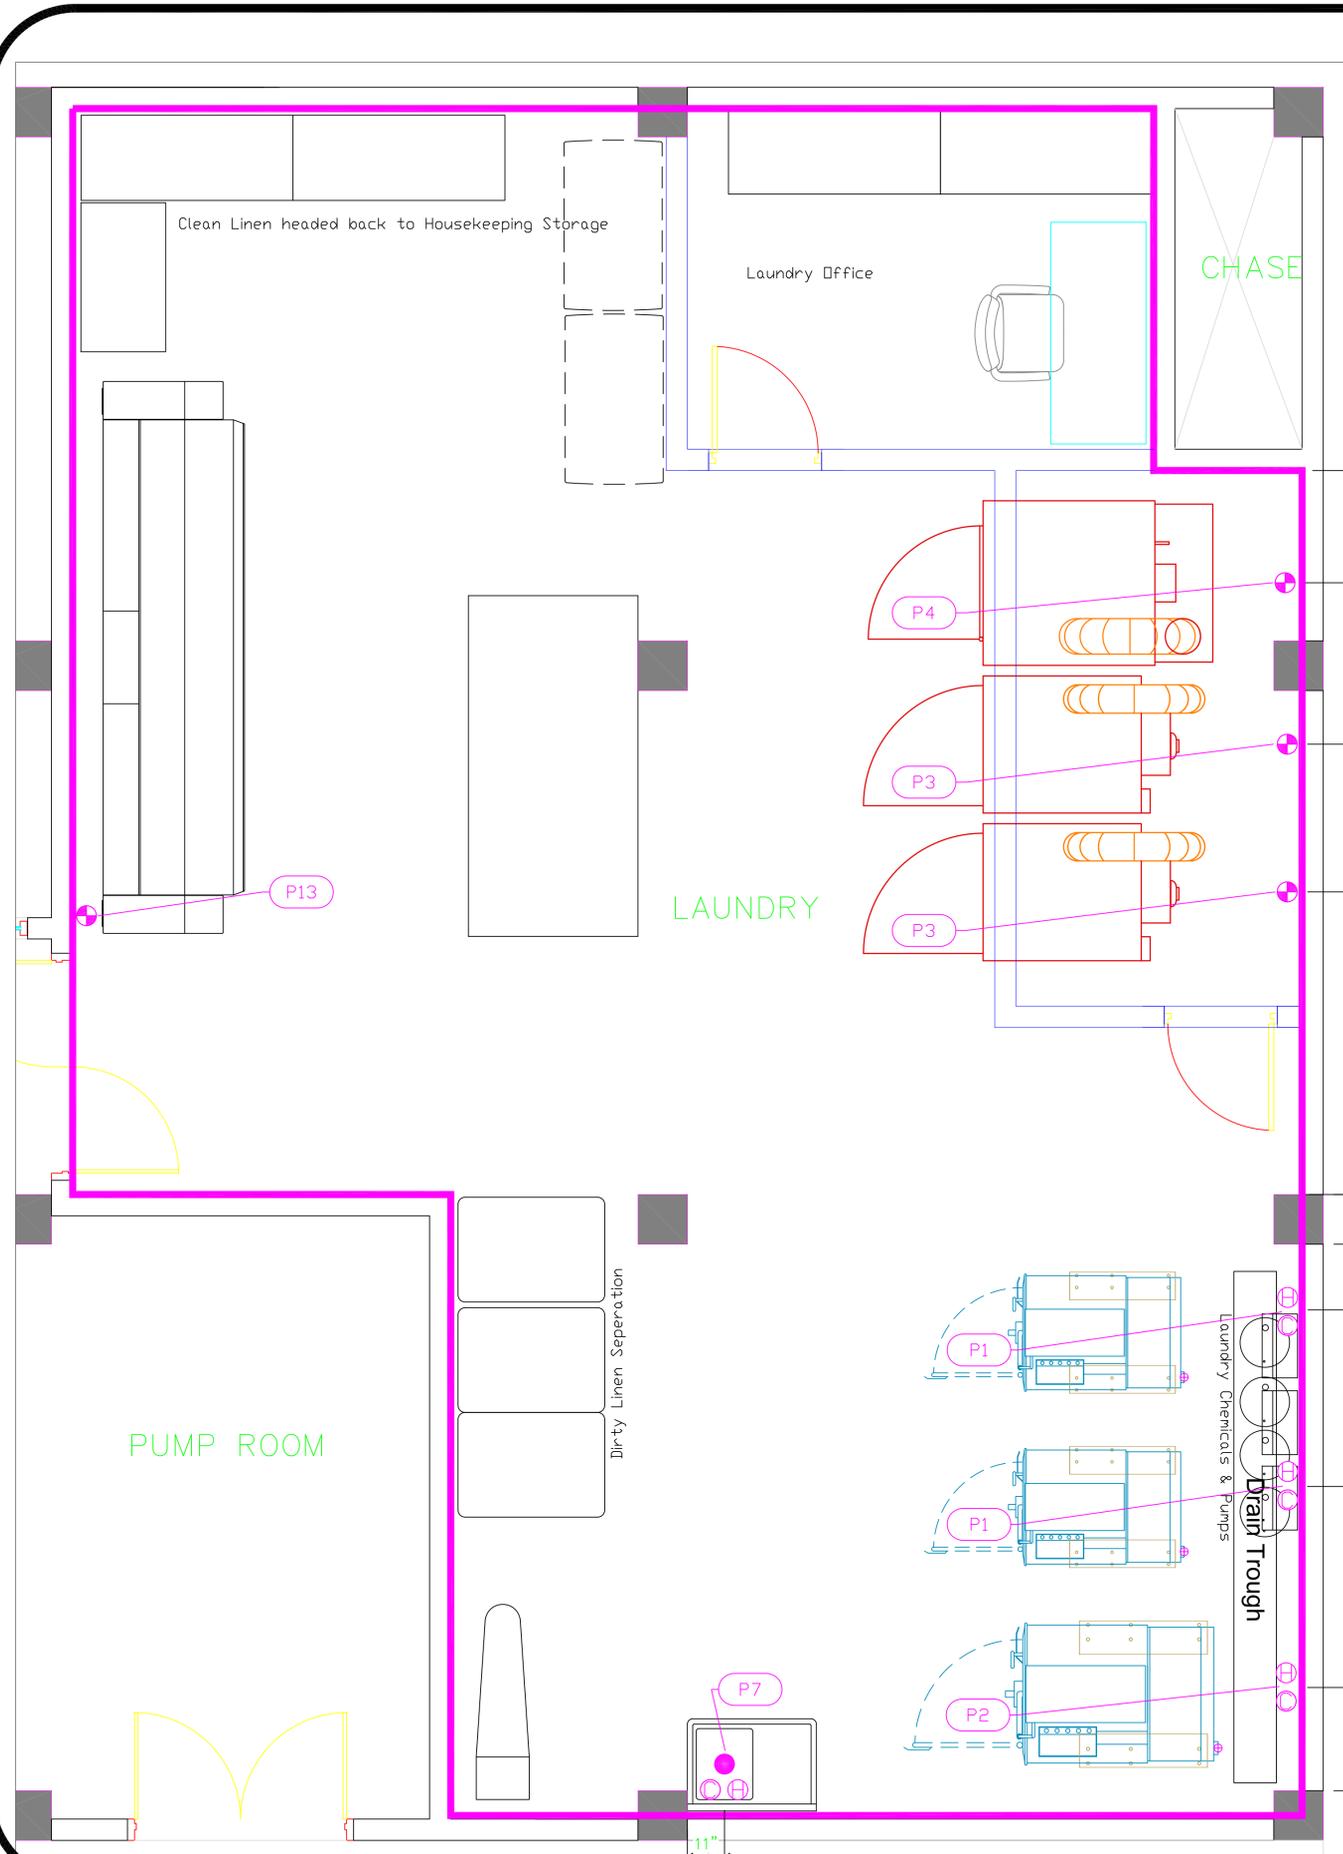


PLUMBING SCHEDULE														
ITEM NO.	DESCRIPTION	COLD WATER SIZE	COLD WATER HOT AFF.	WATER HOT SIZE	WATER HOT AFF.	H&C ROUGH-IN	DIRECT WASTE SIZE	DIRECT WASTE AFF.	INDIRECT WASTE SIZE	GAS SIZE(IN)	GAS CONN. AFF.	GAS MBTU	QTY	PLUMBING REMARKS
1	Washer Extractor	3/4"	53"	3/4"	53"	54"			3"				2	
2	Washer Extractor	3/4"	53"	3/4"	53"	54"				1/2"	66"	165	2	
3	Drying Tumbler									1"	66"	270	1	
4	Drying Tumbler												1	(1) set of 1/2" faucet holes, 8" OC
7	One (1) Compartment Sink	1/2"	38"	1/2"	38"	12"	1-1/2"	24"					1	
13	Flatwork Ironer									3/4"	36"	225	1	

See Advance Tabco "Stainless Steel Floor Troughs & Floor Drains" for additional details.

NOTE # P8
TYPICAL FLOOR SINK
NOT TO SCALE

LEGEND - PLUMBING CONNECTIONS

- HW-HOT WATER, OR CW-COLD WATER
- ⊕ GAS
- WASTE, DIRECT-CONNECTED
- ⊕ WASTE, INDIRECT to Floor Sink
- ⊕ FLOOR DRAIN Josam 30000-A3
- ⊕ FUNNEL FLOOR DRAIN Josam 30000-E3

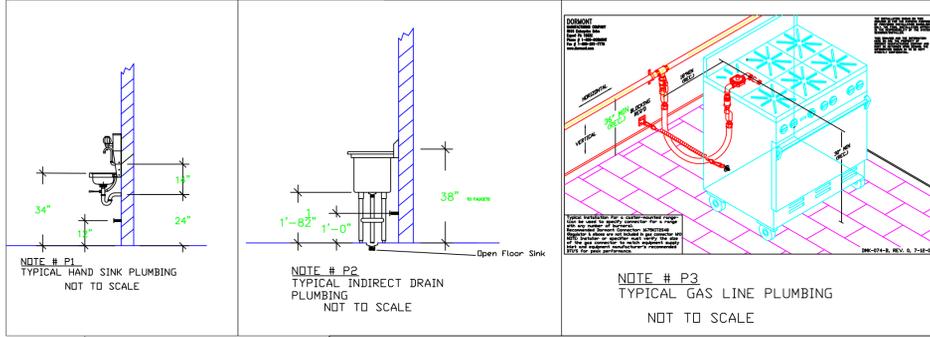

- NOTE # P4
ALL NATIONAL, STATE, AND LOCAL CODES SHALL APPLY
- NOTE # P5
ALL PLUMBING CONNECTIONS TO BE EXTENDED AND INTERCONNECTED TO EQUIPMENT AND ALL HARDWARE REQUIRED TO BE PROVIDED BY PLUMBING CONTRACTOR
- NOTE # P6
PLUMBING CONTRACTOR TO VERIFY THAT ALL EQUIPMENT IS INSTALLED WITH THE APPROPRIATE GAS PRESSURE AND REGULATORS
- NOTE # P7
ALL WASTE LINES AND CONDENSATE LINES TO BE EXTEND FROM EQUIPMENT TO FLOOR DRAINS BY PLUMBING CONTRACTOR.

Equipment PLUMBING Service Requirements

All Dimensions to be verified on the job site. Actual locations for floor drains, and any ventilating equipment to be determined by Engineer. Mechanical, Plumbing & Electrical to be checked and verified by Customers MEP Engineer. Remote Condensing Units to be located by Architect. Exhaust & Supply fans to be located by Architect.

**Alaia Resort
Laundry
San Pedro, Belize**

uni-source SUPPLY
INTERNATIONAL INC.

2055 W 73rd Street, Miami, FL 33016
Ph:(305)826-8696 Fax:(305)826-9131

No.	Revision/Issue	Date
2	Layout with Updated backgrounds	5-03-18
3	Adjusted layout with updated background	6-29-18
4	New Background, added Ironer & Office	7-17-18
5	MEP Drawings Added	8-31-18

Date
August 31, 2018
Drawn By
Dayne Gauntlett
Scale
1/2" = 1'0"

Sheet
AL-4