

EQUIPMENT OVERVIEW

All Dimensions to be verified on the job site.
 Actual locations for floor drains, and any ventilating equipment to be determined by Engineer.
 Mechanical, Plumbing & Electrical to be checked and verified by Customers MEP Engineer.
 Remote Condensing Units to be located by Architect.
 Exhaust & Supply fans to be located by Architect.

**Baha Mar
 Jazz Bar**
 Nassau, Bahamas



INTERNATIONAL INC.

2055 W 73rd Street, Miami, FL 33016
 Ph: (305)826-8696 Fax: (305)826-9131

2	Updates From Ownership	4-3-24
3	Updates From Ownership	4-9-24
4	Updates From Ownership	4-11-24
5	Finalized MEP after updates	5-1-24
No.	Revision/Issue	Date

Date

May 1, 2024

Drawn By

Dayne Gauntlett

Scale


1/8" = 1'0"

Sheet


FS-1.0

EQUIPMENT SCHEDULE						
ItemNo	Category	Mfr	Model	Quantity	Equipment Remarks	
1	Rapid Cook Oven	TurboChef	PLE-9500-2-DL-RRR	1		
2	Ventless Fryer	Wells	WVLE-55FC	1		
3	Reach-In Heated Cabinet	Continental Refrigerator	DL1W	1		
4	Induction Range, Countertop	CookTek	601701	1		
5	Chef's Table	Custom Fab	Q1711A-5	1		
5.1	Heat Lamp	Halco	GRAHL-42	2		
5.2	Deck Mount Faucet	Krowne	154-10L	1		
5.3	Undercounter Refrigerator	Continental Refrigerator	SW60N-UJD	1		
6	Ice Maker with Bin, Cube-Style	Hoshizaki	IM-50BAA-LM	1		
6.1	Water Filtration System, for Ice Machines	Everpure	EV932401	1		
7	Glass Froster	Glastender	F1S124	1		
8	Sandwich / Salad Preparation Refrigerator	Continental Refrigerator	SW48N10-D	1		
8.1	Shelving, Wall Mounted	Advance Tabco	WS-15-48-16	1		
8.2	Shelving, Wall Mounted	Advance Tabco	WS-15-84-16	1		
9	Walk In Cooler, Modular, Self-Contained	Arctic Industries	BL66-CF-SC	1		
9.3	Shelving Unit, Wire	Quantum	WR63-1436GY	1		
10	Dishwasher, Door Type, Ventless	Jackson VWS	TEMPSTAR VENTLESS (VER)	1		
11	Soiled Dishable	Advance Tabco	DTS-S30-108L	1		
11.1	Pre-Rinse Faucet Assembly	Krowne	F7-108WL	1		
11.2	Soak Sink	Advance Tabco	9-FSC-20	1		
12	Clean Dishable	Advance Tabco	DTC-S30-48R	1		
12.1	Dishable Sorting Shelf	Advance Tabco	DT-6R-22	2		
13	Shelving Unit, Wire	Quantum	WR63-1860GY	1		
14	Shelving Unit, Wire	Quantum	WR63-1860GY	2		
31	Corner Angle Filler	Glastender	CWB-15	1		
32	Back Bar Cabinet, Refrigerated	Glastender	C1FB60	1		
33	Bottle Cooler	Glastender	ST24-S	1		
34	Ice Bin	Glastender	IBA-24-CP10	1		
34.1	Overshelf	Advance Tabco	CM-18-48	1		
35	Underbar Mixology Sink Unit	Glastender	MRS-12	1		
35.1	Soda Gun Holder & Tubing Chase	Glastender	SHB-6	1		
36	Bottle Storage Unit	Glastender	LDA-12S	1		
37	Ice Maker, Cube-Style	Hoshizaki	IM-5005AB	2		
37.1	Ice Bin for Ice Machines	Hoshizaki	B-700SF	1		
37.1	Water Filtration System, for Ice Machines	Everpure	EV932402	2		
38	POS System	POS	POS	1		
51	Dishwasher, Door Type, Ventless	Jackson VWS	TEMPSTAR VENTLESS (VER)	1		
52	Soiled Dishable	Advance Tabco	DTS-S30-72L	1		
52.1	Pre-Rinse Faucet Assembly	Krowne	F7-108WL	1		
52.2	Soak Sink	Advance Tabco	9-FSC-20	1		
52.3	Dishable Sorting Shelf	Advance Tabco	DT-6R-22	2		
53	Clean Dishable	Advance Tabco	DTC-S30-48R	1		
54	Foodservice Door	Chase Doors	CDP3 30X94	1		
55	Shelving Unit, Wire	Quantum	WR63-1842GY	1		
56	Ice Maker, Cube-Style	Hoshizaki	IM-5005AB	2		
56.1	Ice Bin for Ice Machines	Hoshizaki	B-700SF	1		
56.1	Water Filtration System, for Ice Machines	Everpure	EV932402	2		
57	Ice Maker with Bin, Cube-Style	Hoshizaki	IM-50BAA-LM	1		
57.1	Water Filtration System, for Ice Machines	Everpure	EV932401	1		
61	Back Bar Cabinet, Refrigerated	Glastender	C1SB48	1		
62	Wine Refrigerator	Enofogo	A1B2V4SN	1		
62.1	Reach-In Freezer	Continental Refrigerator	D1FSENS5	1		
63	Ice Bin	Glastender	IBA-24-CP10	2		
64	Underbar Mixology Sink Unit	Glastender	MRS-12	1		
64.1	Soda Gun Holder & Tubing Chase	Glastender	SHB-4	2		
65	Bottle Storage Unit	Glastender	LDA-18S	2		
66	Bottle Cooler	Glastender	ST24-S	1		
67	Shelving, Wall Mounted	Advance Tabco	WS-12-48	3		
68	Corner Angle Filler	Glastender	CJR-24/24-N	1		
69	Corner Angle Filler	Glastender	CWB-30	1		
74	Glass Rack	Glastender	DBGR-24-RS	4		
75	Ice Bin	Glastender	IBA-24-CP10	4		
76.1	Corner Angle Filler	Glastender	CWB-20	2		
76.2	Corner Angle Filler	Glastender	CWB-15 - CUSTOM	10		
76.3	Corner Angle Filler	Glastender	CWB-20 - CUSTOM	3		
77	Bottle Storage Unit	Glastender	LDA-12S	4		
78	Underbar Mixology Sink Unit	Glastender	MRS-12	3		
78.1	Soda Gun Holder & Tubing Chase	Glastender	SHB-4	4		
78.2	Drainboard	Glastender	DBB-6	2		
79	Underbar Add-On Unit	Glastender	DWB-12	4		
80	Glasswasher, Undercounter / Underbar	Krowne	QWA-124	1		
81	Waste Cabinet	Glastender	SWB-12-C	1		
83	Glass Froster	Glastender	F1SL24	1		
84	Back Bar Cabinet, Refrigerated	Glastender	C1SB48	3		
85	Back Bar Cabinet, Non-Refrigerated	Glastender	DS48	1		
101	Shelving Unit, Wire	Quantum	WR63-2460GY	2		
121	Refrigerator, Wine, Built-In	Sub-Zero	ICE-3050WR	1		
201	POS System	POS	POS	6		By Owner/Operator

Main Bar

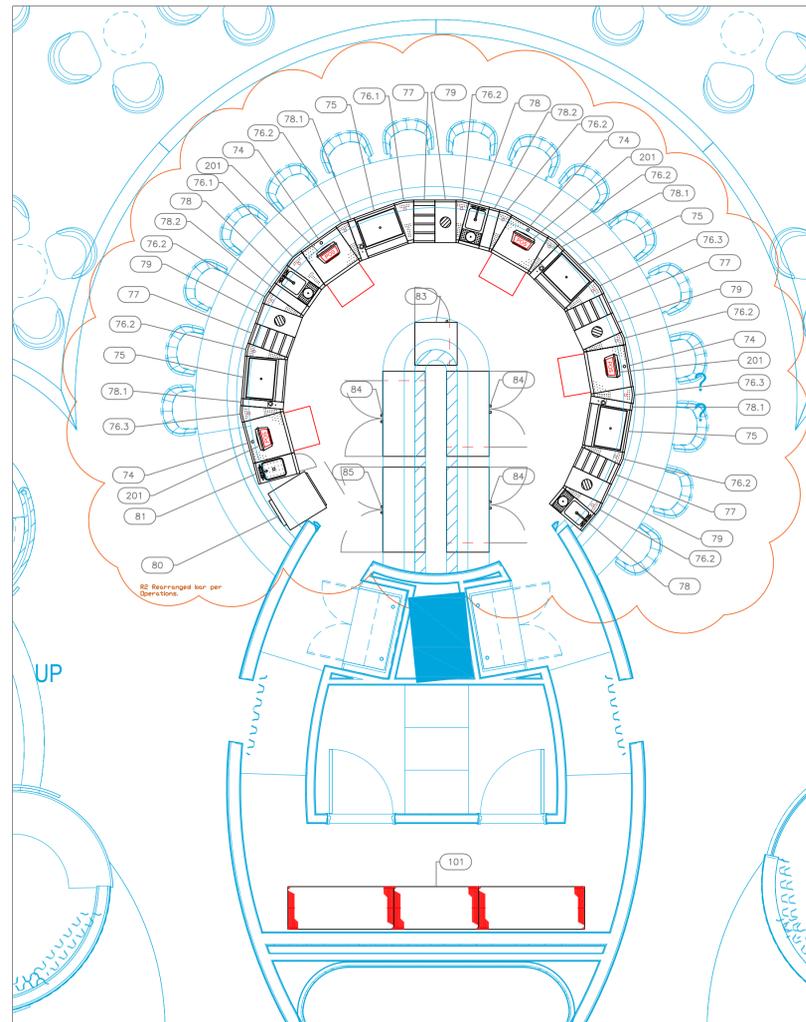


Main Bar Support

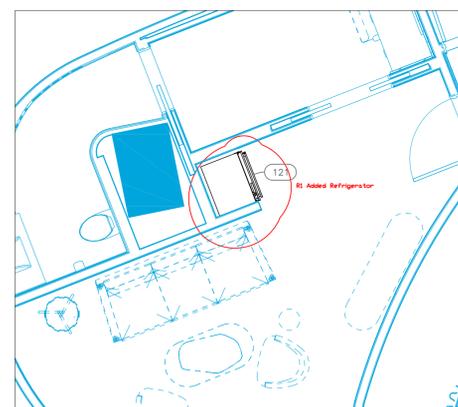

Green Room

Service Kitchen/Bar 2

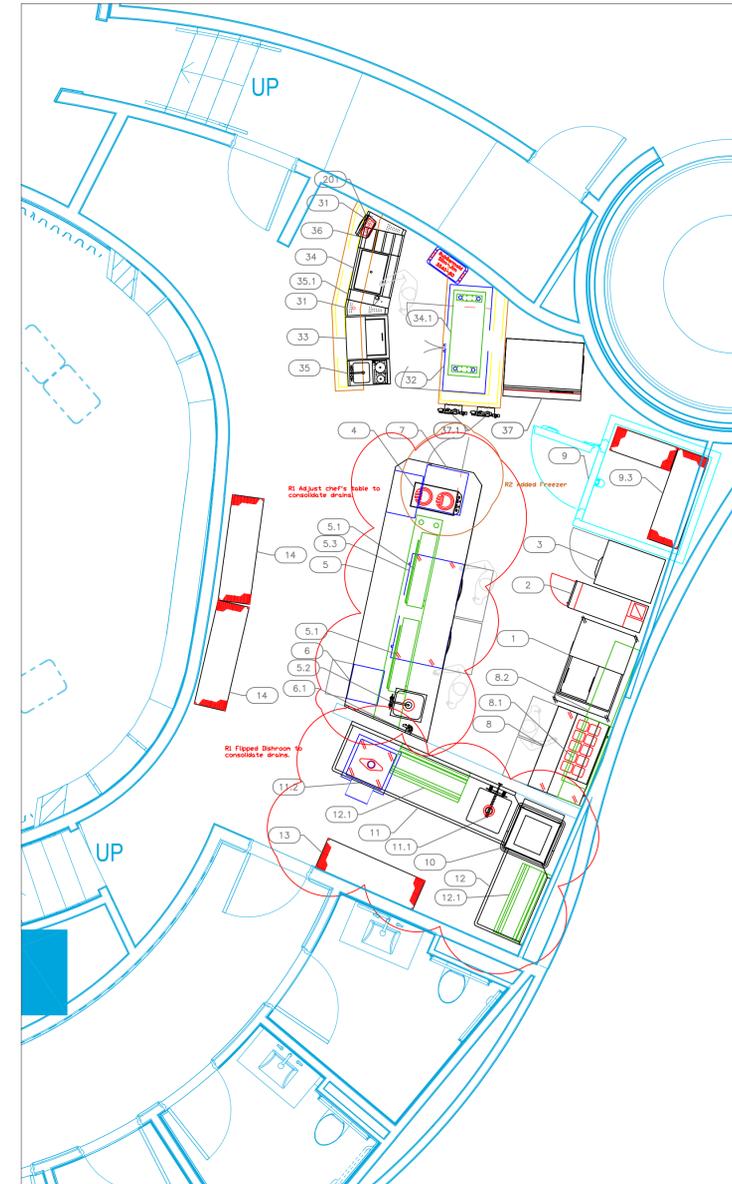

EQUIPMENT OVERVIEW

All Dimensions to be verified on the job site. Actual locations for floor drains, and any ventilating equipment to be determined by Engineer. Mechanical, Plumbing & Electrical to be checked and verified by Customers MEP Engineer. Remote Condensing Units to be located by Architect. Exhaust & Supply fans to be located by Architect.

Baha Mar
Jazz Bar
Nassau, Bahamas



INTERNATIONAL INC.


2055 W 73rd Street, Miami, FL 33016
Ph: (305)826-8696 Fax: (305)826-9131

2	Updates From Ownership	4-3-24
3	Updates From Ownership	4-9-24
4	Updates From Ownership	4-11-24
5	Finalized MEP after updates	5-1-24
No.	Revision/Issue	Date

Date
May 1, 2024
Drawn By
Dayne Gauntlett
Scale
1/4" = 1'0"


Sheet
FS-1.1

Main Bar

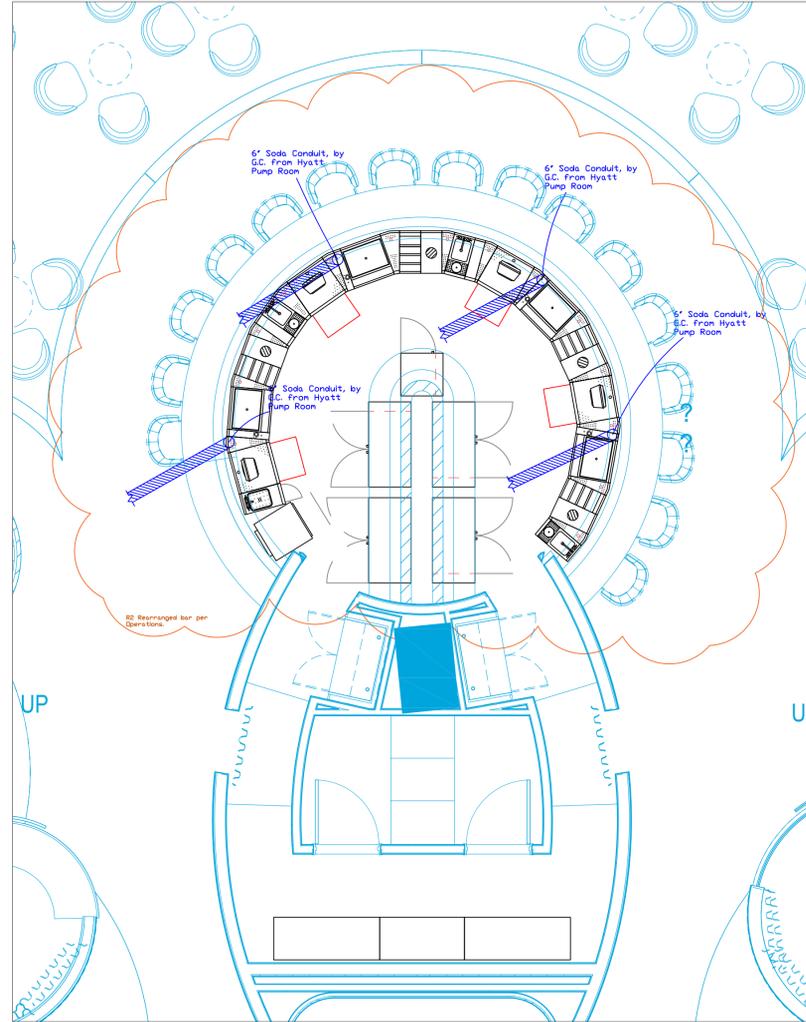

Main Bar Support


Service Kitchen/Bar 2

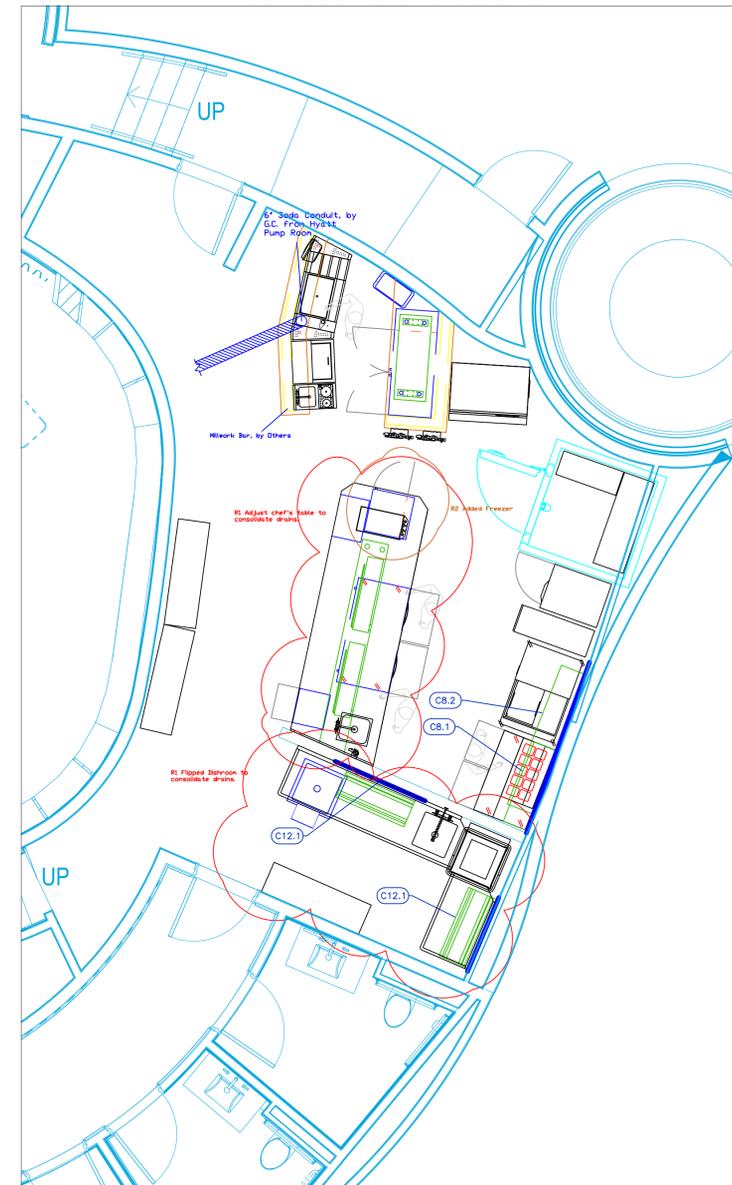

Service Bar 1



Mechanical Schedule								
ITEM NO.	QTY	DISCRIPTION	EXHAUST (L X W)	EXHAUST (CFM)	Makeup Vent Width	SUPPLY (CFM)	Ventilation Remarks	Unit
8.1	1	Shelving, Wall Mounted					Wall Backing, See Note M9	ea
8.2	1	Shelving, Wall Mounted					Wall Backing, See Note M9	ea
12.1	2	Dishable Sorting Shelf					Wall Backing, See Note M9	ea
35.1	1	Soda Gun Holder & Tubing Chase					Beverage Conduit 6"	ea
52.3	2	Dishable Sorting Shelf					Wall Backing, See Note M9	ea
67	3	Shelving, Wall Mounted					Wall Backing, See Note M9	ea

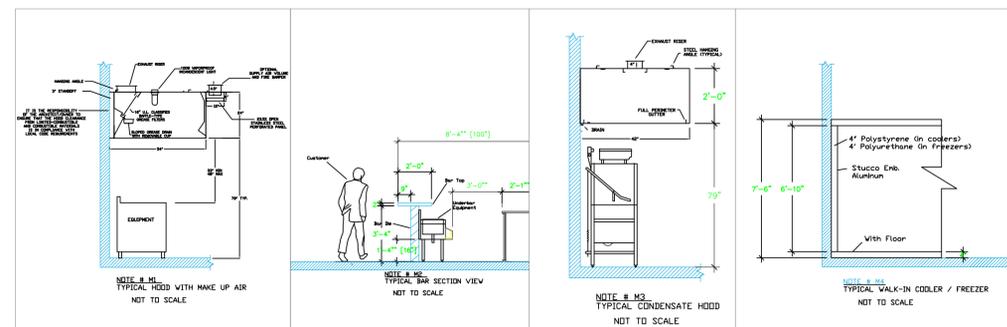

LEGEND - MECHANICAL

- EXHAUST DUCT COLLAR
- SUPPLY DUCT COLLAR
- INWALL BACKING FOR WALL SHELVES
- RECESSED FLOOR
- RAISED EQUIPMENT PAD

NOTE # M5
ALL NATIONAL, STATE, AND LOCAL CODES SHALL APPLY.

NOTE # M6
ARCHITECT OR ENGINEER TO SIZE AND LOCATE CONTRACTOR TO PROVIDE ALL OPENINGS FOR DUCTS, PLUMBING LINES, ELECTRICAL LINES, AND REFRIGERATION LINES, AS REQUIRED BY EQUIPMENT.

NOTE # M7
SUPPLY FANS TO BE LOCATED A MINIMUM OF 10' FROM EXHAUST FANS.

NOTE # M8
SHOP DRAWING WILL BE PROVIDED BY MANUFACTURER FOR HOOD, EXHAUST FANS, & SUPPLY FANS, UNCE ORDER IS PLACE WITH.

NOTE # M9
GENERAL CONTRACTOR TO PROVIDE 2" PLYWOOD WALL BACKING FROM 30" TO 78" AFF FOR ALL WALL MOUNTED EQUIPMENT.

NOTE # M10
CEILING HEIGHTS TO BE VERIFIED FOR SUFFICIENT CLEARANCE FOR EQUIPMENT.

NOTE # M11
REFRIGERATION CONTRACTOR TO HANG EVAPORATORS FOR WALK-IN, RUN & CHARGE LINES BETWEEN EVAP. & CONDENSING UNIT.

Equipment MECHANICAL Service Requirements

All Dimensions to be verified on the job site. Actual locations for floor drains, and any ventilating equipment to be determined by Engineer. Mechanical, Plumbing & Electrical to be checked and verified by Customers MEP Engineer. Exhaust & Supply Units to be located by Architect.

Baha Mar
Jazz Bar
Nassau, Bahamas




uni-source
SUPPLY
INTERNATIONAL INC.

2055 W 73rd Street, Miami, FL 33016
Ph: (305) 826-8696 Fax: (305) 826-9131

2	Updates from Ownership	4-3-24
3	Updates from Ownership	4-9-24
4	Updates from Ownership	4-11-24
5	Finalized MEP after updates	5-1-24
No.	Revision/Issue	Date

Date
May 1, 2024
Drawn By
Dayne Gauntlett
Scale
1/4" = 1'0"


Sheet
FS-2.1

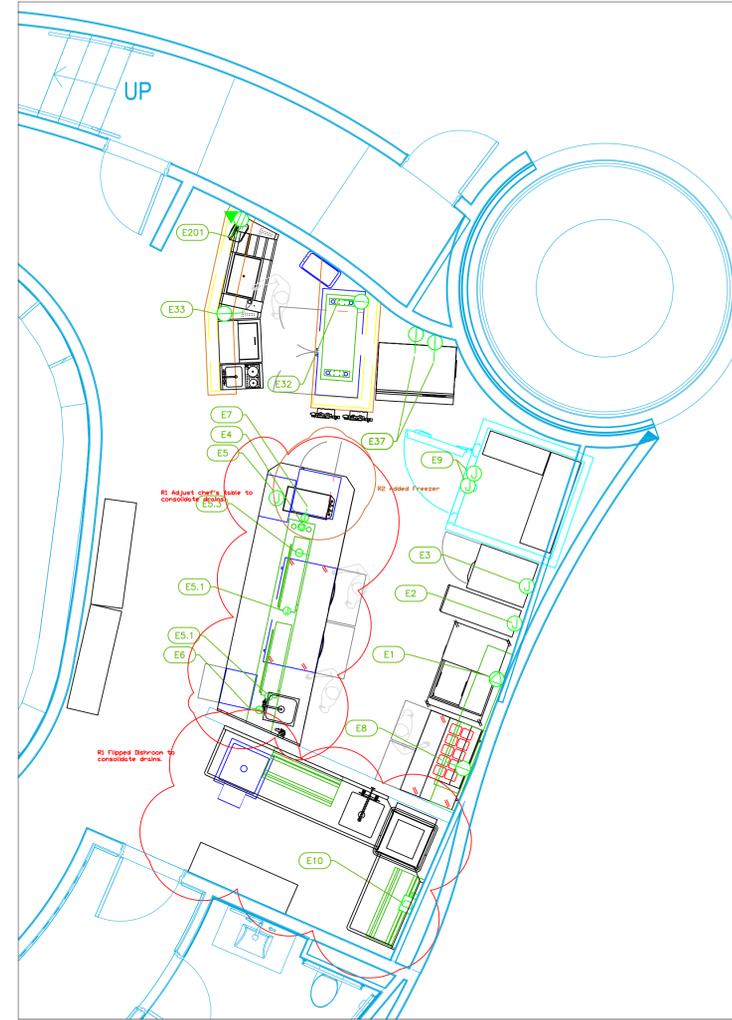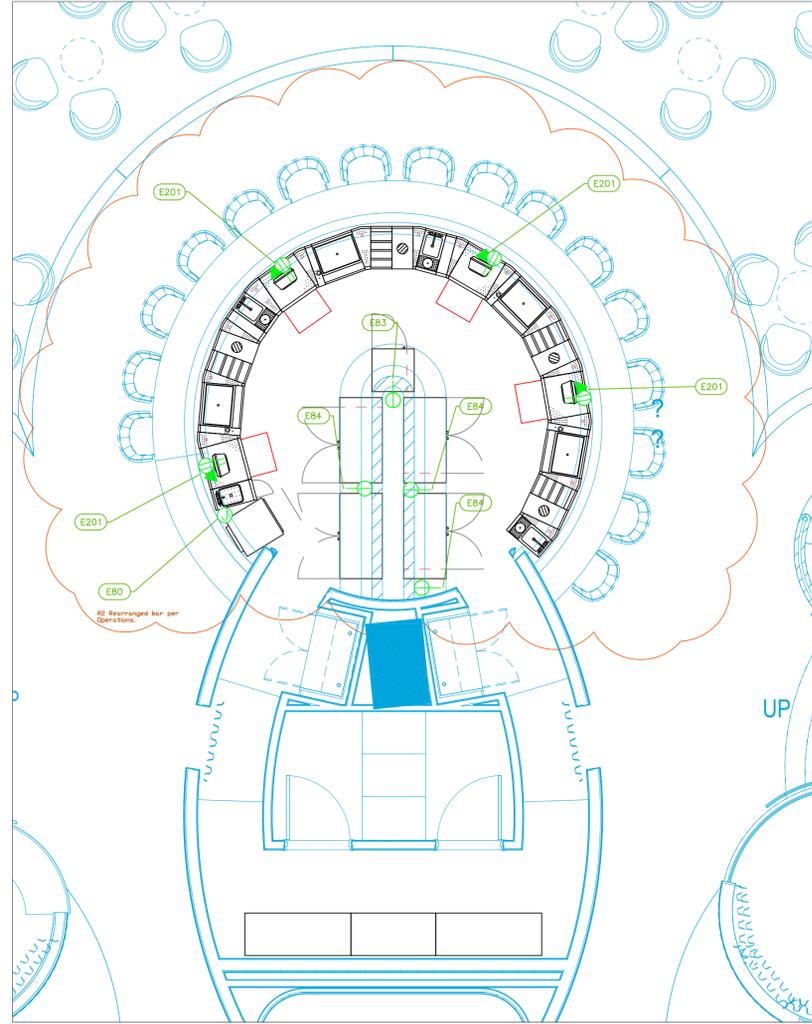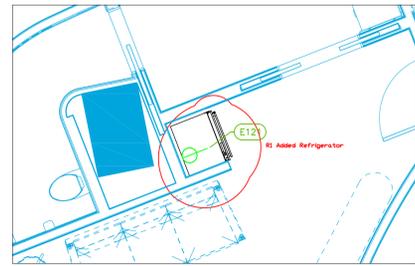

ELECTRICAL SCHEDULE											
ItemNo	Category	Voltage	Cycle	Phase	Amps	Hp	NEMA	ConnectionType	Rough-In AFF	Quantity	Electrical Remarks
1	Rapid Cook Oven	208-240	60	3	50		15-50P	Special	36"	1	
2	Ventless Fryer	208	60	3	48			J-Box	36"	1	
3	Reach-In Heated Cabinet	208-230	60	1	7.2			J-Box	36"	1	
4	Induction Range, Countertop	200-240	50/60	1	30		6-50P	Special	n/a	1	Elec Supply Field Wired from #5 Elec Panel
5	Chef's Table	110/208	60	3	Verify			J-Box	18"	1	Main Incoming For Electrical Panel
5.1	Heat Lamp	120	60	1	11.82			J-Box	n/a	2	Elec Supply Field Wired from #5 Elec Panel
5.3	Undercounter Refrigerator	115	60	1	2.46	1/5	5-15P	Simplex	n/a	1	Elec Supply Field Wired from #5 Elec Panel
6	Ice Maker with Bin, Cube-Style	115	60	1	5.0		5-15P	Simplex	n/a	1	Elec Supply Field Wired from #5 Elec Panel
7	Glass Froster	120	60	1	5	1/3	5-15P	Simplex	n/a	1	Elec Supply Field Wired from #5 Elec Panel
8	Sandwich / Salad Preparation Refrigerator	115	60	1	4.5	1/4	5-15P	Simplex	18"	1	
9	Walk In Cooler, Modular, Self-Contained	115	60	1	15			J-Box	100"	1	Lighting
		230	60	1	6.3			J-Box	100"	1	Condensing Unit
10	Dishwasher, Door Type, Ventless	208	60	3	45.6			Disconnect	18"	1	Disconnect for Wet Locations
32	Back Bar Cabinet, Refrigerated	120	60	1	3.5	1/6	5-15P	Simplex	18"	1	
33	Bottle Cooler	120	60	1	4.5	1/6	5-15P	Simplex	18"	1	
37	Ice Maker, Cube-Style	115	60	1	11.5			Simplex	36"	2	
38	POS System	120	60	1	15			Duplex	48"	1	
								DATA	48"	1	
51	Dishwasher, Door Type, Ventless	208	60	3	45.6			Disconnect	18"	1	Disconnect for Wet Locations
56	Ice Maker, Cube-Style	115	60	1	11.5			Simplex	36"	2	
57	Ice Maker with Bin, Cube-Style	115	60	1	5.0		5-15P	Simplex	18"	1	
61	Back Bar Cabinet, Refrigerated	120	60	1	2.75	1/8	5-15P	Simplex	18"	1	
62	Wine Refrigerator	115	60	1	3			Simplex	18"	1	
62.1	Reach-In Freezer	115	60	1	7.5	1/2	5-15P	Simplex	18"	1	
66	Bottle Cooler	120	60	1	4.5	1/6	5-15P	Simplex	18"	1	
80	Glasswasher, Undercounter / Underbar	208	60	1	32			J-Box	18"	1	
83	Glass Froster	120	60	1	5	1/3	5-15P	Simplex	18"	1	
84	Back Bar Cabinet, Refrigerated	120	60	1	2.75	1/8	5-15P	Simplex	18"	3	
121	Refrigerator, Wine, Built-In	115	60	1	15			Simplex	2-1/8"		See Spec Sheet for exact location info
201	POS System	115	60	1	15			Duplex	18"	6	Confirm Requirements with Owner
								DATA	18"	6	Confirm Requirements with Owner

LEGEND - ELECTRICAL CONNECTIONS

- DUPLEX RECEPT., 15-AMP, 120-VOLT, GROUND TYPE, HORIZONTAL MOUNT
- SIMPLEX RECEPT., 120-VOLT, GROUND TYPE, HORIZONTAL MOUNT
- SPECIAL PURPOSE OUTLET, GROUND TYPE, HORIZONTAL MOUNT
- JUNCTION BOX, DIRECT CONNECTION
- DISCONNECT SWITCH, DIRECT CONNECTION
- FLOOR/CEILING RECEPTACLE AS INDICATED
- (2) Telephone + (2) Data
- FIELD CONNECTIONS
- HARD WIRE CONNECTION POINT AT MACHINE

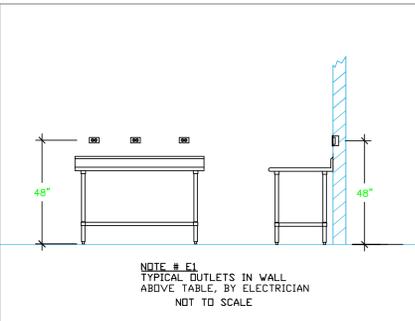

NOTE # E2
ALL NATIONAL, STATE, AND LOCAL CODES SHALL APPLY.

NOTE # E3
ALL ELECTRICAL CONNECTIONS AND HARDWARE REQUIRED TO BE PROVIDED BY ELECTRICAL CONTRACTOR.

NOTE # E4
ALL JUNCTION BOXES, OUTLETS, ETC. TO BE LOCATED SO AS TO NOT INTERFERE WITH EQUIPMENT.

NOTE # E5
ALL RELAYS, CONTRACTORS, STARTERS, AND SWITCHES REQUIRED FOR EXHAUST & SUPPLY FANS TO BE PROVIDED BY ELECTRICAL CONTRACTOR UNLESS SPECIFIED.

NOTE # E6
ELECTRICAL CONTRACTOR TO INTERCONNECT DISHMACHINE TO EXHAUST FAN FOR DISHMACHINE SO THAT THE FAN RUNS WHEN THE DISHMACHINE IS IN OPERATION.

NOTE # E7
ELECTRICAL CONTRACTOR TO INSTALL TABLE LIMIT SWITCH TO END OF CLEAN DISHTABLE TO THAT MACHINE STOPS WHEN SWITCH IS DEPRESSED.

NOTE # E8
ELECTRICAL CONTRACTOR TO CONNECT DRAIN LINE HEATER, PAN HEATER AND DODR HEATER FOR WALK-IN FREEZER.

Equipment ELECTRICAL Service Requirements

All Dimensions to be verified on the job site. Actual locations for floor drains, and any ventilating equipment to be determined by Engineer. Mechanical, Plumbing & Electrical to be checked and verified by Customers MEP Engineer. Remote Condensing Units to be located by Architect. Exhaust & Supply fans to be located by Architect.

Baha Mar Jazz Bar
Nassau, Bahamas

uni-source SUPPLY
INTERNATIONAL INC.

2055 W 73rd Street, Miami, FL 33016
Ph: (305)826-8696 Fax: (305)826-9131

2	Updates from Ownership	4-3-24
3	Updates from Ownership	4-9-24
4	Updates from Ownership	4-11-24
5	Finalized MEP after updates	5-1-24
No.	Revision/Issue	Date

Date
May 1, 2024
Drawn By
Dayne Gauntlett
Scale
1/4" = 1'0"

Sheet
FS-3.1

