

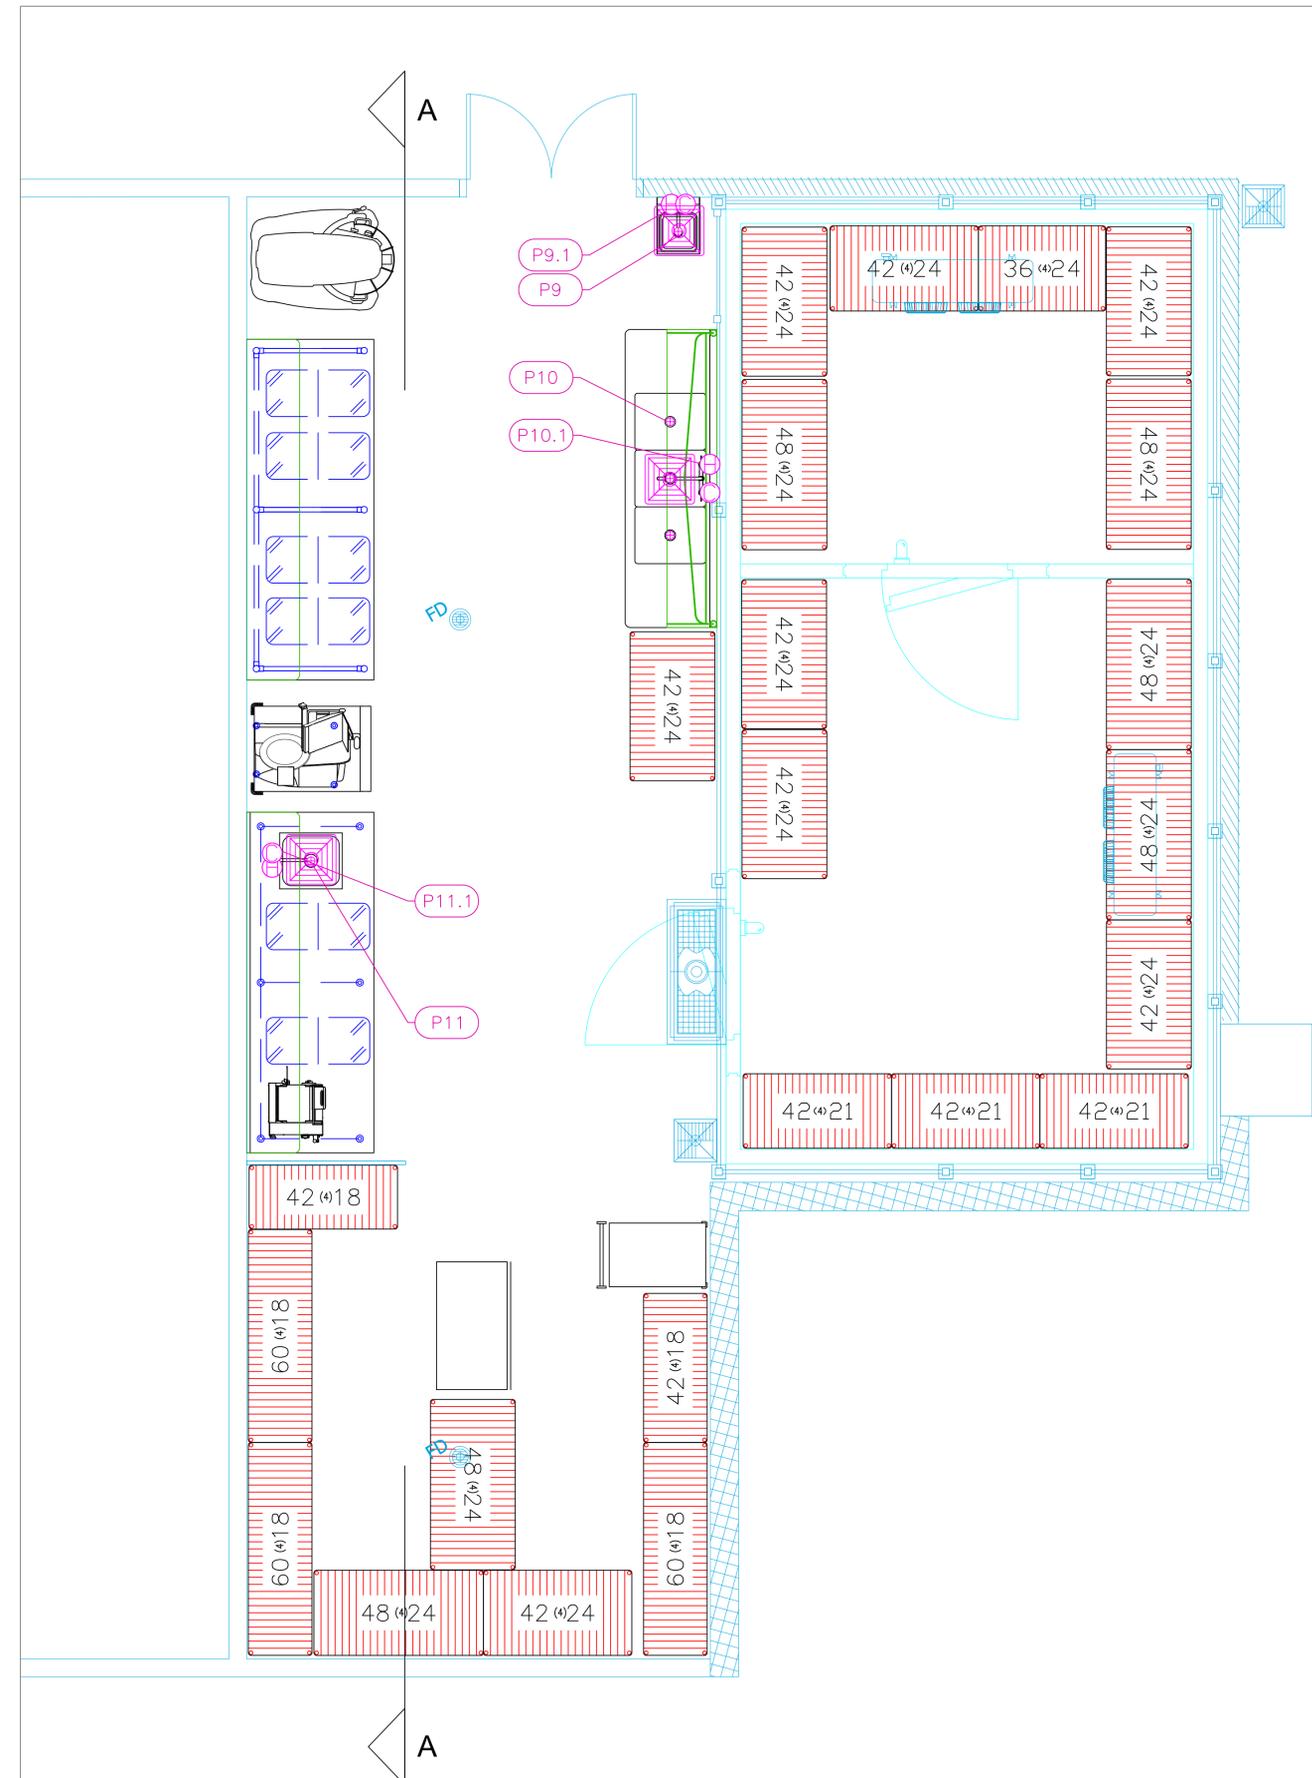
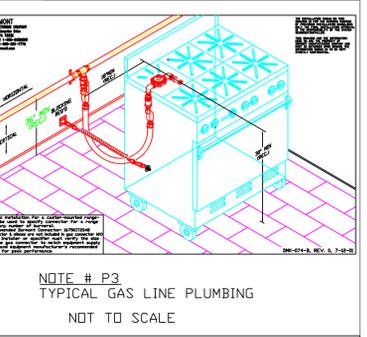


PLUMBING SCHEDULE											
ITEM NO.	DESCRIPTION	COLD WATER SIZE	HOT WATER R SIZE	H&C Rough-In	DIRECT WASTE SIZE	DIRECT WASTE AFF	INDIRECT WASTE SIZE	GAS SIZE (IN)	GAS MBT U	QTY	PLUMBING REMARKS
9	Hand Sink						1-1/2"			1	
9.1	Wall / Splash Mount Faucet	1/2"	1/2"	12"						1	
10	Three (3) Compartment Sink						(3) 1-1/2"			1	(1) set of 1/2" faucet holes, 8" OC
10.1	Wall / Splash Mount Faucet	1/2"	1/2"	12"						1	
11	Work Table, Stainless Steel Top									1	
	Weld-In Sink						1-1/2"			1	
11.1	Deck Mount Faucet	1/2"	1/2"	12"						1	
14	Ice Maker, Cube-Style	3/4"		24"				3/4"		1	Water from Filter
	Ice Bin for Ice Machines							3/4"		1	Waste to floor sink
14.1	Water Filtration System, Parts & Accessories	1/2"		36"						1	

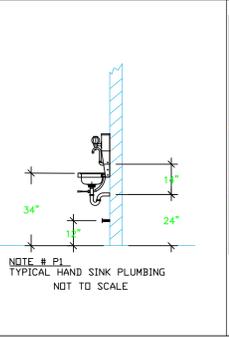

**LEGEND - PLUMBING CONNECTIONS**

- HW-HOT WATER, OR CW-COLD WATER
- GAS
- WASTE, DIRECT-CONNECTED
- WASTE, INDIRECT to Floor Sink, or Floor Drain
- ⊕ FUNNEL FLOOR DRAIN Josam 30000-E3
- ⊙ FLOOR DRAIN Josam 30000-A3
- ⊠ FLOOR SINK Proflo PF42856 or Zurn FS12
- ⊖ FILTERED WATER, at machine.

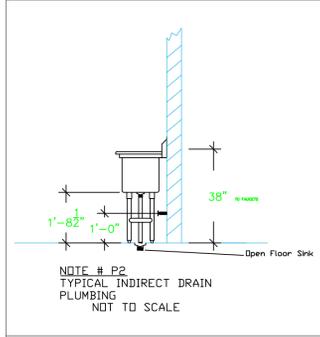

**NOTE # P4**  
ALL NATIONAL, STATE, AND LOCAL CODES SHALL APPLY

**NOTE # P5**  
ALL PLUMBING CONNECTIONS TO BE EXTENDED AND INTERCONNECTED TO EQUIPMENT AND ALL HARDWARE REQUIRED TO BE PROVIDED BY PLUMBING CONTRACTOR

**NOTE # P6**  
PLUMBING CONTRACTOR TO VERIFY THAT ALL EQUIPMENT IS INSTALLED WITH THE APPROPRIATE GAS PRESSURE AND REGULATORS

**NOTE # P7**  
ALL WASTE LINES AND CONDENSATE LINES TO BE EXTEND FROM EQUIPMENT TO FLOOR DRAINS BY PLUMBING CONTRACTOR.

## Equipment PLUMBING Service Requirements

Actual Dimensions to be verified on the job site. Actual locations for floor drains, and any ventilating equipment to be determined by Engineer. Mechanical, Plumbing & Electrical to be checked and verified by Customers MEP Engineer. Remote Condensing Units to be located by Architect. Exhaust & Supply fans to be located by Architect.

**Baha Mar**  
**Leola Basement**  
**Nassau, Bahamas**

**LEOLA**  
*by world concepts*

**uni-source**  
SUPPLY

INTERNATIONAL INC.

2055 W 73rd Street, Miami, FL 33016  
Ph: (305)826-8696 Fax: (305)826-9131

3	Added Modifications	6-10-25
4	Added Modifications	6-25-25
5	Changed Mixer, Slicer, Combi Oven	7-16-25
6	Added MEP	7-17-25
7	Added By Other on Schedule	8-26-25

Date  
**August 26, 2025**

Drawn By  
**Dayne Gauntlett**

Scale  
**1/2" = 1'0"**

Sheet  
**FS-4.1**