


**Kitchen**

EQUIPMENT SCHEDULE					
ItemNo	Category	Mfr	Model	Quantity	Equipment Remarks
1	Work Table, L-Shaped	Advance Tabco	KTMS-308	1	New, not being Used
1-N	Work Table, L-Shaped	Advance Tabco	KTMS-309	1	
1.1	Overshelf	Advance Tabco	ODS-15-60	1	New, not being Used
1.1-N	Overshelf	Advance Tabco	ODS-15-36	1	
1.2	Heat Lamp	Nemco	6151-24	1	
1.3	Shelving, Wall Mounted	Advance Tabco	WS-12-36	2	
1.4	Shelving, Wall Mounted	Advance Tabco	WS-12-84	2	
1.5-N	Deck Mount Faucet	Krowne	15-410L	1	
3	Rapid Cook Oven	Merrychef	E1S	2	One of Two not being Used.
4	Reach-In Refrigerator	Continental Refrigerator	2RSESN	1	
5	Hand Sink	Advance Tabco	7-PS-56	1	New, not being Used
5-N	Work Table, Stainless Steel Top	Advance Tabco	TKMS-305	1	
6	Soiled Dishtable	Advance Tabco	DTU-U60-48R	1	
6.1	Mini Pre-Rinse Faucet Assembly	Krowne	18-708L	1	
7	Dishwasher, Undercounter	Hobart	CUH-1	1	
8	Ice Maker with Bin, Cube-Style	Hoshizaki	IM-200BAC	1	
8.1	Water Filtration System, Parts & Accessories	Krowne	KR-HS2-KIT	1	
10	Sandwich / Salad Preparation Refrigerator	Continental Refrigerator	SW36N10	1	New, not being Used
10-N	Reach-In Undercounter Freezer	Turbo Air	JUF-36-N	1	
11	Air Curtain	Berner	CHD10-1042A	1	
20-N	Bottle Storage Unit	Glastender	LDA-12S	1	
21-N	Nugget Ice Maker with Bin	Hoshizaki	F-330BAJ-C	1	
21.1-N	Water Filtration System, Parts & Accessories	Krowne	KR-HS2-KIT	1	
23-N	Ice Bin	Glastender	IBA-24	1	
24-N	Underbar Mixology Sink Unit	Glastender	MFT-8	1	
25-N	Blender Station	Glastender	BSA-12	1	
26-N	Speed Rail / Rack	ATS MFG	MET-SPS-30	2	

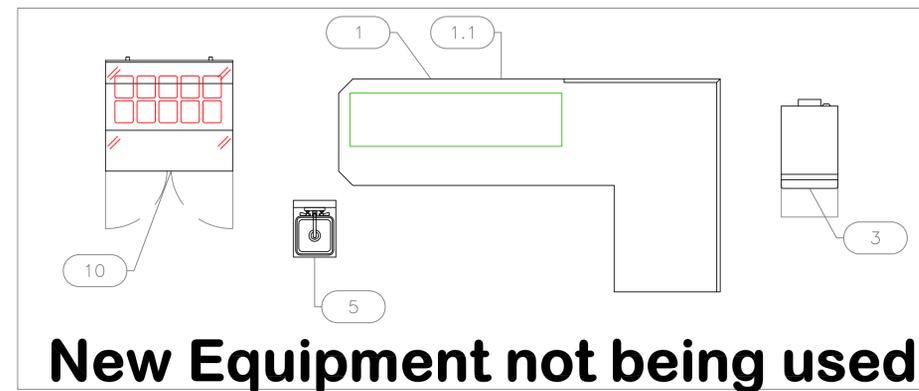

**New Equipment not being used.**

**EQUIPMENT LAYOUT**

All Dimensions to be verified on the job site.  
 Actual locations for floor drains, and any ventilating equipment to be determined by Engineer.  
 Mechanical, Plumbing & Electrical to be checked and verified by Customers MEP Engineer.  
 Remote Condensing Units to be located by Architect.  
 Exhaust & Supply fans to be located by Architect.

**Baha Mar - Nexus Club**  
**IKitchen**  
 Nassau, Bahamas

**uni-source**  
 SUPPLY

INTERNATIONAL INC.

2055 W 73rd Street, Miami, FL 33016  
 Ph: (305)826-8696 Fax: (305)826-9131

3	Added Equipment MEP Information.	4-04-25
4	Added Bar Equipment and modifications	9-09-25
5	Added Modifications to equipment	9-12-25
6	Made kitchen changes as discussed, Added Sports Bar	9-15-25
No.	Revision/Issue	Date

Date  
**Sept 15, 2025**  
 Drawn By  
**Dayne Gauntlett**  
 Scale  
**1/2" = 1'0"**

Sheet  
**FS-1.1**




INTERNATIONAL INC.

2055 W 73rd Street, Miami, FL 33016  
 Ph: (305)826-8696 Fax: (305)826-9131


3	Added Equipment MEP Information.	4-04-25
4	Added Bar Equipment and modifications	9-09-25
5	Added Modifications to equipment	9-12-25
6	Made kitchen changes as discussed, Added Sports Bar	9-15-25
No.	Revision/Issue	Date

Date  
**Sept 15, 2025**  
 Drawn By  
**Dayne Gauntlett**  
 Scale  
**1/2" = 1'0"**

Sheet  
**FS-1.1**

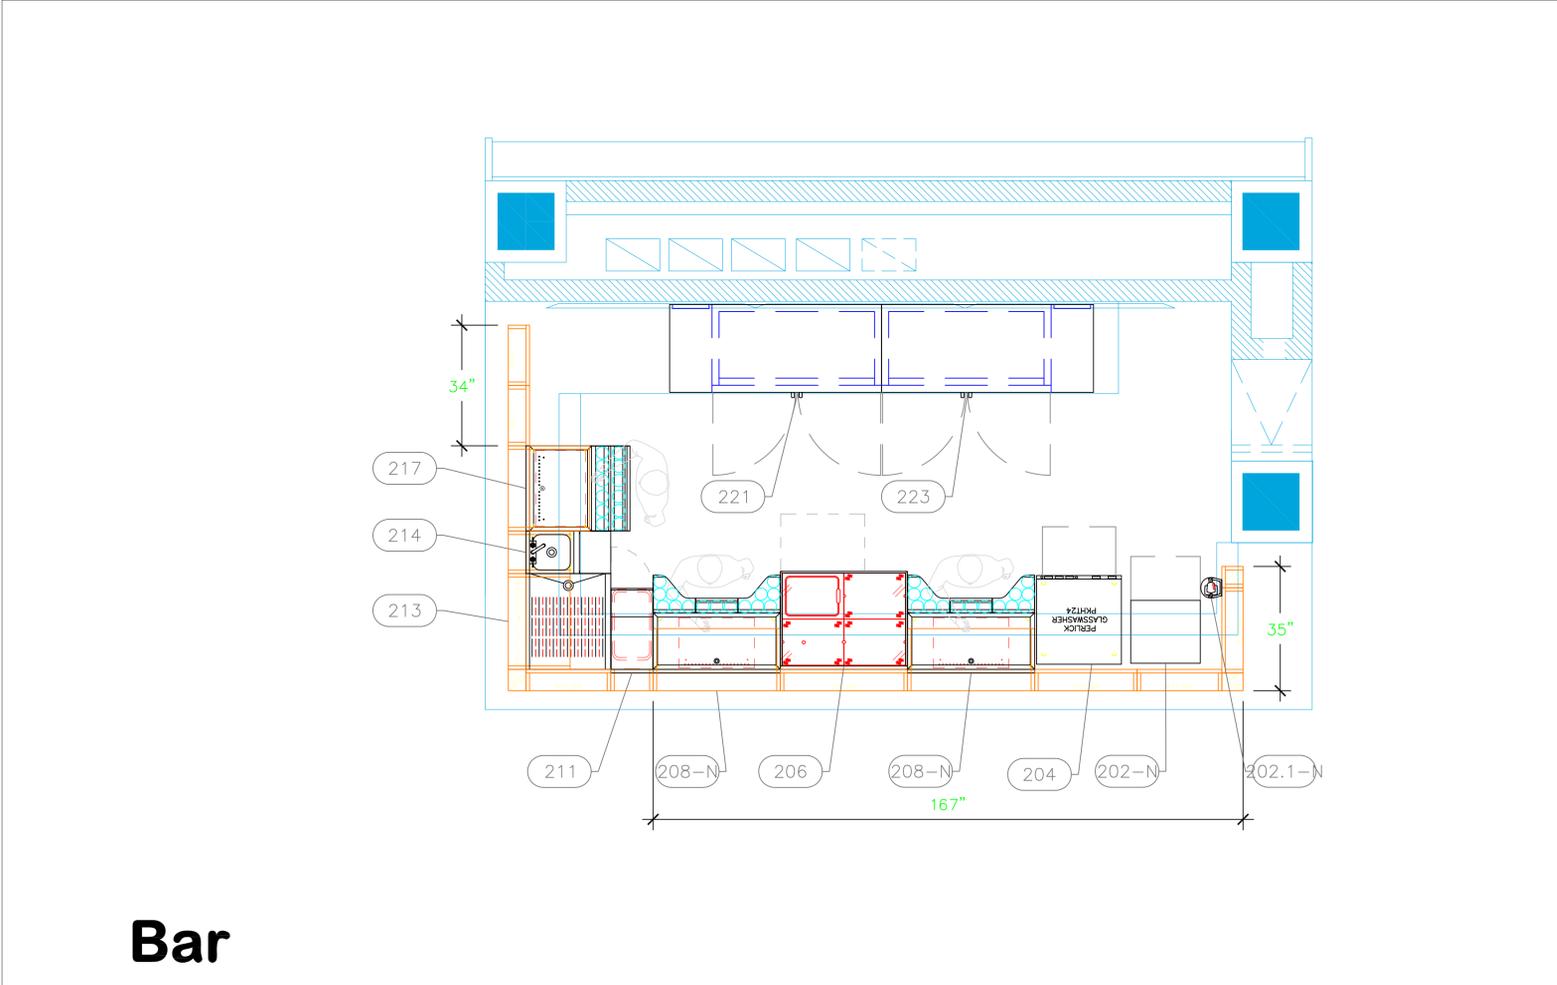

**Bar**

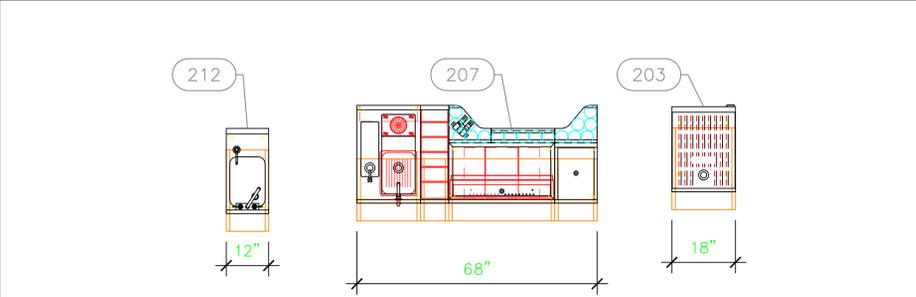


**Old Equipment not being used.**

**EQUIPMENT LAYOUT**

All Dimensions to be verified on the job site.  
 Actual locations for floor drains, and any ventilating equipment to be determined by Engineer.  
 Mechanical, Plumbing & Electrical to be checked and verified by Customers MEP Engineer.  
 Remote Condensing Units to be located by Architect.  
 Exhaust & Supply fans to be located by Architect.

EQUIPMENT SCHEDULE					
ItemNo	Category	Mfr	Model	Quantity	Equipment Remarks
202-N	Ice Maker with Bin, Cube-Style	Hoshizaki	IM-50BAA-LM	1	
202.1-N	Water Filtration System, Parts & Accessories	Krowne	KR-HS1-KIT	1	
203	Drainboard	Perlick	TSF18SC	1	Existing Bar
204	Glasswasher, Undercounter / Underbar	Perlick	PKHT24	1	Existing Bar
206	Refrigerated Work Top	Perlick	BBS36C	1	Existing Bar
207	Ice Bin with Sink combo Unit	Perlick	PTE68-A	1	Existing Bar
208-N	Ice Bin	Perlick	TSC36IC10	2	
211	Trash Receptacle	Perlick	TS12TRA	1	Existing Bar
212	Hand Sink	Perlick	TSF12HS	1	Existing Bar
213	Custom Corner	Perlick	CM1701011-27000C6	1	Existing Bar
214	Blender Station	Perlick	TSF12BS	1	Existing Bar
217	Ice Bin	Perlick	TS24IC-EC10	1	Existing Bar
221	Back Bar Cabinet, Refrigerated	Perlick	BBS60	1	Existing Bar
223	Back Bar Cabinet, Refrigerated	Perlick	BBS60	1	Existing Bar
224-N	Modular Bar System	Perlick	MBS	40	

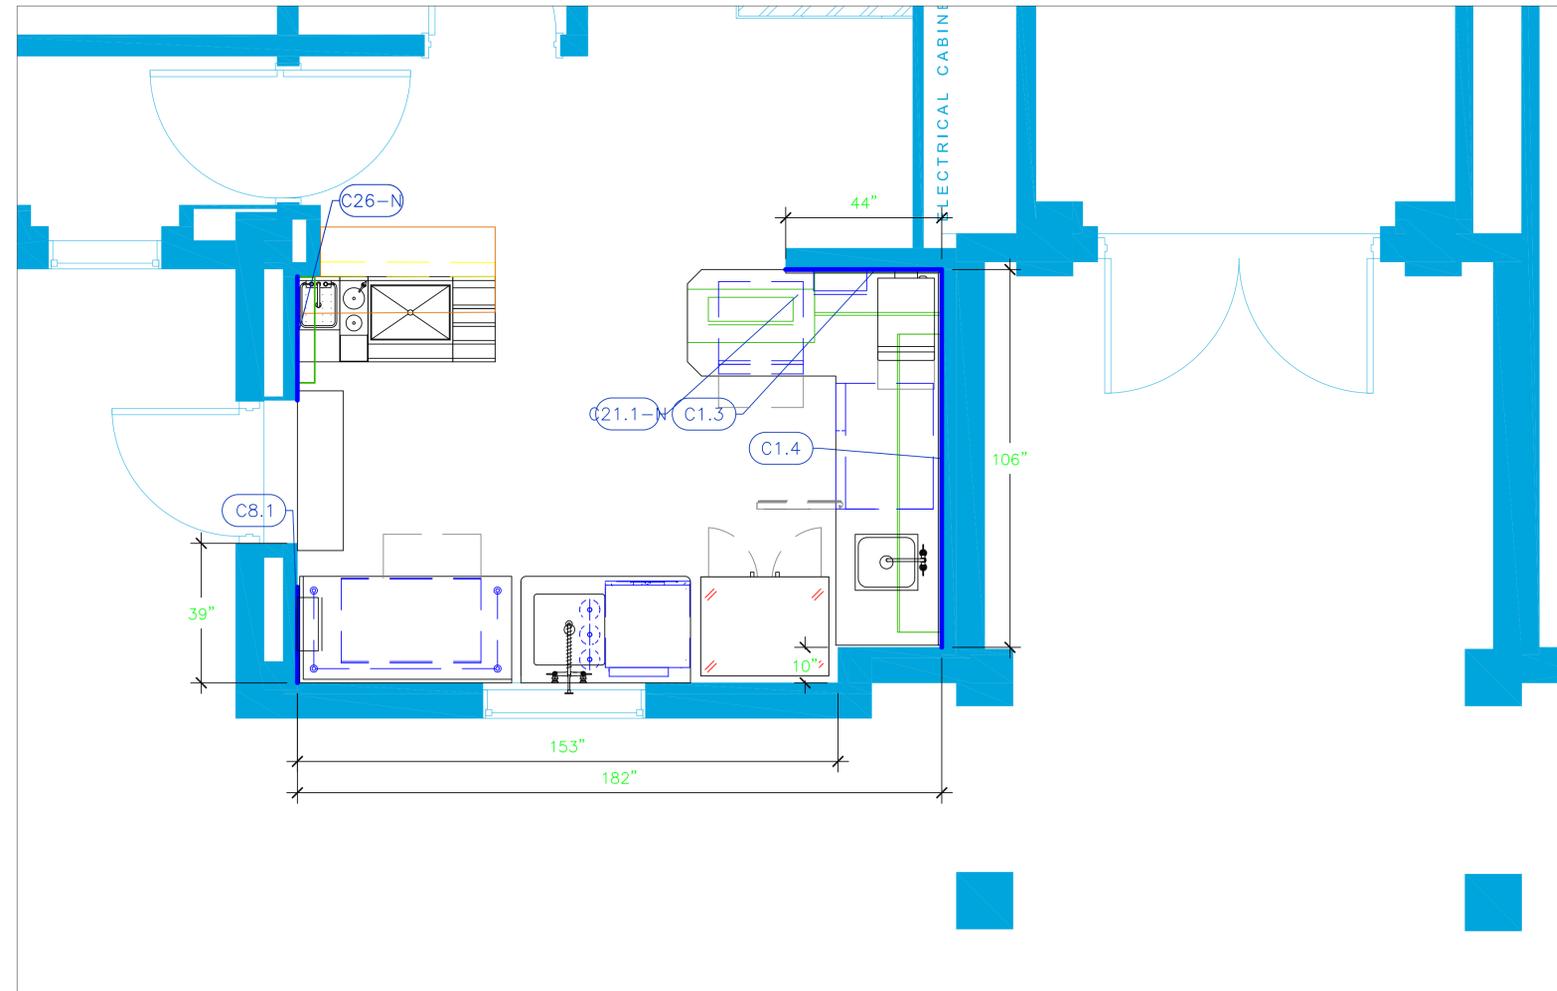

Baha Mar - Nexus Club  
 IKitchen  
 Nassau, Bahamas







INTERNATIONAL INC.  
 2055 W 73rd Street, Miami, FL 33016  
 Ph:(305)826-8696 Fax:(305)826-9131

Mechanical Schedule							
ITEM NO.	QTY	DISCRIPTION	EXHAUST (L X W)	EXHAUST (CFM)	Makeup Vent Width	SUPPLY (CFM)	Ventilation Remarks
1.3	2	Shelving, Wall Mounted					Wall Backing, See Note M9
1.4	2	Shelving, Wall Mounted					Wall Backing, See Note M9
8.1	1	Water Filtration System, Parts & Accessories					Wall Backing, See Note M9
21.1	1	Water Filtration System, Parts & Accessories					Wall Backing, See Note M9
26	2	Speed Rail / Rack					Wall Backing, See Note M9

3	Added Equipment MEP Information.	4-04-25
4	Added Bar Equipment and modifications	9-09-25
5	Added Modifications to equipment	9-12-25
6	Made kitchen changes as discussed, Added Sports Bar	9-15-25
No.	Revision/Issue	Date

Date  
 Sept 15, 2025  
 Drawn By  
 Dayne Gauntlett  
 Scale  
 1/2" = 1'0"

Sheet  
**FS-2.1**

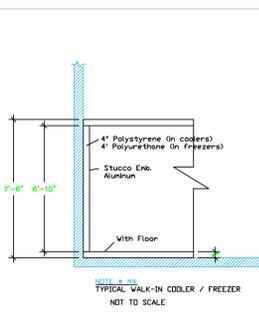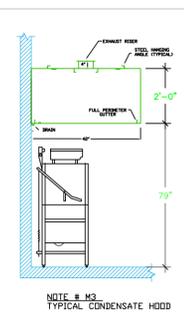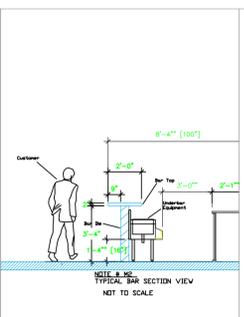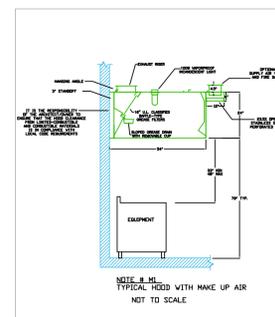

- LEGEND - MECHANICAL**
- EXHAUST DUCT COLLAR
  - SUPPLY DUCT COLLAR
  - INWALL BACKING FOR WALL SHELVES
  - RECESSED FLOOR
  - RAISED EQUIPMENT PAD

**NOTE # M5:** ALL NATIONAL, STATE, AND LOCAL CODES SHALL APPLY.

**NOTE # M6:** ARCHITECT OR ENGINEER TO SIZE AND LOCATE, CONTRACTOR TO PROVIDE ALL OPENINGS FOR DUCTS, PLUMBING LINES, ELECTRICAL LINES, AND REFRIGERATION LINES, AS REQUIRED BY EQUIPMENT.

**NOTE # M7:** SUPPLY FANS TO BE LOCATED A MINIMUM OF 10' FROM EXHAUST FANS.

**NOTE # M8:** SHOP DRAWING WILL BE PROVIDED BY MANUFACTURER FOR HOOD, EXHAUST FANS, & SUPPLY FANS, ONCE ORDER IS PLACE WITH.


**NOTE # M9:** GENERAL CONTRACTOR TO PROVIDE 2\"/>

**NOTE # M10:** CEILING HEIGHTS TO BE VERIFIED FOR SUFFICIENT CLEARANCE FOR EQUIPMENT.

**NOTE # M11:** REFRIGERATION CONTRACTOR TO HANG EVAPORATORS FOR WALK-IN, RUN & CHARGE LINES BETWEEN EVAP. & CONDENSING UNIT.

## Equipment MECHANICAL Service Requirements

All Dimensions to be verified on the job site. Actual locations for floor drains, and any ventilating equipment to be determined by Engineer. Mechanical, Plumbing & Electrical to be checked and verified by Customers MEP Engineer. Remote Condensing Units to be located by Architect. Exhaust & Supply Fans to be located by Architect.

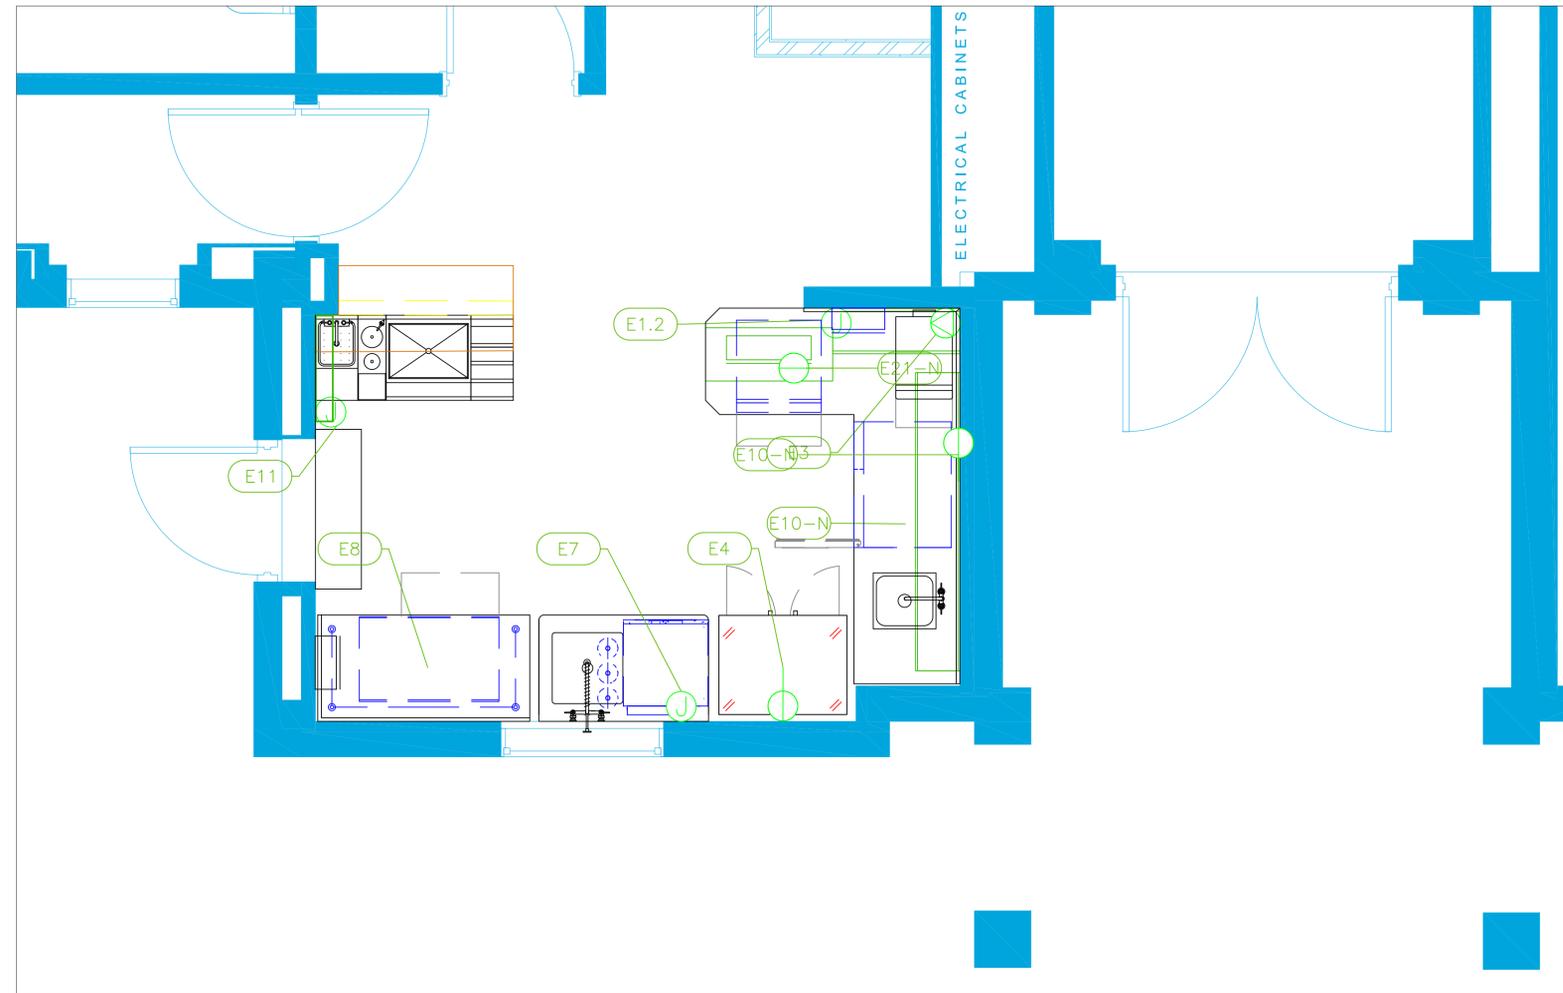

**Baha Mar - Nexus Club**  
**IKitchen**  
 Nassau, Bahamas  
  
**BAHA MAR**



INTERNATIONAL INC.  
 2055 W 73rd Street, Miami, FL 33016  
 Ph:(305)826-8696 Fax:(305)826-9131


**ELECTRICAL SCHEDULE**

ItemNo	Category	Voltage	Cycle	Phase	Amps	Hp	NEMA	ConnectionType	Rough-In AFF	Quantity	Electrical Remarks
1	Table "L"	115	60	1	15			Duplex	48"	1	
1.2	Heat Lamp	120	60	1	4.2			J-Box	18"	1	
3	Rapid Cook Oven	208/240	60	1			6-15P	Special	48"	1	
4	Reach-In Refrigerator	115	60	1	6.6	1/3	5-15P	Simplex	18"	1	
7	Dishwasher, Undercounter	208-240	60	1	24.2-27.5			J-Box	18"	1	
8	Ice Maker with Bin, Cube-Style	115	60	1	7.5		5-15P	Simplex	18"	1	
10	Undercounter Refrigerator	115	60	1	4.5		5-15P	Simplex	18"	1	
11	Air Curtain	120	60	1		1/2		J-Box	80"	1	
21	Ice Maker with Bin, Cube-Style	115	60	1	5.0		5-15P	Simplex	18"	1	

3	Added Equipment MEP Information.	4-04-25
4	Added Bar Equipment and modifications	9-09-25
5	Added Modifications to equipment	9-12-25
6	Made kitchen changes as discussed, Added Sports Bar	9-15-25
No.	Revision/Issue	Date

**LEGEND -- ELECTRICAL CONNECTIONS**

-  DUPLEX RECEPT., 15-AMP, 120-VOLT, GROUND TYPE, HORIZONTAL MOUNT
-  SIMPLEX RECEPT., 120-VOLT, GROUND TYPE, HORIZONTAL MOUNT
-  SPECIAL PURPOSE OUTLET, GROUND TYPE, HORIZONTAL MOUNT
-  JUNCTION BOX, DIRECT CONNECTION
-  DISCONNECT SWITCH, DIRECT CONNECTION
-  FLOOR/CEILING RECEPTACLE AS INDICATED
-  (2) Telephone + (2) Data
-  FIELD CONNECTIONS
-  HARD WIRE CONNECTION POINT AT MACHINE

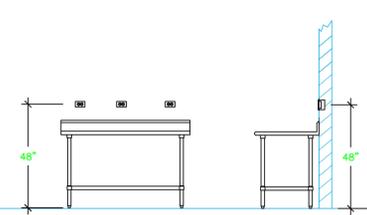

NOTE # E1  
TYPICAL OUTLETS IN WALL ABOVE TABLE, BY ELECTRICIAN NOT TO SCALE

NOTE # E2  
ALL NATIONAL, STATE, AND LOCAL CODES SHALL APPLY

NOTE # E3  
ALL ELECTRICAL CONNECTIONS AND HARDWARE REQUIRED TO BE PROVIDED BY ELECTRICAL CONTRACTOR

NOTE # E4  
ALL JUNCTION BOXES, OUTLETS, ETC. TO BE LOCATED SO AS TO NOT INTERFERE WITH EQUIPMENT

NOTE # E5  
ALL RELAYS, CONTRACTORS, STARTERS, AND SWITCHES REQUIRED FOR EXHAUST & SUPPLY FANS TO BE PROVIDED BY ELECTRICAL CONTRACTOR UNLESS SPECIFIED

NOTE # E6  
ELECTRICAL CONTRACTOR TO INTERCONNECT DISHMACHINE TO EXHAUST FAN FOR DISHMACHINE SO THAT THE FAN RUNS WHEN THE DISHMACHINE IS IN OPERATION.

NOTE # E7  
ELECTRICAL CONTRACTOR TO INSTALL TABLE LIMIT SWITCH TO END OF CLEAN DISHTABLE TO THAT MACHINE STOPS WHEN SWITCH IS DEPRESSED.

NOTE # E8  
ELECTRICAL CONTRACTOR TO CONNECT DRAIN LINE HEATER, PAN HEATER AND DOOR HEATER FOR WALK-IN FREEZER.

## Equipment ELECTRICAL Service Requirements


All Dimensions to be verified on the job site. Actual locations for floor drains, and any ventilating equipment to be determined by Engineer. Mechanical, Plumbing & Electrical to be checked and verified by Customers MEP Engineer. Remote Condensing Units to be located by Architect. Exhaust & Supply fans to be located by Architect.

Date  
**Sept 15, 2025**

Drawn By  
**Dayne Gauntlett**

Scale  
**1/2" = 1'0"**

Sheet  
**FS-3.1**

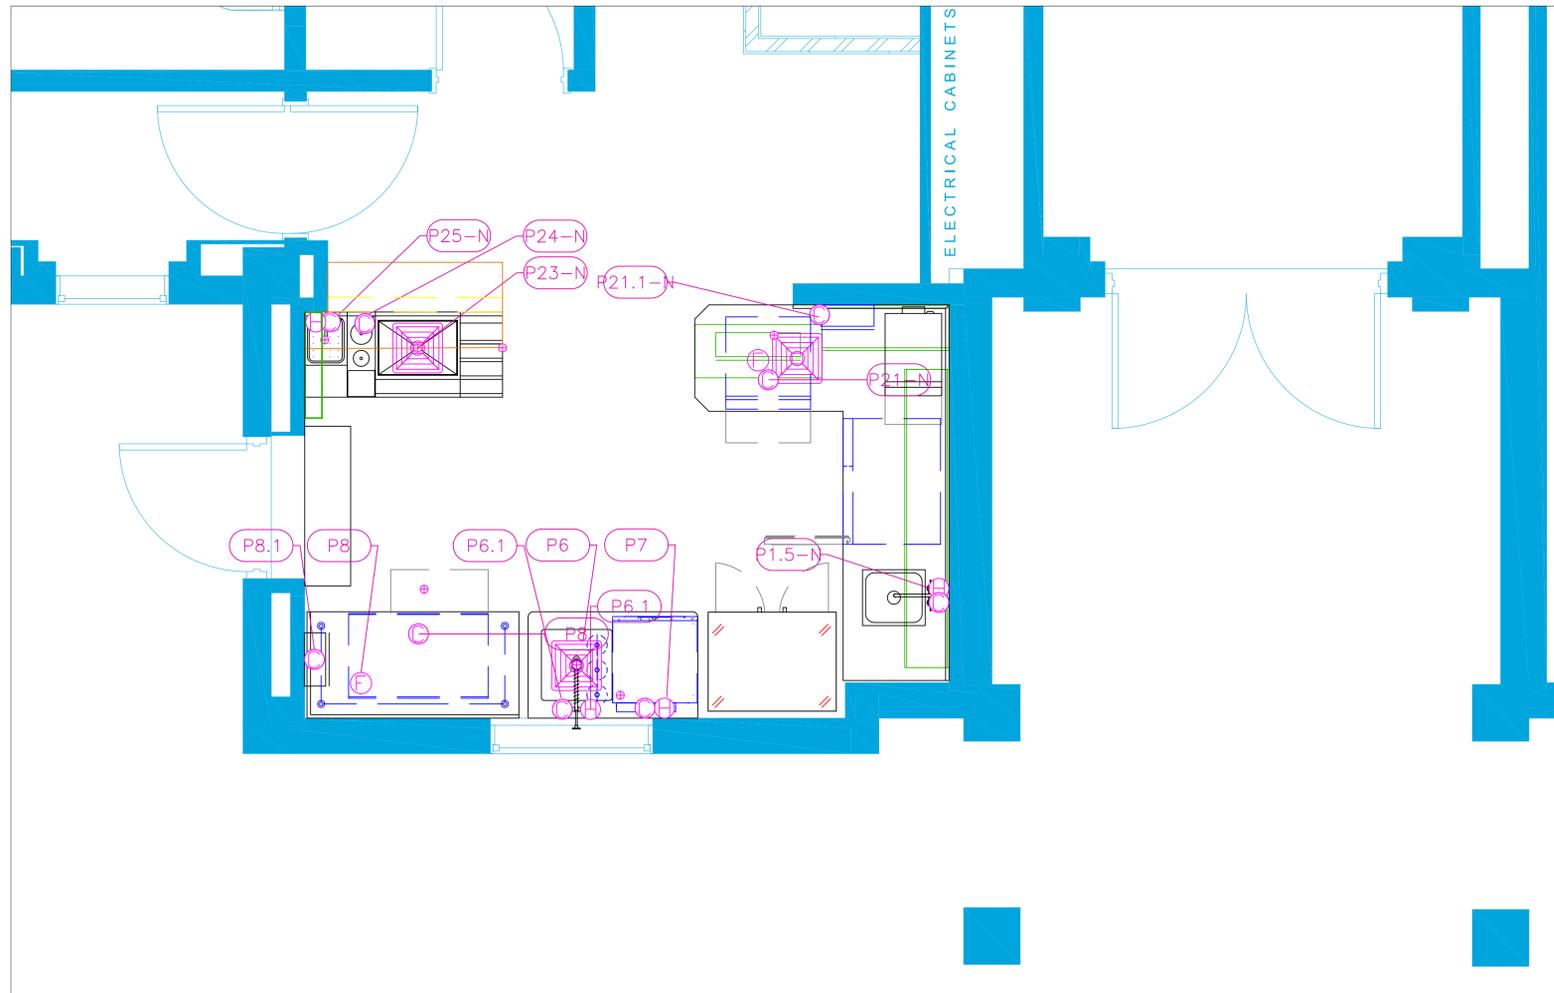

**Baha Mar - Nexus Club**  
**IKitchen**  
 Nassau, Bahamas






INTERNATIONAL INC.  
 2055 W 73rd Street, Miami, FL 33016  
 Ph: (305) 826-8696 Fax: (305) 826-9131

No.	Revision/Issue	Date
3	Added Equipment MEP Information.	4-04-25
4	Added Bar Equipment and modifications	9-09-25
5	Added Modifications to equipment	9-12-25
6	Made kitchen changes as discussed, Added Sports Bar	9-15-25

Date  
**Sept 15, 2025**  
 Drawn By  
**Dayne Gauntlett**  
 Scale  
**1/2" = 1'0"**

Sheet  
**FS-4.1**

PLUMBING SCHEDULE											
ITEM NO.	DESCRIPTION	COLD WATER SIZE	HOT WATER SIZE	H&C Rough -In	DIRECT WASTE SIZE	DIRECT WASTE AFF	INDIRECT WASTE SIZE	GAS SIZE (I N)	GAS MBTU	QTY	PLUMBING REMARKS
1	Table "L"				1-1/2"	24"				1	
1.5	Deck Mount Faucet	1/2"	1/2"	12"						1	
6.1	Mini Pre-Rinse Faucet Assembly	1/2"	1/2"	12"						1	
7	Dishwasher, Undercounter	3/4"	3/4"	12"			3/4"			1	Waste to Floor Sink
8	Ice Maker with Bin, Cube-Style	1/2"		n/a			3/4"			1	Water from Filter
8.1	Water Filtration System, Parts & Accessories	1/2"		12"						1	
21	Ice Maker with Bin, Cube-Style	3/4"		n/a			3/4"			1	Water from filter
21.1	Water Filtration System, Parts & Accessories	3/4"		12"						1	Water to Ice Machine
23	Ice Bin			12"			1-1/2"			1	
24	Underbar Mixology Sink Unit	3/8"		12"			1-1/2"			1	push-down rinsers faucet, Dipper faucet waste
25	Blender Station	3/8"	3/8"	12"			1-1/2"			1	Sink faucet

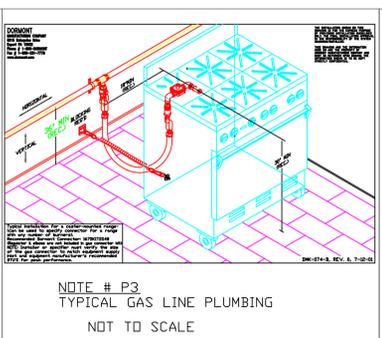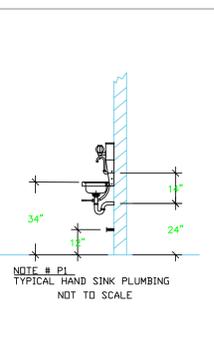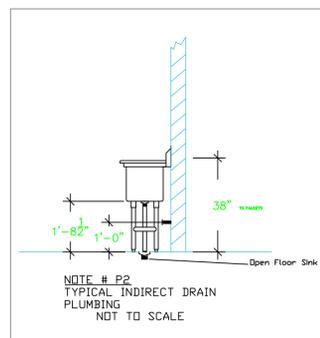

- LEGEND -- PLUMBING CONNECTIONS**
- HW-HOT WATER, OR CW-COLD WATER
  - GAS
  - WASTE, DIRECT-CONNECTED
  - WASTE, INDIRECT to Floor Sink, or Floor Drain
  - FUNNEL FLOOR DRAIN Josam 30000-E3
  - FLOOR DRAIN Josam 30000-A3
  - FLOOR SINK Proflo PF42856 or Zurn FS12
  - FILTERED WATER, at machine.

**NOTE # P4:** ALL NATIONAL, STATE, AND LOCAL CODES SHALL APPLY


**NOTE # P5:** ALL PLUMBING CONNECTIONS TO BE EXTENDED AND INTERCONNECTED TO EQUIPMENT AND ALL HARDWARE REQUIRED TO BE PROVIDED BY PLUMBING CONTRACTOR

**NOTE # P6:** PLUMBING CONTRACTOR TO VERIFY THAT ALL EQUIPMENT IS INSTALLED WITH THE APPROPRIATE GAS PRESSURE AND REGULATORS

**NOTE # P7:** ALL WASTE LINES AND CONDENSATE LINES TO BE EXTEND FROM EQUIPMENT TO FLOOR DRAINS BY PLUMBING CONTRACTOR.

## Equipment PLUMBING Service Requirements

All Dimensions to be verified on the job site. Actual locations for floor drains, and any ventilating equipment to be determined by Engineer. Mechanical, Plumbing & Electrical to be checked and verified by Customers MEP Engineer. Remote Condensing Units to be located by Architect. Exhaust & Supply fans to be located by Architect.

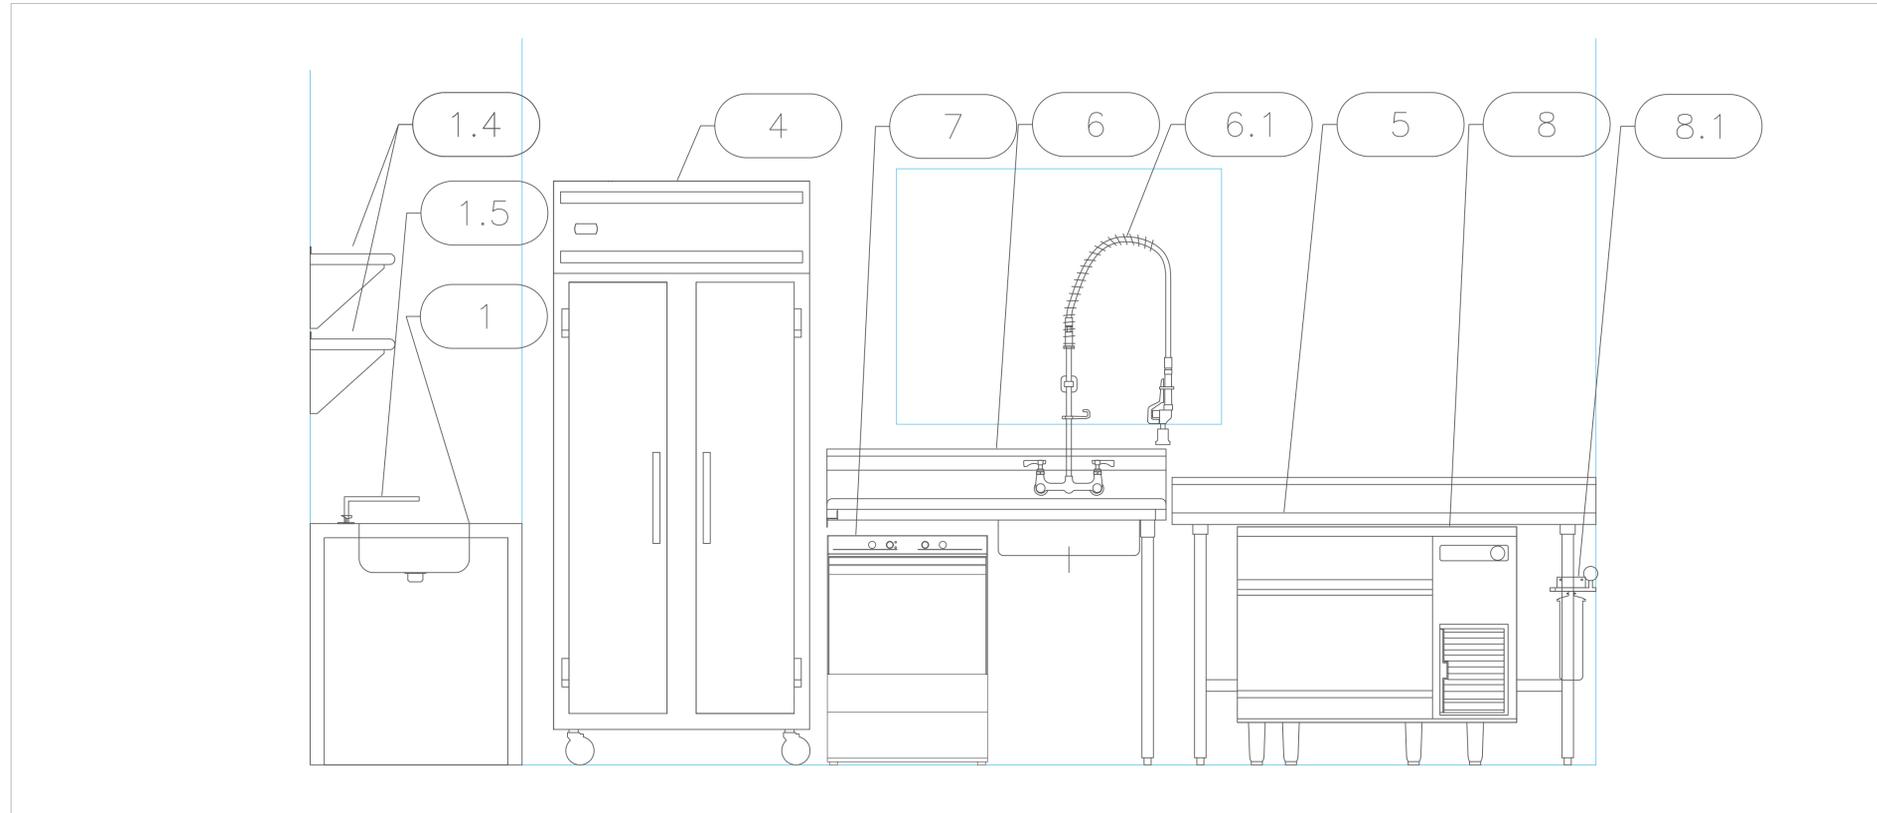

**Baha Mar - Nexus Club**  
**IKitchen**  
 Nassau, Bahamas




2055 W 73rd Street, Miami, FL 33016  
 Ph: (305)826-8696 Fax: (305)826-9131

3	Added Equipment MEP Information.	4-04-25
4	Added Bar Equipment and modifications	9-09-25
5	Added Modifications to equipment	9-12-25
6	Made kitchen changes as discussed, Added Sports Bar	9-15-25
No.	Revision/Issue	Date

Date  
**Sept 15, 2025**  
 Drawn By  
**Dayne Gauntlett**  
 Scale  
**1" = 1'**

Sheet  
**FS-5.1**