



Carnival Cruise Lines
Half Moon Cay
 Eleuthera, Bahamas




INTERNATIONAL INC.
 2055 W 73rd Street, Miami, FL 33016
 Ph: (305)826-8696 Fax: (305)826-9131


No.	Revision/Issue	Date
1	Preliminary Layout	11-20-23
2	Added Main Kitchen	1-26-24
3	Major Update after site visit.	9-12-24
4	Added Elec & Plumbing Information.	9-20-24

Date
Sept 20, 2024
 Drawn By
Dayne Gauntlett
 Scale
NTS

Sheet
FS-1.0

SITE OVERVIEW

All Dimensions to be verified on the job site.
 Actual locations for floor drains, and any ventilating equipment to be determined by Engineer.
 Mechanical, Plumbing & Electrical to be checked and verified by Customers MEP Engineer.
 Remote Condensing Units to be located by Architect.
 Exhaust & Supply fans to be located by Architect.

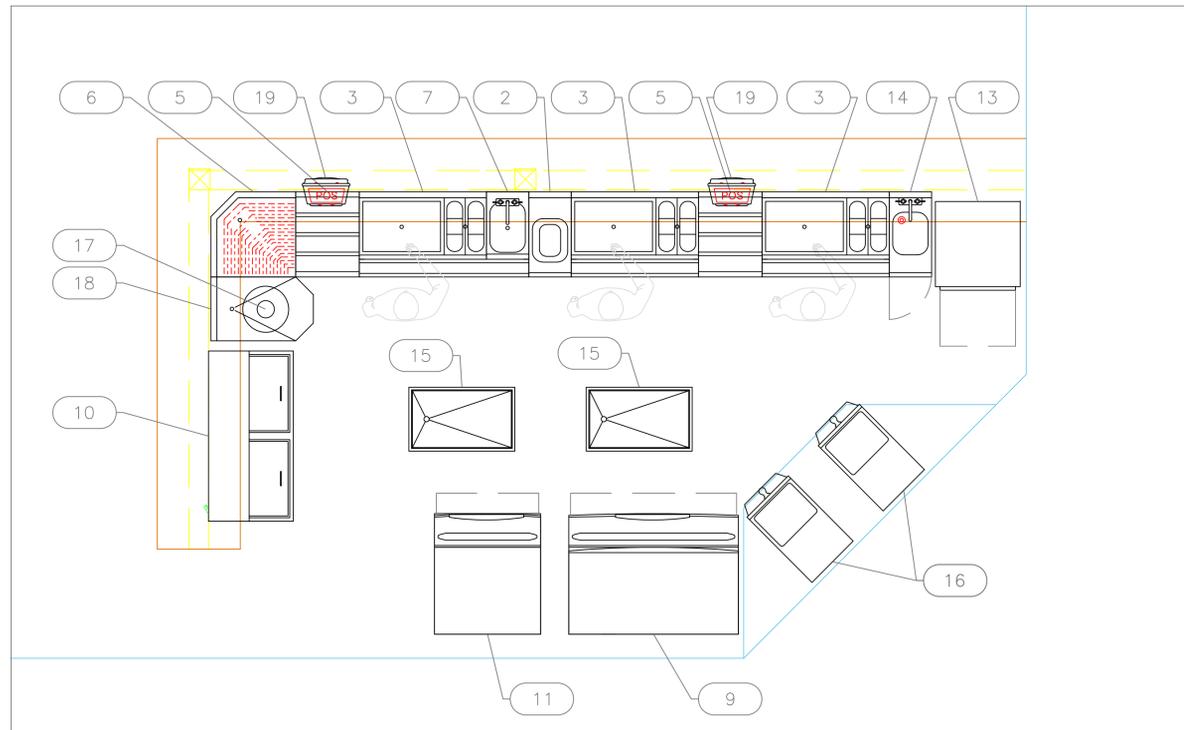


I wish I could stay here forever

EQUIPMENT SCHEDULE					
ItemNo	Category	Mfr	Model	Quantity	Equipment Remarks
2	Underbar Add-On Unit	Krowne	KR24-T12	1	
3	Ice Bin with Bottle Wells	Krowne	KR19-M36L	3	
5	Bottle Storage Unit	Krowne	KR24-18RD	2	
6	Corner Angle Filler	Krowne	KR24-DRC90	1	
7	Hand Sink	Krowne	KR19-1C	1	
9	Ice Maker, Cube-Style	Manitowoc	IYT1900A	1	Existing
	Ice Bin for Ice Machines	Manitowoc	D970	1	Existing
10	Bottle Cooler	Glastender	ST48-S	1	Existing
11	Ice Maker, Cube-Style	Manitowoc	IDT1200A	1	
	Ice Bin for Ice Machines	Manitowoc	D570	1	
13	Dishwasher, Undercounter	Champion	UH130B	1	
14	Hand Sink	Krowne	KR24-SD12C	1	
15	Iced Beer Display	Glastender	IBM-18X30	2	
16	Frozen Beverage Machine	Frosty Factory	137A	2	
17	Ice Shaver	Hamilton Beach	HBS1400	1	Existing
18	Blender Station	Krowne	KR29-18FD	1	
19	POS System	POS	POS	2	By Owner/Operator

EQUIPMENT LAYOUT

All Dimensions to be verified on the job site.
Actual locations for floor drains, and any ventilating equipment to be determined by Engineer.
Mechanical, Plumbing & Electrical to be checked and verified by Customers MEP Engineer.
Remote Condensing Units to be located by Architect.
Exhaust & Supply fans to be located by Architect.

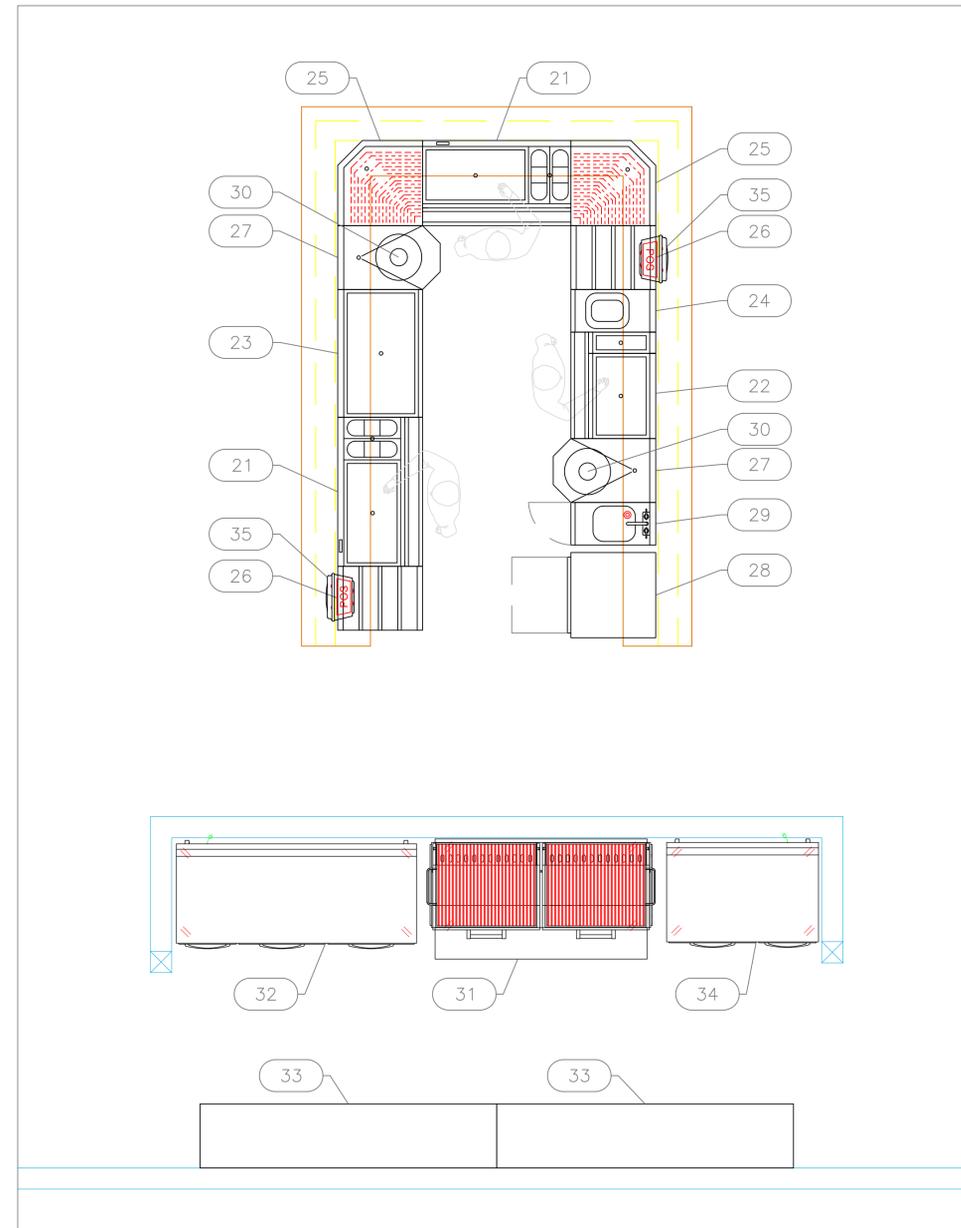

Lobster Shack

EQUIPMENT SCHEDULE					
ItemNo	Category	Mfr	Model	Quantity	Equipment Remarks
21	Ice Bin with Bottle Wells	Krowne	KR19-M42R	2	
22	Ice Bin with Bottle Wells	Krowne	KR19-M30R	1	
23	Iced Beer Display	Krowne	KR24-CB36	1	
24	Underbar Add-On Unit	Krowne	KR24-T12	1	
25	Corner Angle Filler	Krowne	KR24-DRC90	2	
26	Bottle Storage Unit	Krowne	KR24-18RD	2	
27	Blender Station	Krowne	KR29-18FD	2	
28	Dishwasher, Undercounter	Champion	UH130B	1	
29	Hand Sink	Krowne	KR24-SD12C	1	
30	Ice Shaver	Hamilton Beach	HBS1400	2	
31	Charbroiler, Gas, Outdoor Grill	Magkitch'n (Middleby)	LPAGA-60T-LP	1	Existing
32	Refrigerated Work Top	Continental Refrigerator	RA68SNBS	1	
33	Dish Cabinet	Advance Tabco	DC-187	2	
34	WorkTop Freezer	Continental Refrigerator	FA43SNBS	1	
35	POS System	POS	POS	2	By Owner/Operator


Carnival Cruise Lines
Half Moon Cay
Eleuthera, Bahamas

INTERNATIONAL INC.
2055 W 73rd Street, Miami, FL 33016
Ph: (305)826-8696 Fax: (305)826-9131

No.	Revision/Issue	Date
1	Preliminary Layout	11-20-23
2	Added Main Kitchen	1-26-24
3	Major Update after site visit.	9-12-24
4	Added Elec & Plumbing Information.	9-20-24


Date
Sept 20, 2024
Drawn By
Dayne Gauntlett
Scale
1/2" = 1'

Sheet
FS-1.1

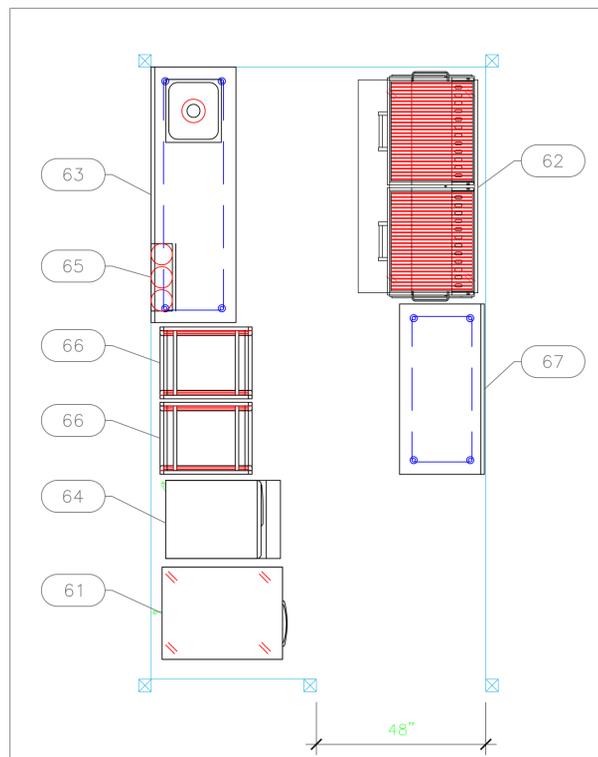

Private Beach Cabana Kitchen

EQUIPMENT SCHEDULE					
ItemNo	Category	Mfr	Model	Quantity	Equipment Remarks
61	Reach-In Refrigerator	Continental Refrigerator	1RN	1	
62	Charbroiler, Gas, Outdoor Grill	Magikitch'n (Middleby)	LPAGA-60T-LP	1	
63	Work Table, Stainless Steel Top	Advance Tabco	KMS-246	1	
	Weld-in Sink	Advance Tabco	TA-11J	1	
	Deck Mount Faucet	Krowne	15-310L	1	
64	Ice Maker, Cube-Style	Hoshizaki	KM-660MAJ	1	
	Ice Bin for Ice Machines	Hoshizaki	B-300SF	1	
65	Water Filtration System, Parts & Accessories	Krowne	KR-HS3-KIT	1	
66	Bun / Sheet Pan Rack	Advance Tabco	PR20-3W	2	
67	Work Table, Stainless Steel Top	Advance Tabco	KMS-244	1	

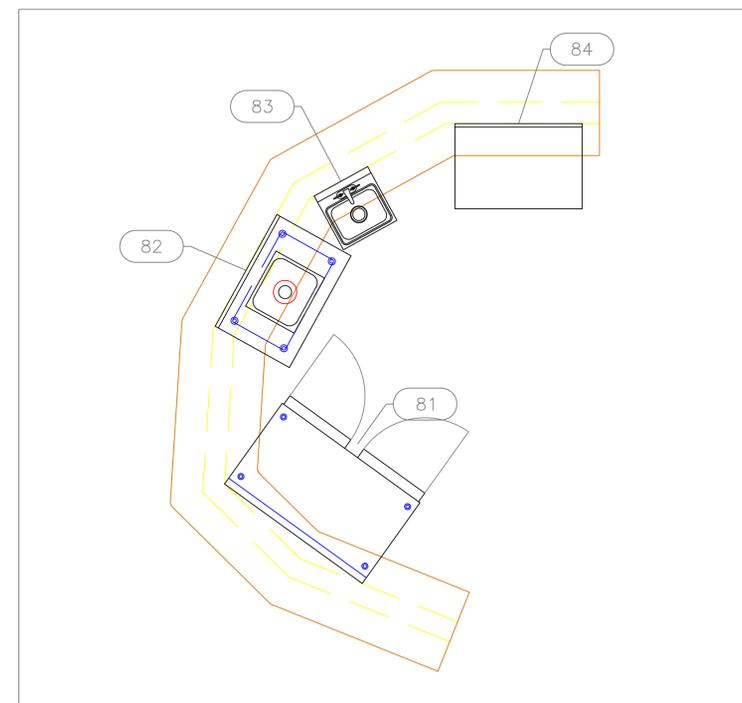

Private Beach Cabana Bar

EQUIPMENT SCHEDULE					
ItemNo	Category	Mfr	Model	Quantity	Equipment Remarks
81	Undercounter Refrigerator	Traulsen	UHT48-LR	1	Existing
82	Work Table, Stainless Steel Top	Advance Tabco	KMS-243	1	Existing
	Weld-in Sink	Advance Tabco	TA-11J	1	Existing
83	Hand Sink	Advance Tabco	7-PS-20	1	Existing
84	Work Table, Cabinet Base Hinged Doors	Advance Tabco	HK-SS-243M	1	Existing

EQUIPMENT LAYOUT

All Dimensions to be verified on the job site.
Actual locations for floor drains, and any ventilating equipment to be determined by Engineer.
Mechanical, Plumbing & Electrical to be checked and verified by Customers MEP Engineer.
Remote Condensing Units to be located by Architect.
Exhaust & Supply fans to be located by Architect.

Carnival Cruise Lines
Half Moon Cay
Eleuthera, Bahamas



uni-source
SUPPLY


INTERNATIONAL INC.

2055 W 73rd Street, Miami, FL 33016
Ph: (305)826-8696 Fax: (305)826-9131

1	Preliminary Layout	11-20-23
2	Added Main Kitchen	1-26-24
3	Major Update after site visit.	9-12-24
4	Added Elec & Plumbing Information.	9-20-24
No.	Revision/Issue	Date

Date
Sept 20, 2024
Drawn By
Dayne Gauntlett
Scale
1/2" = 1'

Sheet
FS-1.2

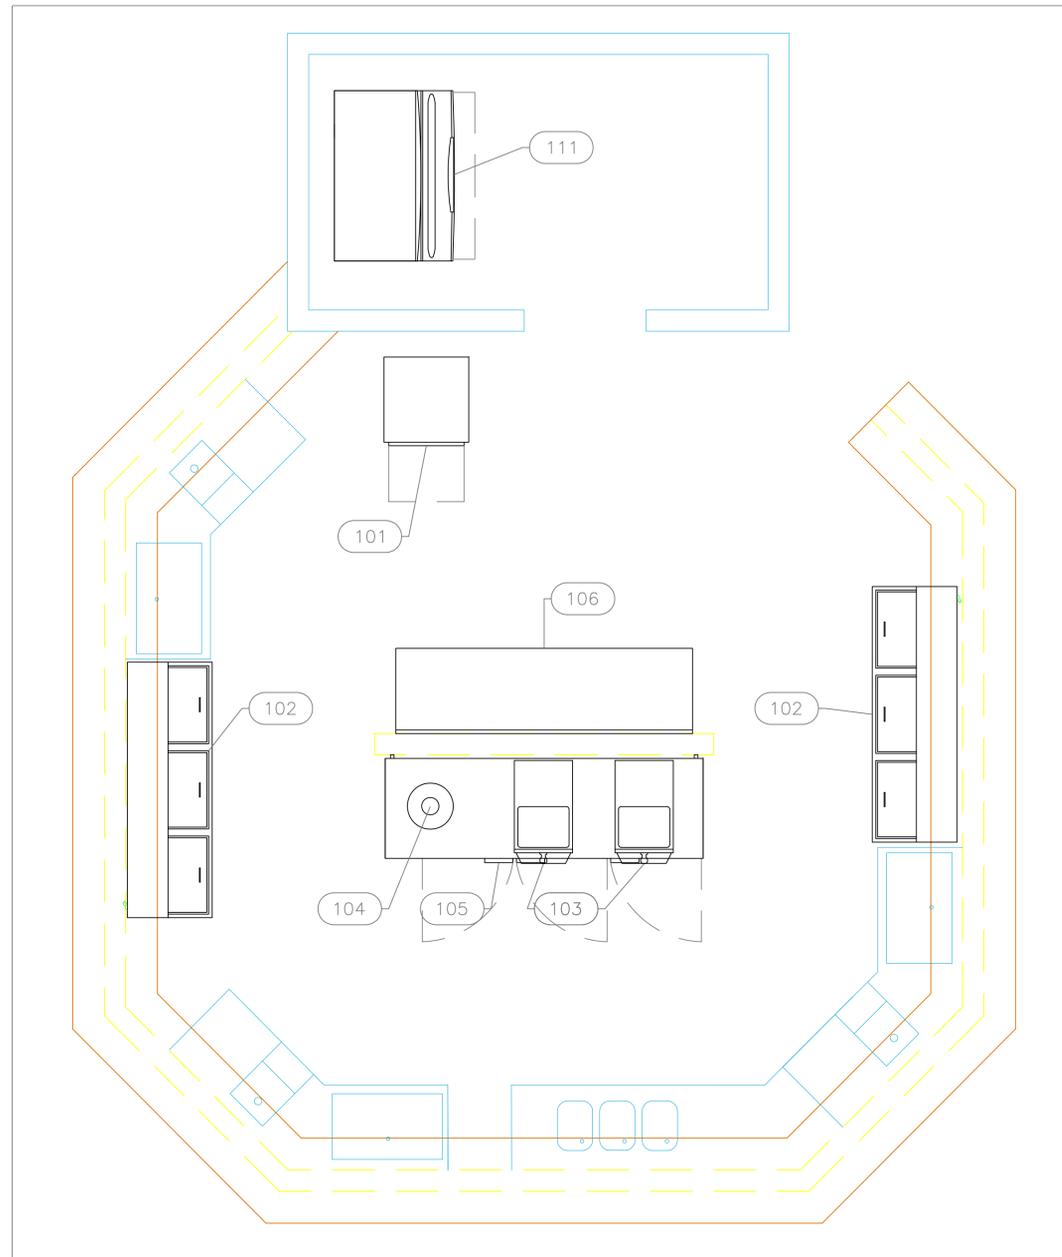

Bell Bar

EQUIPMENT SCHEDULE					
ItemNo	Category	Mfr	Model	Quantity	Equipment Remarks
101	Dishwasher, Undercounter	Champion	UH130B	1	Existing
102	Bottle Cooler	Glastender	ST72-S	2	Existing
103	Frozen Beverage Machine	Frosty Factory	137A	2	
104	Ice Shaver	Hamilton Beach	HBS1400	1	Existing
105	Backbar Cooler, front breathing	Continental Refrigerator	BB90NSS	1	
106	Work Table, Cabinet Base Hinged Doors	Advance Tabco	HK-SS-247	1	
111	Ice Maker, Cube-Style	Manitowoc	IYT1900A	1	Existing
	Ice Bin for Ice Machines	Manitowoc	D970	1	Existing

EQUIPMENT LAYOUT

All Dimensions to be verified on the job site.
 Actual locations for floor drains, and any ventilating equipment to be determined by Engineer.
 Mechanical, Plumbing & Electrical to be checked and verified by Customers MEP Engineer.
 Remote Condensing Units to be located by Architect.
 Exhaust & Supply fans to be located by Architect.

Carnival Cruise Lines
 Half Moon Cay
 Eleuthera, Bahamas




INTERNATIONAL INC.

2055 W 73rd Street, Miami, FL 33016
 Ph: (305)826-8696 Fax: (305)826-9131

1	Preliminary Layout	11-20-23
2	Added Main Kitchen	1-26-24
3	Major Update after site visit.	9-12-24
4	Added Elec & Plumbing Information.	9-20-24
No.	Revision/Issue	Date

Date

Sept 20, 2024

Drawn By


Dayne Gauntlett

Scale

1/2" = 1'

Sheet

FS-1.3

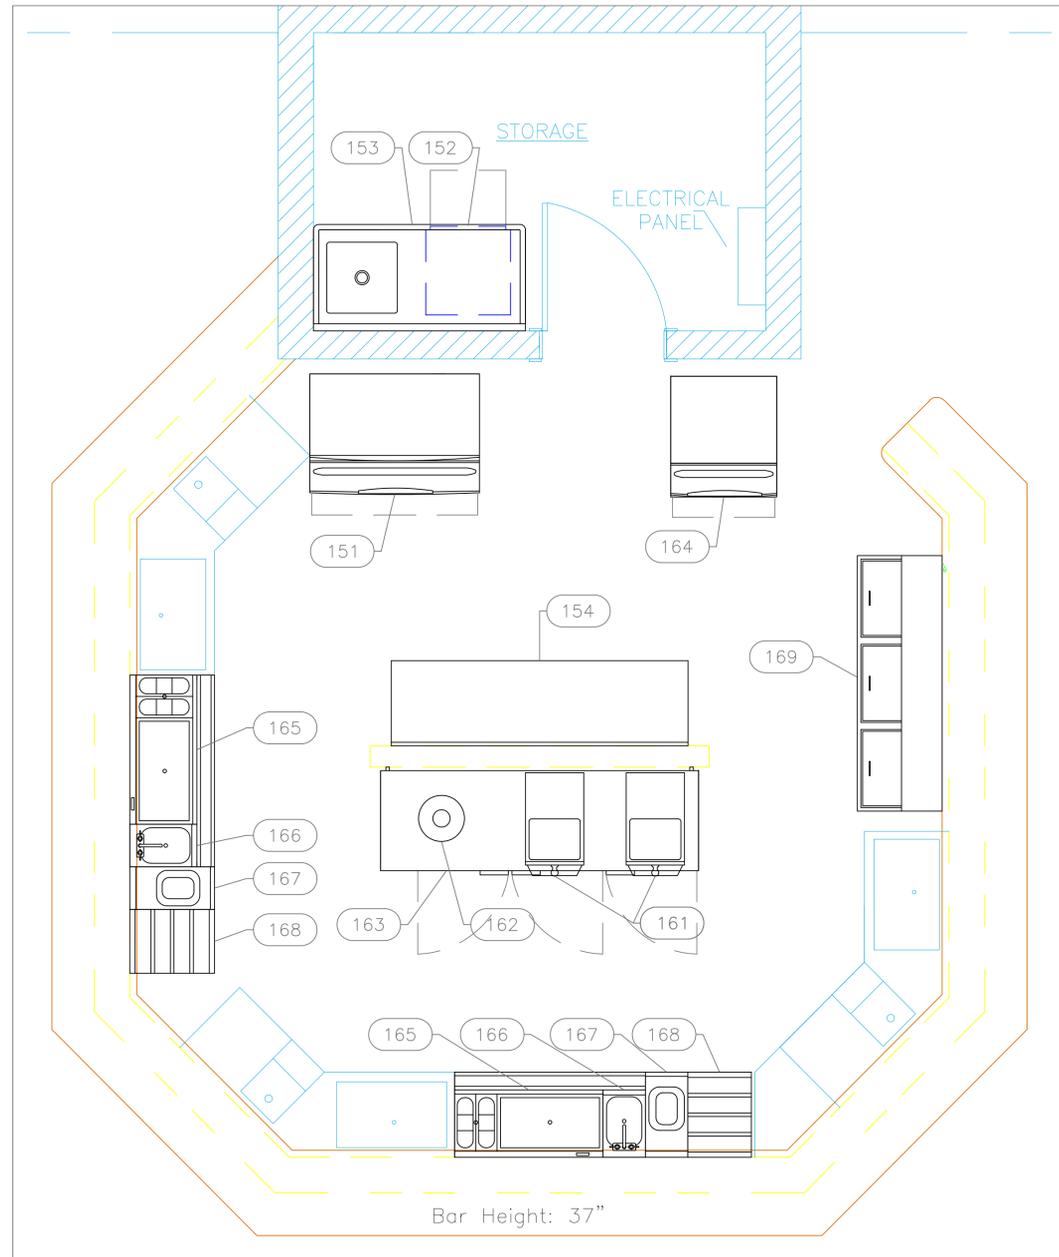

Rumrunners Bar

EQUIPMENT SCHEDULE					
ItemNo	Category	Mfr	Model	Quantity	Equipment Remarks
151	Ice Maker, Cube-Style	Manitowoc	IYT1900A	1	Existing
	Ice Bin for Ice Machines	Manitowoc	D970	1	Existing
152	Dishwasher, Undercounter	Champion	UH130B	1	Existing
153	Soiled Dishtable	Advance Tabco	DTU-U60-60R	1	
154	Work Table, Cabinet Base Hinged Doors	Advance Tabco	HK-SS-247	1	
161	Frozen Beverage Machine	Frosty Factory	137A	2	
162	Ice Shaver	Hamilton Beach	HBS1400	1	Existing
163	Backbar Cooler, front breathing	Continental Refrigerator	BB90NSS	1	
164	Ice Maker, Cube-Style	Manitowoc	IDT1200A	1	
		Manitowoc	D570	1	
165	Ice Bin with Bottle Wells	Krowne	KR19-M42R	2	
166	Hand Sink	Krowne	KR19-1C	2	
167	Underbar Add-On Unit	Krowne	KR24-T12	2	
168	Bottle Storage Unit	Krowne	KR24-18RD	2	
169	Bottle Cooler	Glastender	ST72-S	1	Existing

EQUIPMENT LAYOUT

All Dimensions to be verified on the job site.
 Actual locations for floor drains, and any ventilating equipment to be determined by Engineer.
 Mechanical, Plumbing & Electrical to be checked and verified by Customers MEP Engineer.
 Remote Condensing Units to be located by Architect.
 Exhaust & Supply fans to be located by Architect.

Carnival Cruise Lines
 Half Moon Cay
 Eleuthera, Bahamas



INTERNATIONAL INC.

2055 W 73rd Street, Miami, FL 33016
 Ph: (305)826-8696 Fax: (305)826-9131

No.	Revision/Issue	Date
1	Preliminary Layout	11-20-23
2	Added Main Kitchen	1-26-24
3	Major Update after site visit.	9-12-24
4	Added Elec & Plumbing Information.	9-20-24

Date

Sept 20, 2024

Drawn By


Dayne Gauntlett

Scale

1/2" = 1'


Sheet

FS-1.4

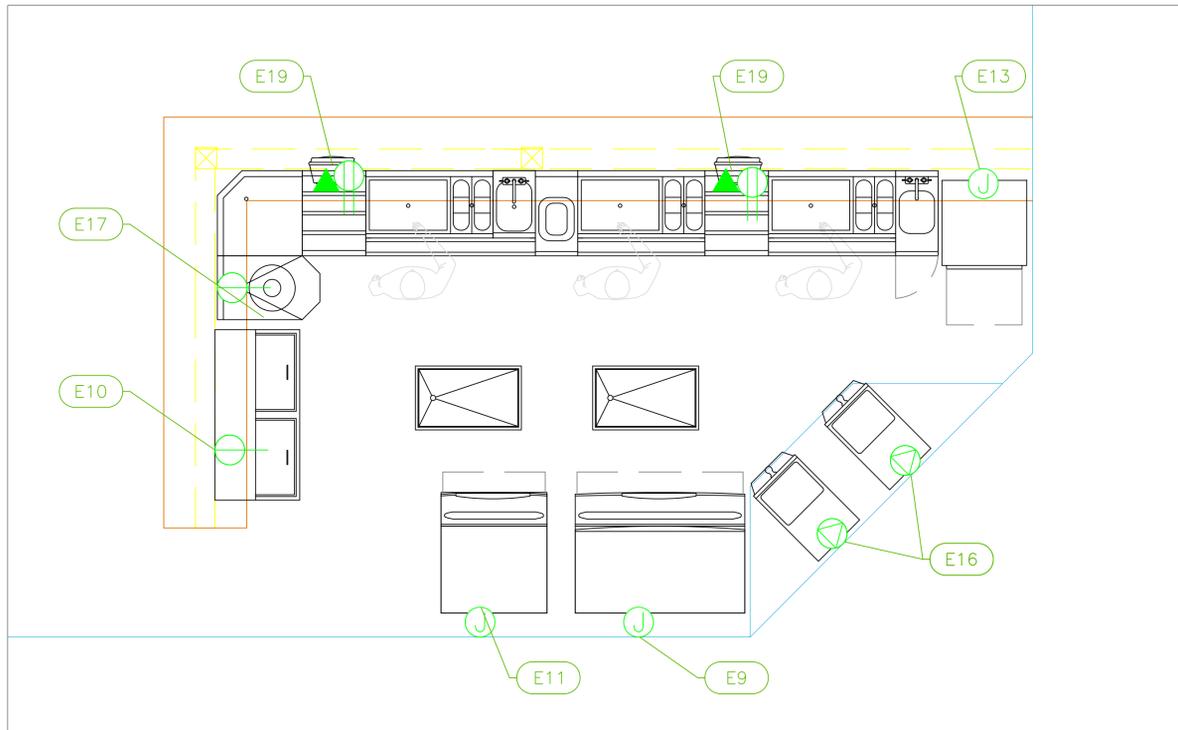

I wish I could stay here forever


ItemNo	Category	Voltage	Cycle	Phase	Amps	Hp	NEMA	ConnectionType	Rough-In AFF	Quantity	Electrical Remarks
9	Ice Maker, Cube-Style	208-230	60	1	20.1			J-Box	36"	1	
10	Bottle Cooler	120	60	1	4.5	1/6		Simplex	18"	1	
11	Ice Maker, Cube-Style	208-230	60	1	14.2			J-Box	36"	1	
13	Dishwasher, Undercounter	208-240	60	3	22	1		J-Box	18"	1	
16	Frozen Beverage Machine	115	60	1	16	3/4		Special	18"	2	
17	Ice Shaver	120	60	1	15	3		Simplex	18"	1	
19	POS System							DATA	40"	2	Mounted Horizontally just under bar top
		120	60	1	15			Duplex	40"	2	Mounted Horizontally just under bar top
28	Dishwasher, Undercounter	208-240	60	3	22	1		J-Box	18"	1	
30	Ice Shaver	120	60	1	15	3		Simplex	18"	2	
32	Refrigerated Work Top	115	60	1	4.8		5-15P	Simplex	18"	1	
34	WorkTop Freezer	115	60	1	6.1		5-15P	Simplex	18"	1	
35	POS System							DATA	40"	2	Mounted Horizontally just under bar top
		120	60	1	15			Duplex	40"	2	Mounted Horizontally just under bar top

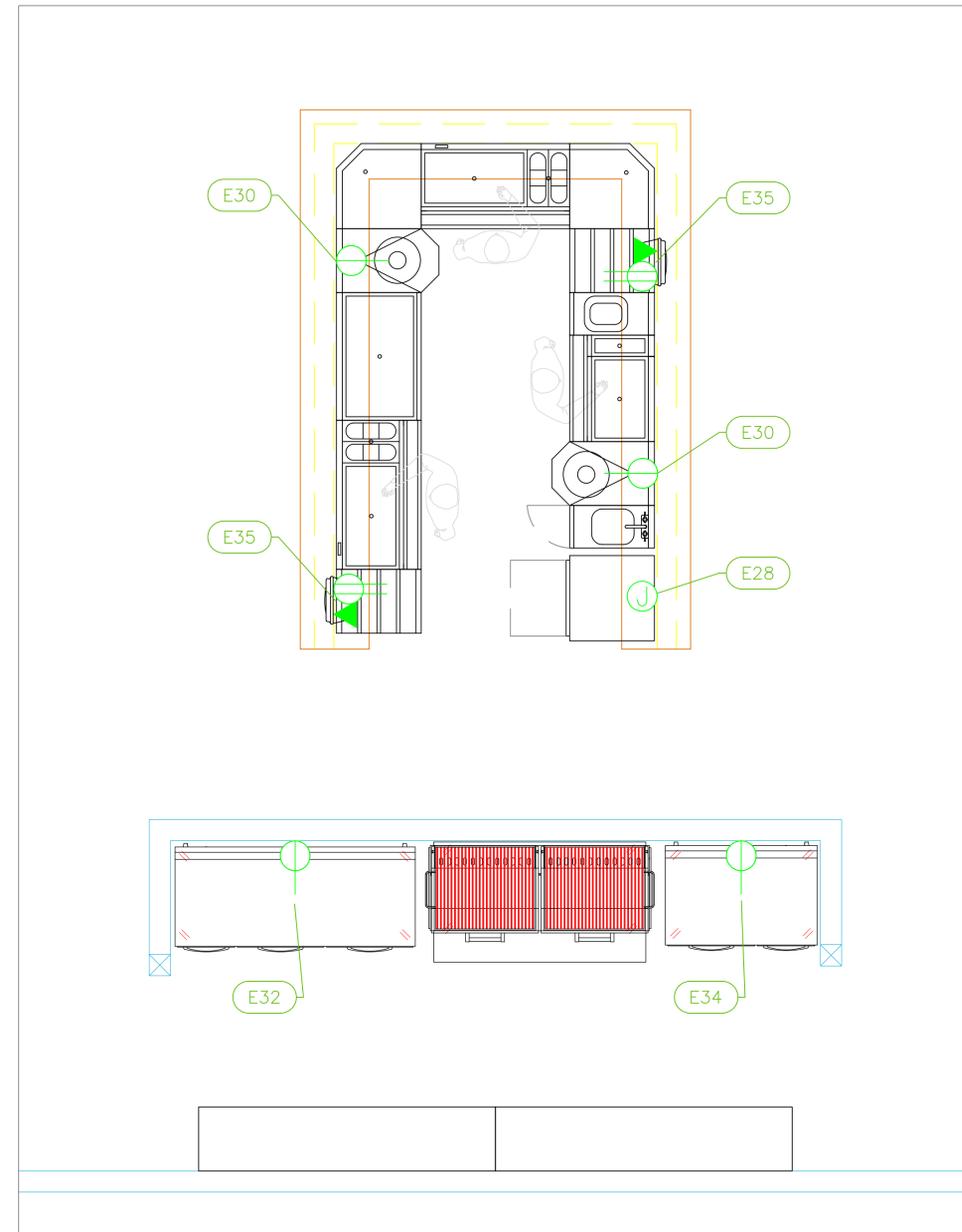

Lobster Shack

LEGEND -- ELECTRICAL CONNECTIONS

- DUPLEX RECEPT., 15-AMP, 120-VOLT, GROUND TYPE, HORIZONTAL MOUNT
- SIMPLEX RECEPT., 120-VOLT, GROUND TYPE, HORIZONTAL MOUNT
- SPECIAL PURPOSE OUTLET, GROUND TYPE, HORIZONTAL MOUNT
- JUNCTION BOX, DIRECT CONNECTION
- DISCONNECT SWITCH, DIRECT CONNECTION
- FLOOR/CEILING RECEPTACLE AS INDICATED
- (2) Telephone + (2) Data
- FIELD CONNECTIONS
- HARD WIRE CONNECTION POINT AT MACHINE

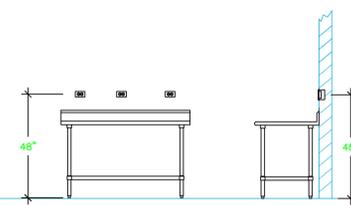

NOTE # E1
TYPICAL OUTLETS IN WALL ABOVE TABLE, BY ELECTRICIAN NOT TO SCALE

NOTE # E2
ALL NATIONAL, STATE, AND LOCAL CODES SHALL APPLY.

NOTE # E3
ALL ELECTRICAL CONNECTIONS AND HARDWARE REQUIRED TO BE PROVIDED BY ELECTRICAL CONTRACTOR

NOTE # E4
ALL JUNCTION BOXES, OUTLETS, ETC. TO BE LOCATED SO AS TO NOT INTERFERE WITH EQUIPMENT

NOTE # E5
ALL RELAYS, CONTRACTORS, STARTERS, AND SWITCHES REQUIRED FOR EXHAUST & SUPPLY FANS TO BE PROVIDED BY ELECTRICAL CONTRACTOR UNLESS SPECIFIED

NOTE # E6
ELECTRICAL CONTRACTOR TO INTERCONNECT DISHMACHINE TO EXHAUST FAN FOR DISHMACHINE SO THAT THE FAN RUNS WHEN THE DISHMACHINE IS IN OPERATION.

NOTE # E7
ELECTRICAL CONTRACTOR TO INSTALL TABLE LIMIT SWITCH TO END OF CLEAN DISHTABLE TO THAT MACHINE STOPS WHEN SWITCH IS DEPRESSED.

NOTE # E8
ELECTRICAL CONTRACTOR TO CONNECT DRAIN LINE HEATER, PAN HEATER AND DDDR HEATER FOR WALK-IN FREEZER.

Equipment ELECTRICAL Service Requirements

All Dimensions to be verified on the job site. Actual locations for floor drains, and any ventilating equipment to be determined by Engineer. Mechanical, Plumbing & Electrical to be checked and verified by Customers MEP Engineer. Remote Condensing Units to be located by Architect. Exhaust & Supply fans to be located by Architect.

Carnival Cruise Lines
Half Moon Cay
Eleuthera, Bahamas


INTERNATIONAL INC.

2055 W 73rd Street, Miami, FL 33016
Ph:(305)826-8696 Fax:(305)826-9131


1	Preliminary Layout	11-20-23
2	Added Main Kitchen	1-26-24
3	Major Update after site visit.	9-12-24
4	Added Elec & Plumbing Information.	9-20-24
No.	Revision/Issue	Date

Date
Sept 20, 2024
Drawn By
Dayne Gauntlett
Scale
1/2" = 1'0"

Sheet
FS-3.1

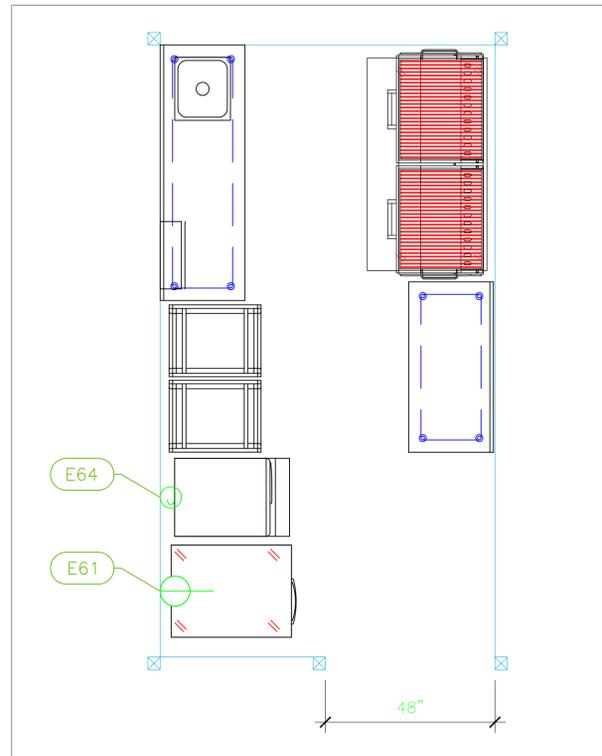

**Private Beach
Cabana Kitchen**

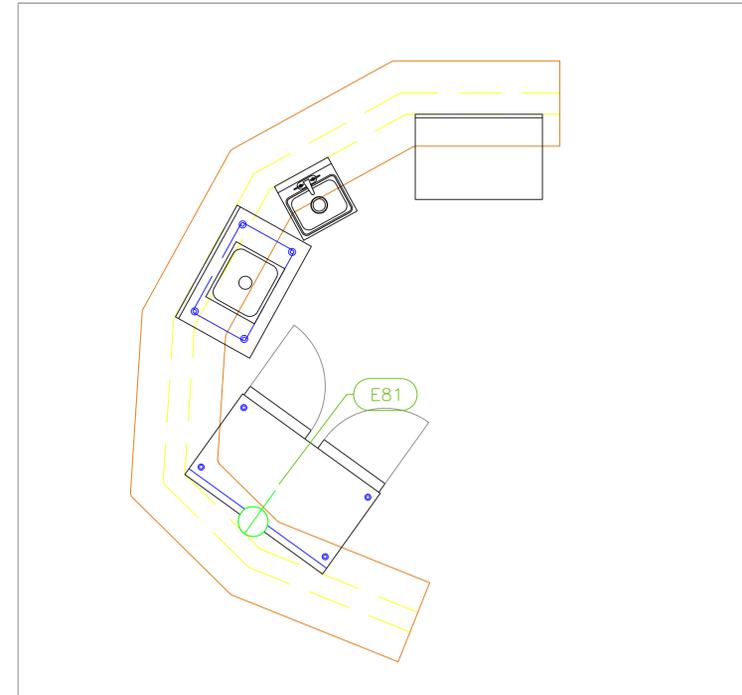


**Private Beach
Cabana Bar**

ELECTRICAL SCHEDULE											
ItemNo	Category	Voltage	Cycle	Phase	Amps	Hp	NEMA	ConnectionType	Rough-In AFF	Quantity	Electrical Remarks
61	Reach-In Refrigerator	115	60	1	5.2	1/4	5-15P	Simplex	18"	1	
64	Ice Maker, Cube-Style	115	60	1	15.2			J-Box	36"	1	
81	Undercounter Refrigerator	115	60	1	7.5	1/4	5-15P	Simplex	18"	1	

LEGEND -- ELECTRICAL CONNECTIONS

- DUPLEX RECEPT., 15-AMP, 120-VOLT, GROUND TYPE, HORIZONTAL MOUNT
- SIMPLEX RECEPT., 120-VOLT, GROUND TYPE, HORIZONTAL MOUNT
- SPECIAL PURPOSE OUTLET, GROUND TYPE, HORIZONTAL MOUNT
- JUNCTION BOX, DIRECT CONNECTION
- DISCONNECT SWITCH, DIRECT CONNECTION
- FLOOR/CEILING RECEPTACLE AS INDICATED
- (2) Telephone + (2) Data
- FIELD CONNECTIONS
- HARD WIRE CONNECTION POINT AT MACHINE

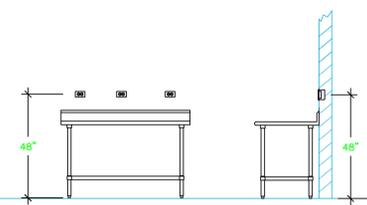

NOTE # E1
TYPICAL OUTLETS IN WALL ABOVE TABLE, BY ELECTRICIAN NOT TO SCALE

NOTE # E2
ALL NATIONAL, STATE, AND LOCAL CODES SHALL APPLY

NOTE # E3
ALL ELECTRICAL CONNECTIONS AND HARDWARE REQUIRED TO BE PROVIDED BY ELECTRICAL CONTRACTOR

NOTE # E4
ALL JUNCTION BOXES, OUTLETS, ETC. TO BE LOCATED SO AS TO NOT INTERFERE WITH EQUIPMENT

NOTE # E5
ALL RELAYS, CONTRACTORS, STARTERS, AND SWITCHES REQUIRED FOR EXHAUST & SUPPLY FANS TO BE PROVIDED BY ELECTRICAL CONTRACTOR UNLESS SPECIFIED

NOTE # E6
ELECTRICAL CONTRACTOR TO INTERCONNECT DISHMACHINE TO EXHAUST FAN FOR DISHMACHINE SO THAT THE FAN RUNS WHEN THE DISHMACHINE IS IN OPERATION.

NOTE # E7
ELECTRICAL CONTRACTOR TO INSTALL TABLE LIMIT SWITCH TO END OF CLEAN DISHTABLE TO THAT MACHINE STOPS WHEN SWITCH IS DEPRESSED.

NOTE # E8
ELECTRICAL CONTRACTOR TO CONNECT DRAIN LINE HEATER, PAN HEATER AND DDDR HEATER FOR WALK-IN FREEZER.

**Equipment
ELECTRICAL
Service Requirements**

All Dimensions to be verified on the job site. Actual locations for floor drains, and any ventilating equipment to be determined by Engineer. Mechanical, Plumbing & Electrical to be checked and verified by Customers MEP Engineer. Remote Condensing Units to be located by Architect. Exhaust & Supply fans to be located by Architect.

**Carnival Cruise Lines
Half Moon Cay
Eleuthera, Bahamas**

INTERNATIONAL INC.
2055 W 73rd Street, Miami, FL 33016
Ph:(305)826-8696 Fax:(305)826-9131


No.	Revision/Issue	Date
1	Preliminary Layout	11-20-23
2	Added Main Kitchen	1-26-24
3	Major Update after site visit.	9-12-24
4	Added Elec & Plumbing Information.	9-20-24

Date
Sept 20, 2024

Drawn By
Dayne Gauntlett

Scale
1/2" = 1'0"

Sheet
FS-3.2

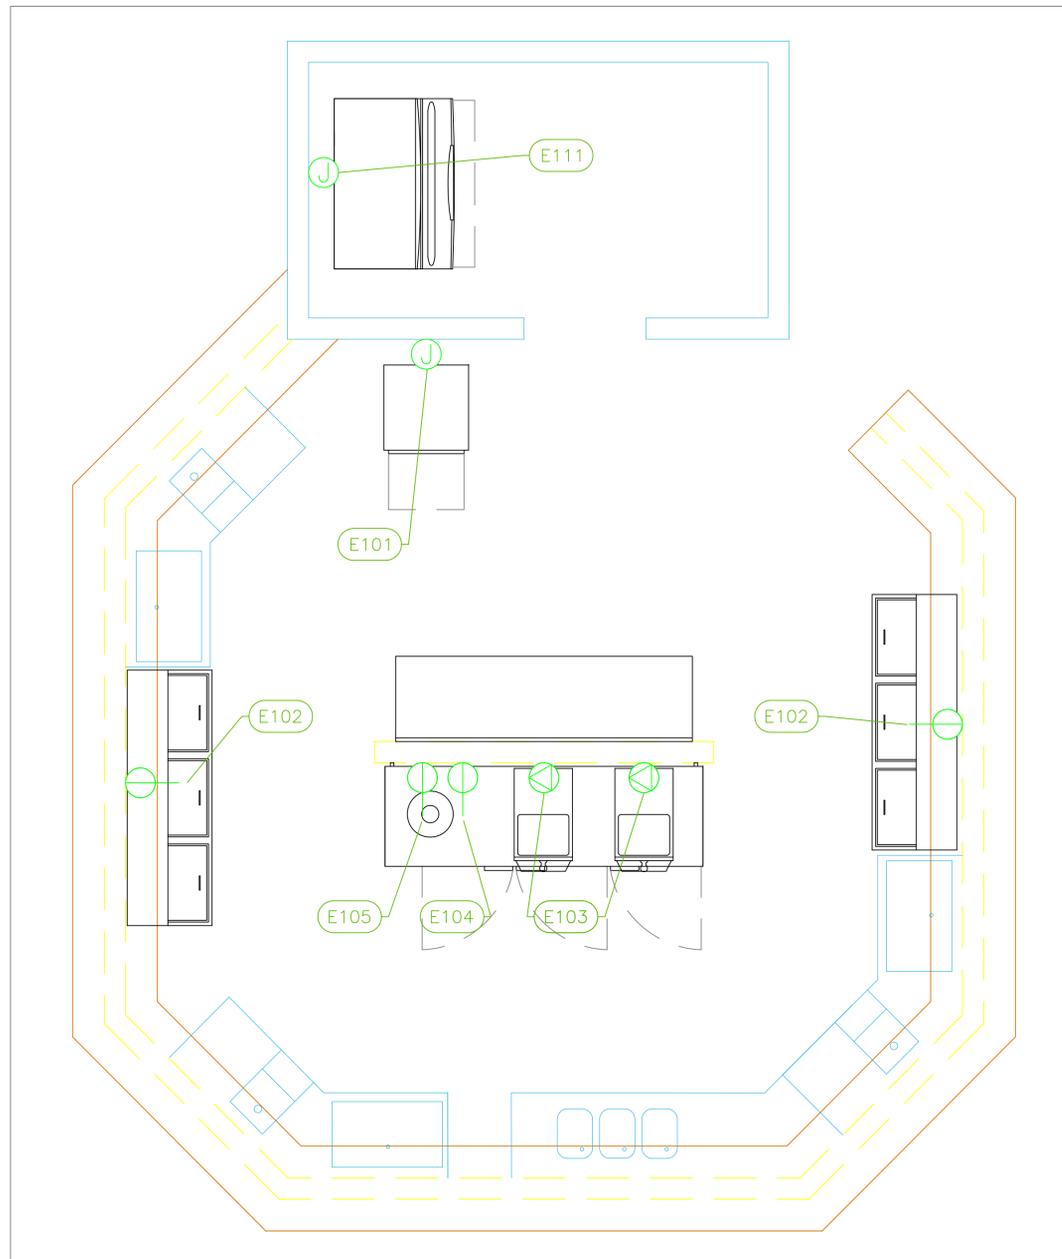


Bell Bar

ELECTRICAL SCHEDULE

ItemNo	Category	Voltage	Cycle	Phase	Amps	Hp	NEMA	ConnectionType	Rough-In AFF	Quantity	Electrical Remarks
101	Dishwasher, Undercounter	208-240	60	3	22	1		J-Box	18"	1	
102	Bottle Cooler	115	60	1	4.5	1/6		Simplex	18"	2	
103	Frozen Beverage Machine	115	60	1	16	3/4		Special	18"	2	
104	Ice Shaver	120	60	1	15	3		Simplex	18"	1	
105	Backbar Cooler, front breathing	115	60	1	5.8	1/4	5-15P	Simplex	18"	1	
111	Ice Maker, Cube-Style	208-230	60	1	20.1			J-Box	36"	1	

LEGEND -- ELECTRICAL CONNECTIONS

- DUPLEX RECEPT., 15-AMP, 120-VOLT, GROUND TYPE, HORIZONTAL MOUNT
- SIMPLEX RECEPT., 120-VOLT, GROUND TYPE, HORIZONTAL MOUNT
- SPECIAL PURPOSE OUTLET, GROUND TYPE, HORIZONTAL MOUNT
- JUNCTION BOX, DIRECT CONNECTION
- DISCONNECT SWITCH, DIRECT CONNECTION
- FLOOR/CEILING RECEPTACLE AS INDICATED
- (2) Telephone + (2) Data
- FIELD CONNECTIONS
- HARD WIRE CONNECTION POINT AT MACHINE

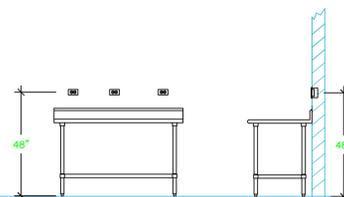

NOTE # E1
TYPICAL OUTLETS IN WALL ABOVE TABLE, BY ELECTRICIAN NOT TO SCALE

NOTE # E2
ALL NATIONAL, STATE, AND LOCAL CODES SHALL APPLY

NOTE # E3
ALL ELECTRICAL CONNECTIONS AND HARDWARE REQUIRED TO BE PROVIDED BY ELECTRICAL CONTRACTOR

NOTE # E4
ALL JUNCTION BOXES, OUTLETS, ETC. TO BE LOCATED SO AS TO NOT INTERFERE WITH EQUIPMENT

NOTE # E5
ALL RELAYS, CONTRACTORS, STARTERS, AND SWITCHES REQUIRED FOR EXHAUST & SUPPLY FANS TO BE PROVIDED BY ELECTRICAL CONTRACTOR UNLESS SPECIFIED

NOTE # E6
ELECTRICAL CONTRACTOR TO INTERCONNECT DISHMACHINE TO EXHAUST FAN FOR DISHMACHINE SO THAT THE FAN RUNS WHEN THE DISHMACHINE IS IN OPERATION.

NOTE # E7
ELECTRICAL CONTRACTOR TO INSTALL TABLE LIMIT SWITCH TO END OF CLEAN DISHTABLE TO THAT MACHINE STOPS WHEN SWITCH IS DEPRESSED.

NOTE # E8
ELECTRICAL CONTRACTOR TO CONNECT DRAIN LINE HEATER, PAN HEATER AND DDBR HEATER FOR WALK-IN FREEZER.

Equipment ELECTRICAL Service Requirements

All Dimensions to be verified on the job site. Actual locations for floor drains, and any ventilating equipment to be determined by Engineer. Mechanical, Plumbing & Electrical to be checked and verified by Customers MEP Engineer. Remote Condensing Units to be located by Architect. Exhaust & Supply fans to be located by Architect.

Carnival Cruise Lines
Half Moon Cay
Eleuthera, Bahamas

uni-source
SUPPLY

INTERNATIONAL INC.

2055 W 73rd Street, Miami, FL 33016
Ph: (305) 826-8696 Fax: (305) 826-9131

1	Preliminary Layout	11-20-23
2	Added Main Kitchen	1-26-24
3	Major Update after site visit.	9-12-24
4	Added Elec & Plumbing Information.	9-20-24
No.	Revision/Issue	Date

Date

Sept 20, 2024

Drawn By


Dayne Gauntlett

Scale

1/2" = 1'0"

Sheet

FS-3.3

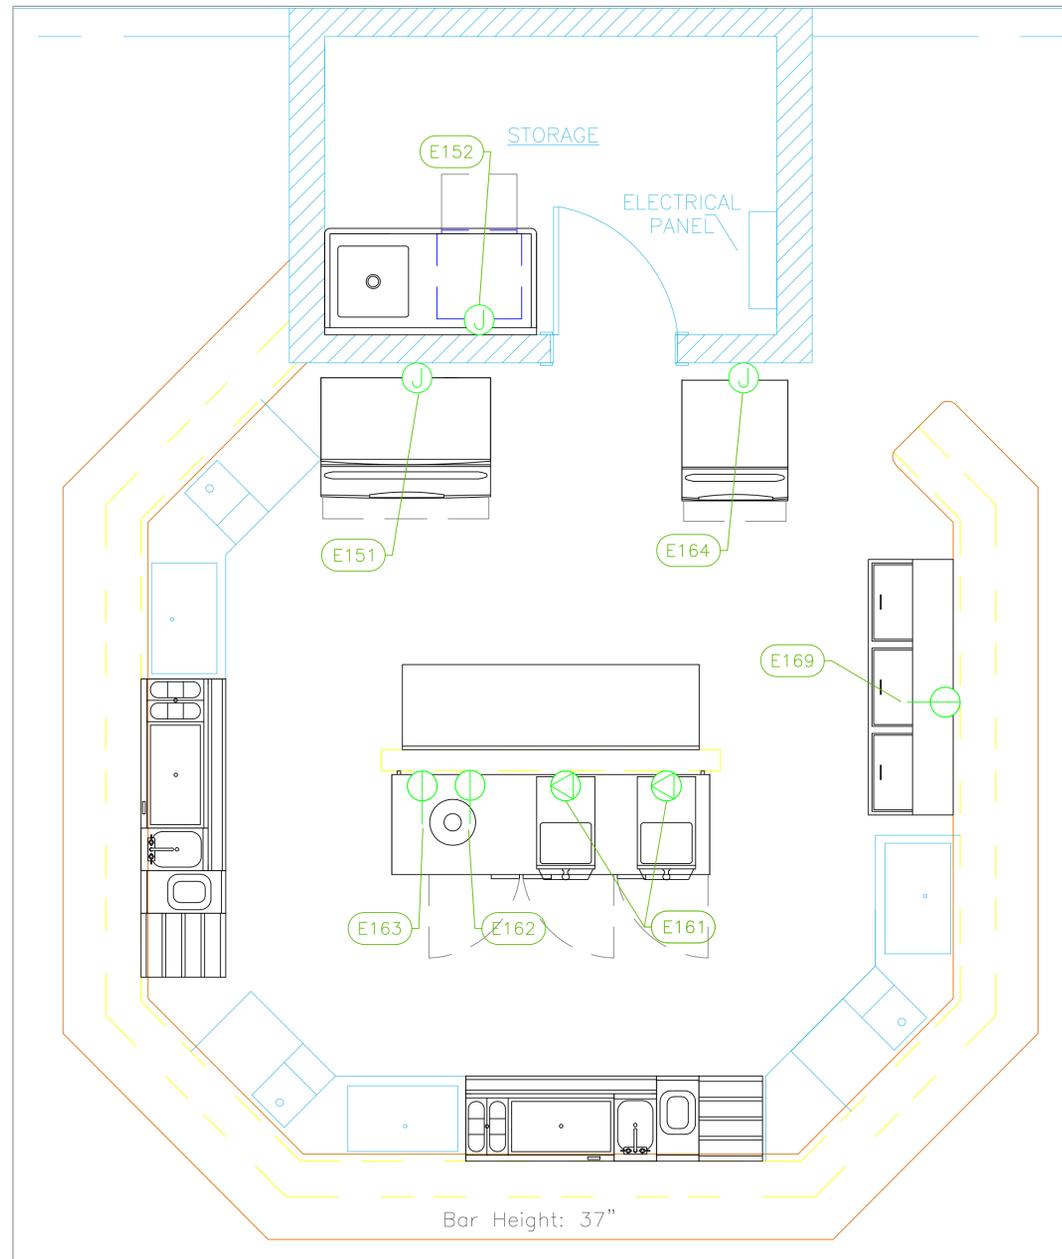


Rumrunners Bar

ELECTRICAL SCHEDULE											
ItemNo	Category	Voltage	Cycle	Phase	Amps	Hp	NEMA	ConnectionType	Rough-In AFF	Quantity	Electrical Remarks
151	Ice Maker, Cube-Style	208-230	60	1	20.1			J-Box	36"	1	
152	Dishwasher, Undercounter	208	60	3	22			J-Box	18"	1	
161	Frozen Beverage Machine	115	60	1	16	3/4		Special	18"	2	
162	Ice Shaver	120	60	1	15	3		Simplex	18"	1	
163	Backbar Cooler, front breathing	115	60	1	5.8	1/4	5-15P	Simplex	18"	1	
164	Ice Maker, Cube-Style	208-230	60	1	14.2			J-Box	18"	1	
169	Bottle Cooler	115	60	1	4.5	1/6		Simplex	18"	1	

LEGEND -- ELECTRICAL CONNECTIONS

- DUPLEX RECEPT., 15-AMP, 120-VOLT, GROUND TYPE, HORIZONTAL MOUNT
- SIMPLEX RECEPT., 120-VOLT, GROUND TYPE, HORIZONTAL MOUNT
- SPECIAL PURPOSE OUTLET, GROUND TYPE, HORIZONTAL MOUNT
- JUNCTION BOX, DIRECT CONNECTION
- DISCONNECT SWITCH, DIRECT CONNECTION
- FLOOR/CEILING RECEPTACLE AS INDICATED
- (2) Telephone + (2) Data
- FIELD CONNECTIONS
- HARD WIRE CONNECTION POINT AT MACHINE

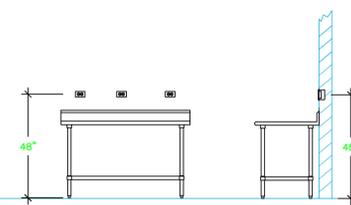

NOTE # E1
TYPICAL OUTLETS IN WALL ABOVE TABLE, BY ELECTRICIAN NOT TO SCALE

NOTE # E2
ALL NATIONAL, STATE, AND LOCAL CODES SHALL APPLY

NOTE # E3
ALL ELECTRICAL CONNECTIONS AND HARDWARE REQUIRED TO BE PROVIDED BY ELECTRICAL CONTRACTOR

NOTE # E4
ALL JUNCTION BOXES, OUTLETS, ETC. TO BE LOCATED SO AS TO NOT INTERFERE WITH EQUIPMENT

NOTE # E5
ALL RELAYS, CONTRACTORS, STARTERS, AND SWITCHES REQUIRED FOR EXHAUST & SUPPLY FANS TO BE PROVIDED BY ELECTRICAL CONTRACTOR UNLESS SPECIFIED

NOTE # E6
ELECTRICAL CONTRACTOR TO INTERCONNECT DISHMACHINE TO EXHAUST FAN FOR DISHMACHINE SO THAT THE FAN RUNS WHEN THE DISHMACHINE IS IN OPERATION.

NOTE # E7
ELECTRICAL CONTRACTOR TO INSTALL TABLE LIMIT SWITCH TO END OF CLEAN DISHTABLE TO THAT MACHINE STOPS WHEN SWITCH IS DEPRESSED.

NOTE # E8
ELECTRICAL CONTRACTOR TO CONNECT DRAIN LINE HEATER, PAN HEATER AND DOOR HEATER FOR WALK-IN FREEZER.

Equipment ELECTRICAL Service Requirements

All Dimensions to be verified on the job site. Actual locations for floor drains, and any ventilating equipment to be determined by Engineer. Mechanical, Plumbing & Electrical to be checked and verified by Customers MEP Engineer. Remote Condensing Units to be located by Architect. Exhaust & Supply fans to be located by Architect.

Carnival Cruise Lines
Half Moon Cay
Eleuthera, Bahamas

uni-source
SUPPLY


INTERNATIONAL INC.

2055 W 73rd Street, Miami, FL 33016
Ph: (305)826-8696 Fax: (305)826-9131


No.	Revision/Issue	Date
1	Preliminary Layout	11-20-23
2	Added Main Kitchen	1-26-24
3	Major Update after site visit.	9-12-24
4	Added Elec & Plumbing Information.	9-20-24

Date
Sept 20, 2024
Drawn By
Dayne Gauntlett
Scale
1/2" = 1'0"

Sheet
FS-3.4



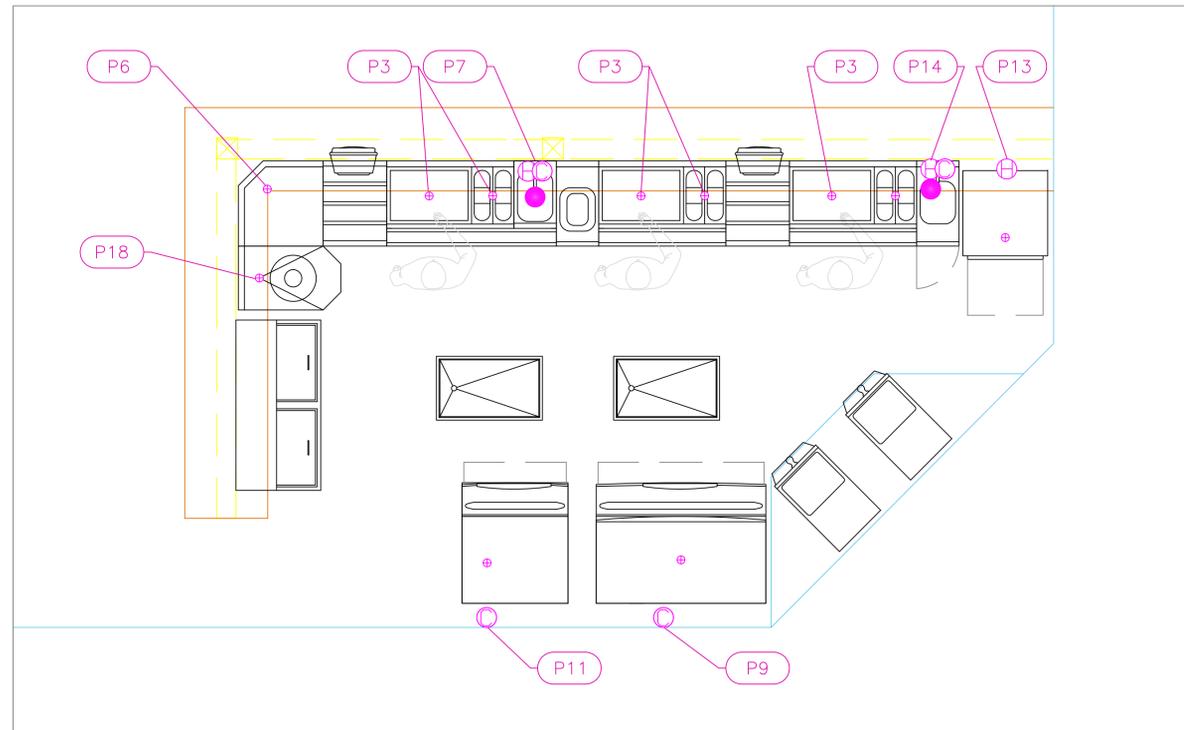


I wish I could stay here forever

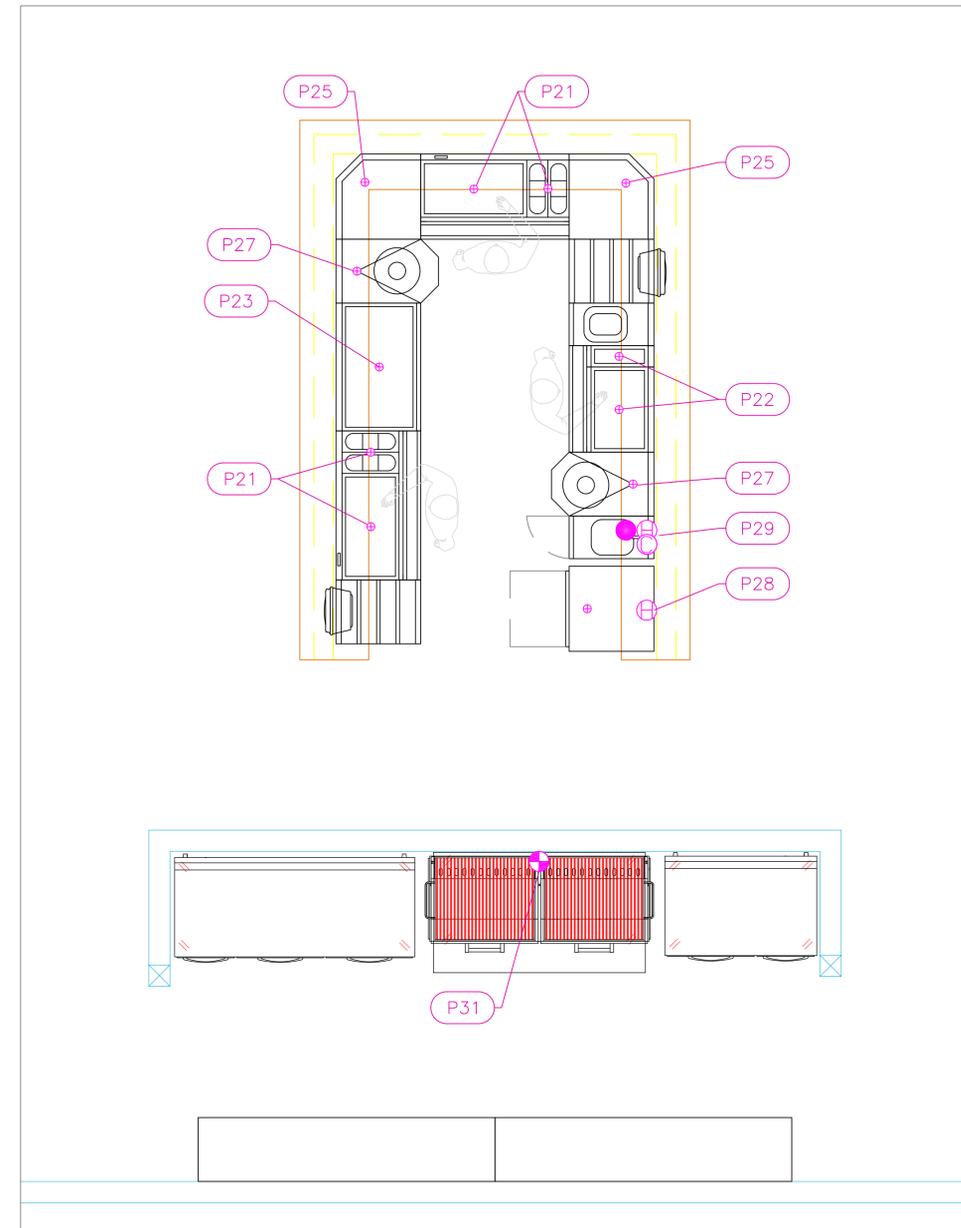

Lobster Shack

PLUMBING SCHEDULE											
ITEM NO.	DESCRIPTION	COLD WATER SIZE	HOT WATER SIZE	H&C Rough-In	DIRECT WASTE SIZE	DIRECT WASTE AFF	INDIRECT WASTE SIZE	GAS SIZE(IN)	GAS MBTU	QTY	PLUMBING REMARKS
3	Ice Bin with Bottle Wells						1"			3	Ice bin drain
							1"			3	Bottle storage drain
6	Corner Angle Filler						1"			1	
7	Hand Sink	1/2"	1/2"	12"	1-1/2"	24"	1/2"			1	Faucet, Sink drain
9	Ice Maker, Cube-Style	3/8"		12"			3/4"			1	Drain for ice maker
	Ice Bin for Ice Machines						3/4"			1	
11	Ice Maker, Cube-Style	3/8"		12"			1/2"			1	Drain for ice maker
	Ice Bin for Ice Machines						3/4"			1	
13	Dishwasher, Undercounter		1/2"	12"			5/8"			1	1/2" supply; Machine equipped with 3/4" hose connector
14	Hand Sink	1/2"	1/2"	12"	1"	24"	1"			1	Faucet, Drainboard drain
21	Ice Bin with Bottle Wells						1"			2	Ice bin drain
22	Ice Bin with Bottle Wells						1"			1	Ice bin drain
							1"			1	Bottle storage drain
23	Iced Beer Display						1"			1	
25	Corner Angle Filler						1"			2	
28	Dishwasher, Undercounter		1/2"	12"			5/8"			1	1/2" supply; Machine equipped with 3/4" hose connector
29	Hand Sink	1/2"	1/2"	12"	1"	24"	1"			1	Faucet, Drainboard drain

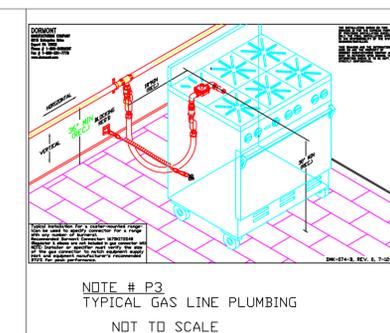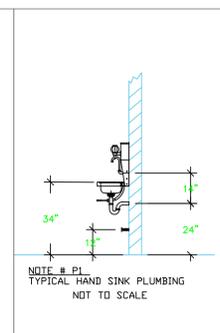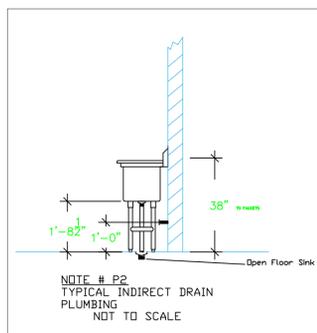

LEGEND -- PLUMBING CONNECTIONS

- HW--HOT WATER, OR CW--COLD WATER
- GAS
- WASTE, DIRECT--CONNECTED
- WASTE, INDIRECT to Floor Sink, or Floor Drain
- FUNNEL FLOOR DRAIN Josam 30000-E3
- FLOOR DRAIN Josam 30000-A3
- FLOOR SINK Proflo PF42856 or similar
- FILTERED WATER, at machine.

NOTE # P4
ALL NATIONAL, STATE, AND LOCAL CODES SHALL APPLY

NOTE # P5
ALL PLUMBING CONNECTIONS TO BE EXTENDED AND INTERCONNECTED TO EQUIPMENT AND ALL HARDWARE REQUIRED TO BE PROVIDED BY PLUMBING CONTRACTOR

NOTE # P6
PLUMBING CONTRACTOR TO VERIFY THAT ALL EQUIPMENT IS INSTALLED WITH THE APPROPRIATE GAS PRESSURE AND REGULATORS

NOTE # P7
ALL WASTE LINES AND CONDENSATE LINES TO BE EXTEND FROM EQUIPMENT TO FLOOR DRAINS BY PLUMBING CONTRACTOR.

Equipment PLUMBING Service Requirements

All Dimensions to be verified on the job site. Actual locations for floor drains, and any ventilating equipment to be determined by Engineer. Mechanical, Plumbing & Electrical to be checked and verified by Customers MEP Engineer. Remote Condensing Units to be located by Architect. Exhaust & Supply fans to be located by Architect.

Carnival Cruise Lines
Half Moon Cay
Eleuthera, Bahamas
Carnival


uni-source
SUPPLY
INTERNATIONAL INC.

2055 W 73rd Street, Miami, FL 33016
Ph:(305)826-8696 Fax:(305)826-9131


1	Preliminary Layout	11-20-23
2	Added Main Kitchen	1-26-24
3	Major Update after site visit.	9-12-24
4	Added Elec & Plumbing Information.	9-20-24
No.	Revision/Issue	Date

Date
Sept 20, 2024
Drawn By
Dayne Gauntlett
Scale
1/2" = 1'0"

Sheet
FS-4.1

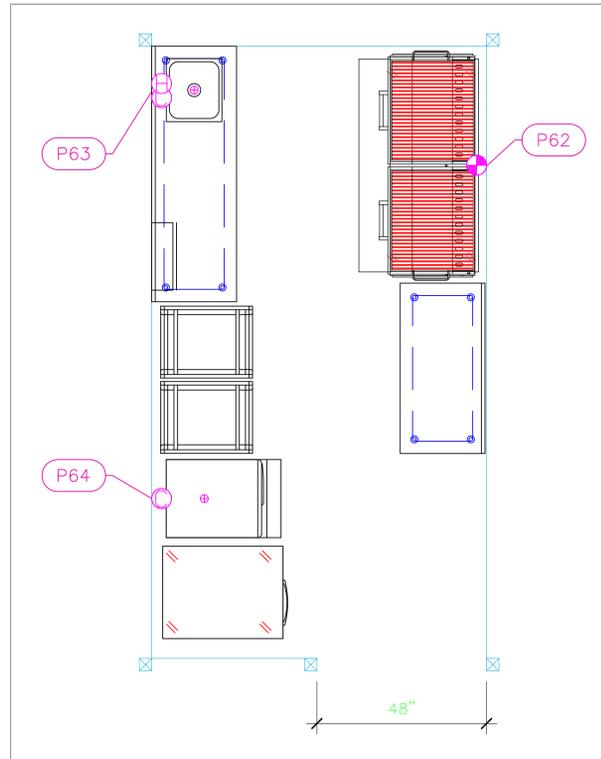

Private Beach Cabana Kitchen

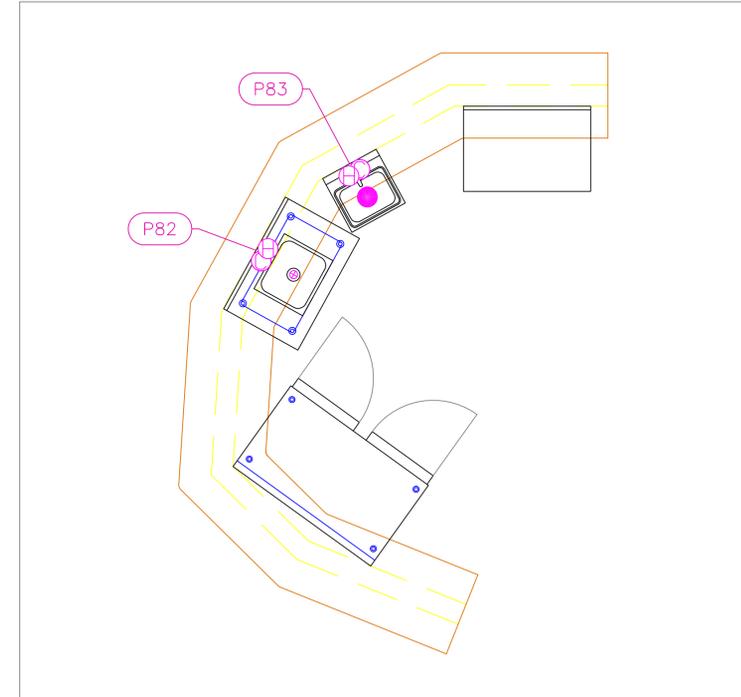

Private Beach Cabana Bar

PLUMBING SCHEDULE											
ITEM NO.	DESCRIPTION	COLD WATER SIZE	HOT WATER SIZE	H&C Rough-In	DIRECT WASTE SIZE	DIRECT WASTE AFF	INDIRECT WASTE SIZE	GAS SIZE (IN)	GAS MBTU	QTY	PLUMBING REMARKS
62	Charbroiler, Gas, Outdoor Grill							3/8	160.0	1	
63	Work Table, Stainless Steel Top									1	
	Weld-in Sink						1-1/2"			1	
	Deck Mount Faucet	1/2"	1/2"	12"						1	
64	Ice Maker, Cube-Style	1/2"		12"			3/4"			1	Ice Maker Drain
	Ice Bin for Ice Machines									1	
82	Work Table, Stainless Steel Top	1/2"	1/2"	12"						1	
	Weld-in Sink						1-1/2"			1	
83	Hand Sink	1/2"	1/2"	12"	1-1/2"	24"				1	(1) set of 1" faucet holes, 4" OC, deck mount

Carnival Cruise Lines
Half Moon Cay
Eleuthera, Bahamas
Carnival






INTERNATIONAL INC.
2055 W 73rd Street, Miami, FL 33016
Ph:(305)826-8696 Fax:(305)826-9131

1	Preliminary Layout	11-20-23
2	Added Main Kitchen	1-26-24
3	Major Update after site visit.	9-12-24
4	Added Elec & Plumbing Information.	9-20-24
No.	Revision/Issue	Date

Date
Sept 20, 2024
Drawn By
Dayne Gauntlett
Scale
1/2" = 1'0"

Sheet
FS-4.2

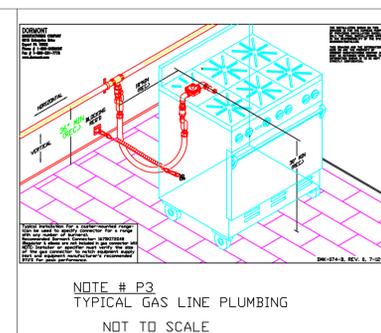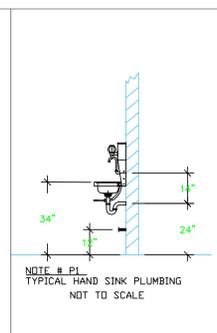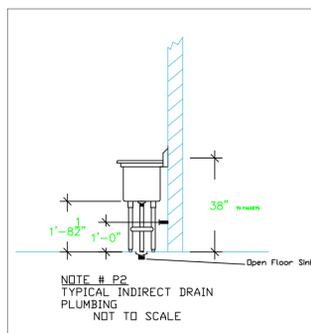

LEGEND -- PLUMBING CONNECTIONS

- HW--HOT WATER, OR CW--COLD WATER
- GAS
- WASTE, DIRECT--CONNECTED
- WASTE, INDIRECT to Floor Sink, or Floor Drain
- FUNNEL FLOOR DRAIN Josam 30000-E3
- FLOOR DRAIN Josam 30000-A3
- FLOOR SINK Proflo PF42856 or similar
- FILTERED WATER, at machine.

NOTE # P4. ALL NATIONAL, STATE, AND LOCAL CODES SHALL APPLY


NOTE # P5. ALL PLUMBING CONNECTIONS TO BE EXTENDED AND INTERCONNECTED TO EQUIPMENT AND ALL HARDWARE REQUIRED TO BE PROVIDED BY PLUMBING CONTRACTOR

NOTE # P6. PLUMBING CONTRACTOR TO VERIFY THAT ALL EQUIPMENT IS INSTALLED WITH THE APPROPRIATE GAS PRESSURE AND REGULATORS

NOTE # P7. ALL WASTE LINES AND CONDENSATE LINES TO BE EXTEND FROM EQUIPMENT TO FLOOR DRAINS BY PLUMBING CONTRACTOR.




Equipment PLUMBING Service Requirements

All Dimensions to be verified on the job site. Actual locations for floor drains, and any ventilating equipment to be determined by Engineer. Mechanical, Plumbing & Electrical to be checked and verified by Customers MEP Engineer. Remote Condensing Units to be located by Architect. Exhaust & Supply fans to be located by Architect.

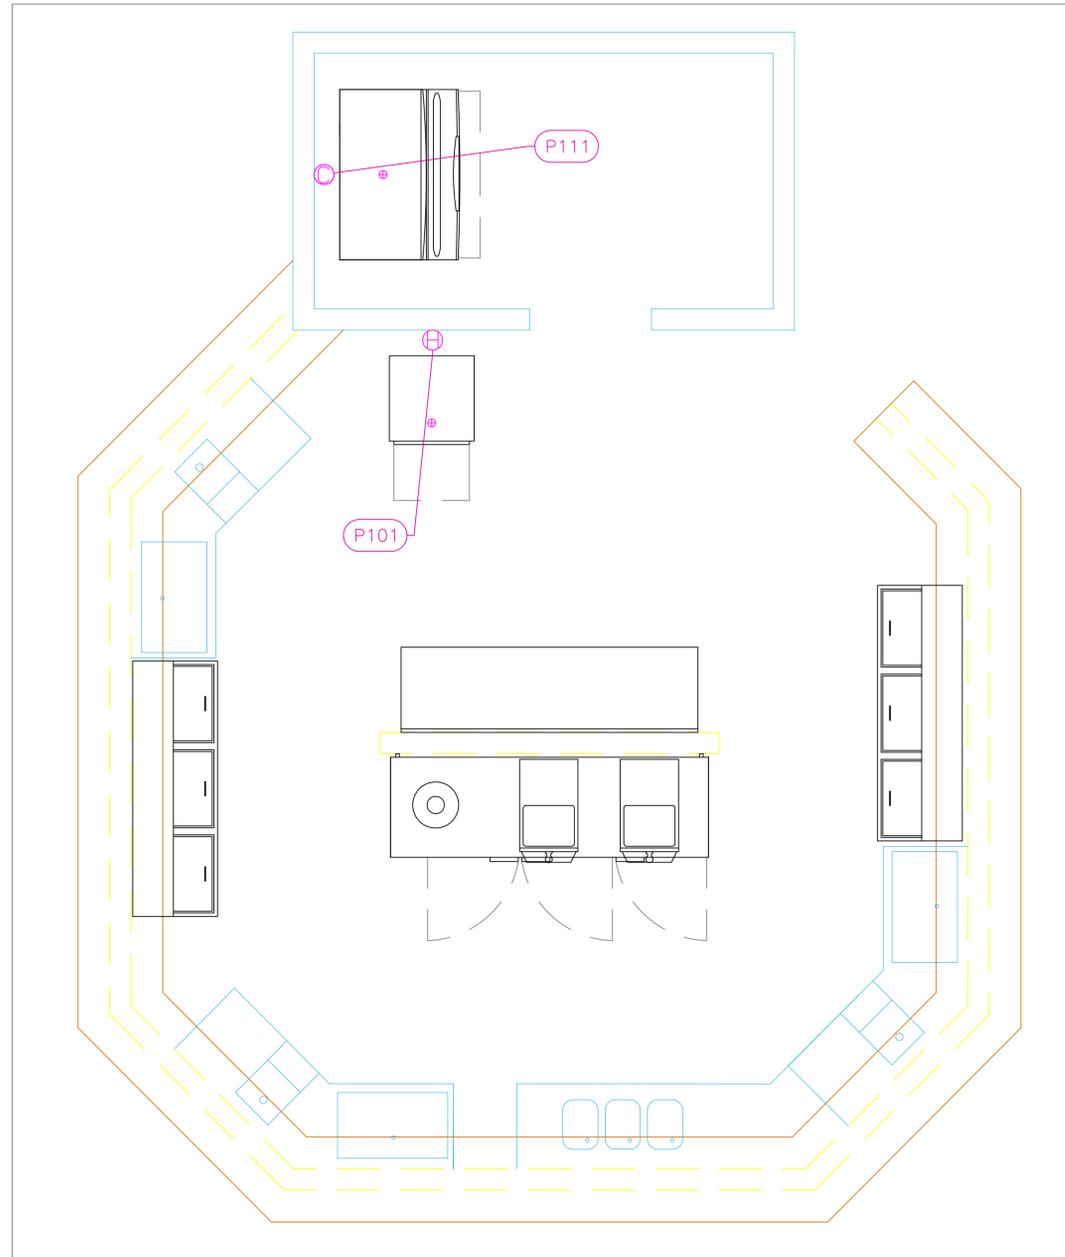

Bell Bar

PLUMBING SCHEDULE											
ITEM NO.	DESCRIPTION	COLD WATER SIZE	HOT WATER SIZE	H&C Rough-In	DIRECT WASTE SIZE	DIRECT WASTE AFF.	INDIRECT WASTE SIZE	GAS SIZE(IN)	GAS MBTU	QTY	PLUMBING REMARKS
101	Dishwasher, Undercounter		1/2"	12"			5/8"			1	1/2" supply; Machine equipped with 3/4" hose connector
111	Ice Maker, Cube-Style	3/8"		12"			1/2"			1	Drain for ice maker
	Ice Bin for Ice Machines						3/4"			1	

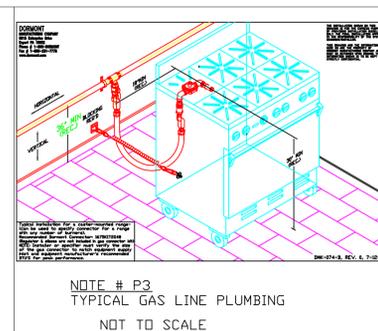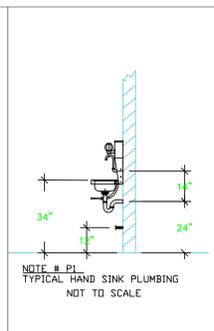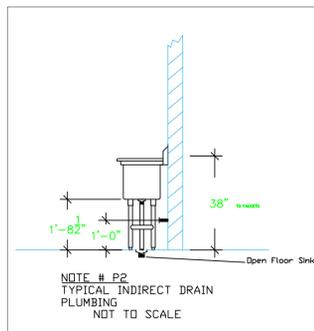

LEGEND -- PLUMBING CONNECTIONS

- HW--HOT WATER, OR CW--COLD WATER
- GAS
- WASTE, DIRECT-CONNECTED
- WASTE, INDIRECT to Floor Sink, or Floor Drain
- FLOOR DRAIN Josam 30000-E3
- FLOOR DRAIN Josam 30000-A3
- FLOOR SINK Proflo PF42856 or similar
- FILTERED WATER, at machine.

NOTE # P4.
ALL NATIONAL, STATE, AND LOCAL CODES SHALL APPLY

NOTE # P5.
ALL PLUMBING CONNECTIONS TO BE EXTENDED AND INTERCONNECTED TO EQUIPMENT AND ALL HARDWARE REQUIRED TO BE PROVIDED BY PLUMBING CONTRACTOR

NOTE # P6.
PLUMBING CONTRACTOR TO VERIFY THAT ALL EQUIPMENT IS INSTALLED WITH THE APPROPRIATE GAS PRESSURE AND REGULATORS

NOTE # P7.
ALL WASTE LINES AND CONDENSATE LINES TO BE EXTEND FROM EQUIPMENT TO FLOOR DRAINS BY PLUMBING CONTRACTOR.

Equipment PLUMBING Service Requirements

All Dimensions to be verified on the job site. Actual locations for floor drains, and any ventilating equipment to be determined by Engineer. Mechanical, Plumbing & Electrical to be checked and verified by Customers MEP Engineer. Remote Condensing Units to be located by Architect. Exhaust & Supply fans to be located by Architect.

1	Preliminary Layout	11-20-23
2	Added Main Kitchen	1-26-24
3	Major Update after site visit.	9-12-24
4	Added Elec & Plumbing Information.	9-20-24
No.	Revision/Issue	Date

Date

Sept 20, 2024

Drawn By

Dayne Gauntlett

Scale

1/2" = 1'0"

Sheet


FS-4.3

Carnival Cruise Lines
Half Moon Cay
Eleuthera, Bahamas

uni-source
SUPPLY




INTERNATIONAL INC.

2055 W 73rd Street, Miami, FL 33016
Ph: (305)826-8696 Fax: (305)826-9131

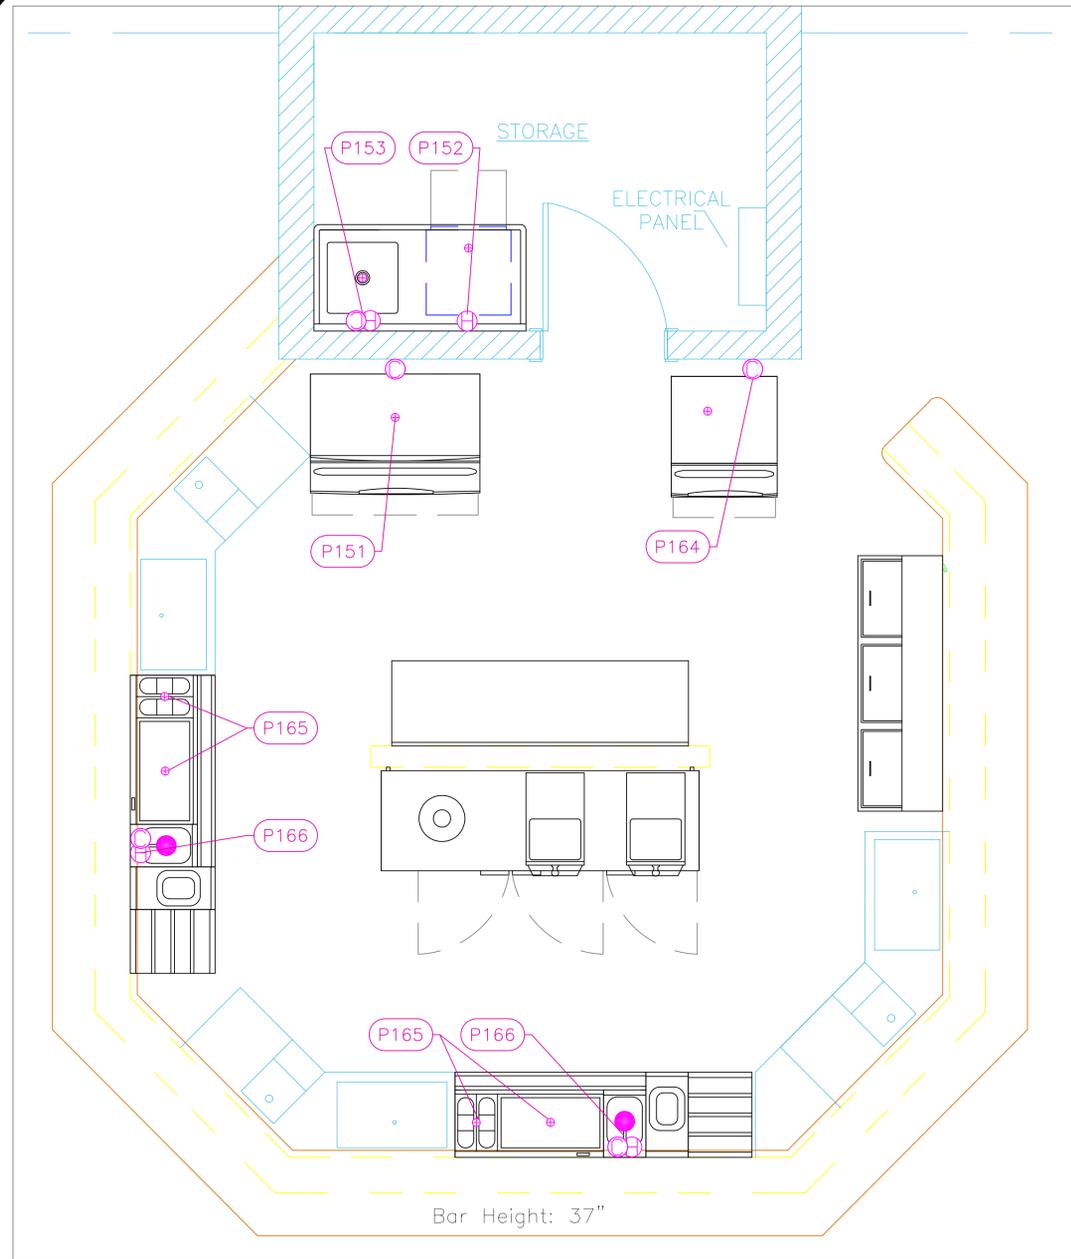

Rumrunners Bar

PLUMBING SCHEDULE											
ITEM NO.	DESCRIPTION	COLD WATER SIZE	HOT WATER SIZE	H&C Rough-In	DIRECT WASTE SIZE	DIRECT WASTE AFF	INDIRECT WASTE SIZE	GAS SIZE(IN)	GAS MBTU	QTY	PLUMBING REMARKS
151	Ice Maker, Cube-Style	3/8"		12"			1/2"			1	Drain for ice maker
	Ice Bin for Ice Machines						3/4"			1	
152	Dishwasher, Undercounter		1/2"	12"			5/8"			1	1/2" supply; Machine equipped with 3/4" hose connector
153	Soiled Dishtable	1/2"	1/2"	12"			1-1/2"			1	
164	Ice Maker, Cube-Style	3/8"		12"			1/2"			1	Drain for ice maker
							3/4"			1	
165	Ice Bin with Bottle Wells						1"			2	Ice bin drain
166	Hand Sink	1/2"	1/2"	12"	1-1/2"	24"				2	Faucet, Sink drain

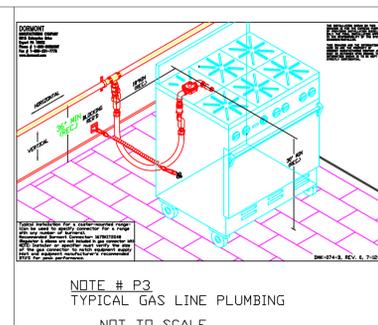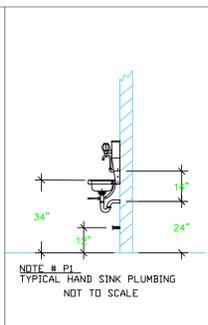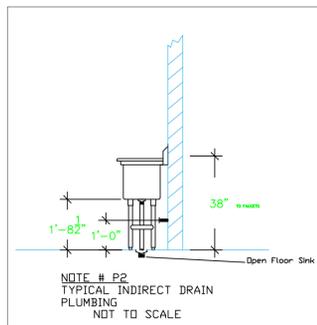

LEGEND -- PLUMBING CONNECTIONS

- HW--HOT WATER, OR CW--COLD WATER
- GAS
- WASTE, DIRECT-CONNECTED
- WASTE, INDIRECT to Floor Sink, or Floor Drain
- FUNNEL FLOOR DRAIN Josam 30000-E3
- FLOOR DRAIN Josam 30000-A3
- FLOOR SINK Proflo PF42856 or similar
- FILTERED WATER, at machine.

NOTE # P4.
ALL NATIONAL, STATE, AND LOCAL
CODES SHALL APPLY

NOTE # P5.
ALL PLUMBING CONNECTIONS TO
BE EXTENDED AND
INTERCONNECTED TO EQUIPMENT
AND ALL HARDWARE REQUIRED TO
BE PROVIDED BY PLUMBING
CONTRACTOR

NOTE # P6.
PLUMBING CONTRACTOR TO VERIFY
THAT ALL EQUIPMENT IS
INSTALLED WITH THE
APPROPRIATE GAS PRESSURE AND
REGULATORS

NOTE # P7.
ALL WASTE LINES AND
CONDENSATE LINES TO BE EXTEND
FROM EQUIPMENT TO FLOOR
DRAINS BY PLUMBING CONTRACTOR.

Equipment PLUMBING Service Requirements

All Dimensions to be verified on the job site.
Actual locations for floor drains, and any ventilating
equipment to be determined by Engineer.
Mechanical, Plumbing & Electrical to be checked and verified
by Customers MEP Engineer.
Remote Condensing Units to be located by Architect.
Exhaust & Supply fans to be located by Architect.

Carnival Cruise Lines
Half Moon Cay
Eleuthera, Bahamas
Carnival

uni-source
SUPPLY
INTERNATIONAL INC.

2055 W 73rd Street, Miami, FL 33016
Ph:(305)826-8696 Fax:(305)826-9131

No.	Revision/Issue	Date
1	Preliminary Layout	11-20-23
2	Added Main Kitchen	1-26-24
3	Major Update after site visit.	9-12-24
4	Added Elec & Plumbing Information.	9-20-24

Date
Sept 20, 2024
Drawn By
Dayne Gauntlett
Scale
1/2" = 1'0"

Sheet
FS-4.4