



Carnival Cruise Lines
Princess Cays
 Eleuthera, Bahamas




INTERNATIONAL INC.
 2055 W 73rd Street, Miami, FL 33016
 Ph: (305)826-8696 Fax: (305)826-9131


1	Preliminary Layout	11-15-23
2	Updated dishroom back to old flight machine	1-26-24
3	Update after site visit Sept 2024	9-17-24
4	Added Ref to 4 corners of pavilion & Added EP	9-30-24
No.	Revision/Issue	Date

Date
Sept 30, 2024
 Drawn By
Dayne Gauntlett
 Scale
NTS

Sheet
FS-1.0

SITE OVERVIEW

All Dimensions to be verified on the job site.
 Actual locations for floor drains, and any ventilating equipment to be determined by Engineer.
 Mechanical, Plumbing & Electrical to be checked and verified by Customers MEP Engineer.
 Remote Condensing Units to be located by Architect.
 Exhaust & Supply fans to be located by Architect.

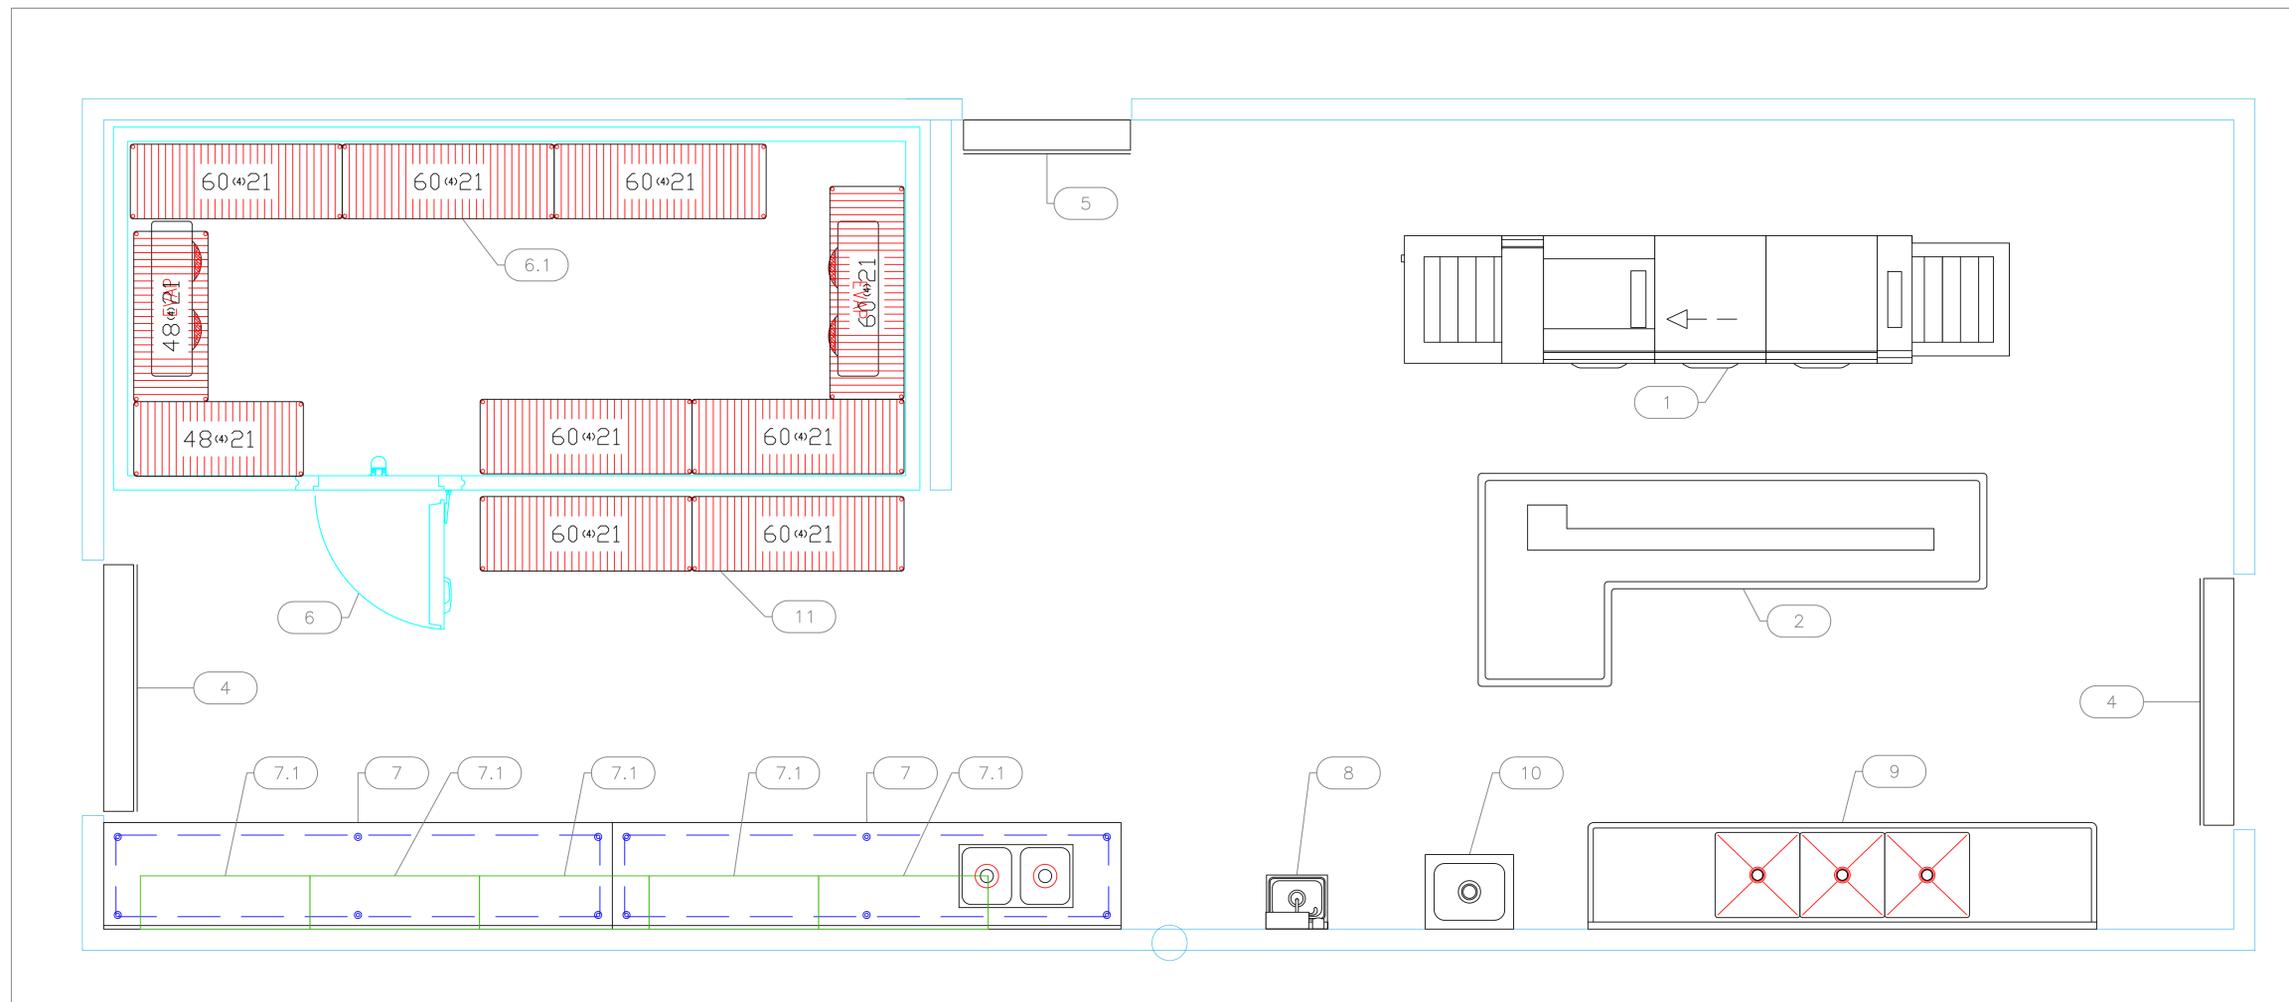

Grill Crazy Kitchen (North Kitchen)

EQUIPMENT SCHEDULE					
ItemNo	Category	Mfr	Model	Quantity	Equipment Remarks
1	Dishwasher, Flight Type	Hobart	FT900S BD	1	Existing
2	Soiled Table	Custom	SOIL TABLE	1	Existing
4	Air Door	Curtron	AP-4-72-2-SS	2	
5	Air Door	Curtron	AP-2-48-1-SS	1	
6	Boltover Door Sections	Kolpak	SO	1	Existing
6.1	Shelving Unit, with Metal Post	Fermod	4R59C71	6	
7	Work Table, Stainless Steel Top	Advance Tabco	KMS-3012	2	Existing
	Weld-in Sink	Advance Tabco	TA-11J-2	1	Existing
7.1	Wall Cabinet	Advance Tabco	WCO-15-48	5	Existing
8	Hand Sink	Advance Tabco	7-PS-69	1	Existing
9	Three (3) Compartment Sink	Advance Tabco	FC-3-2424-36RL-X	1	Existing
10	Mop Sink	Advance Tabco	9-OP-18	1	Existing
11	Shelving Unit, with Metal Post	Fermod	4R59C71	2	

1	Preliminary Layout	11-15-23
2	Updated dishroom back to old flight machine	1-26-24
3	Update after site visit Sept 2024	9-17-24
4	Added Ref to 4 corners of pavilion & Added EP	9-30-24
No.	Revision/Issue	Date

Date
Sept 30, 2024
 Drawn By
Dayne Gauntlett
 Scale
1/2" = 1'0"

Sheet
FS-1.1


EQUIPMENT LAYOUT

All Dimensions to be verified on the job site.
 Actual locations for floor drains, and any ventilating equipment to be determined by Engineer.
 Mechanical, Plumbing & Electrical to be checked and verified by Customers MEP Engineer.
 Remote Condensing Units to be located by Architect.
 Exhaust & Supply fans to be located by Architect.

1	Preliminary Layout	11-15-23
2	Updated dishroom back to old flight machine	1-26-24
3	Update after site visit Sept 2024	9-17-24
4	Added Ref to 4 corners of pavilion & Added EP	9-30-24
No.	Revision/Issue	Date

Date
Sept 30, 2024
Drawn By
Dayne Gauntlett
Scale
1/4" = 1'0"

Sheet
FS-1.2

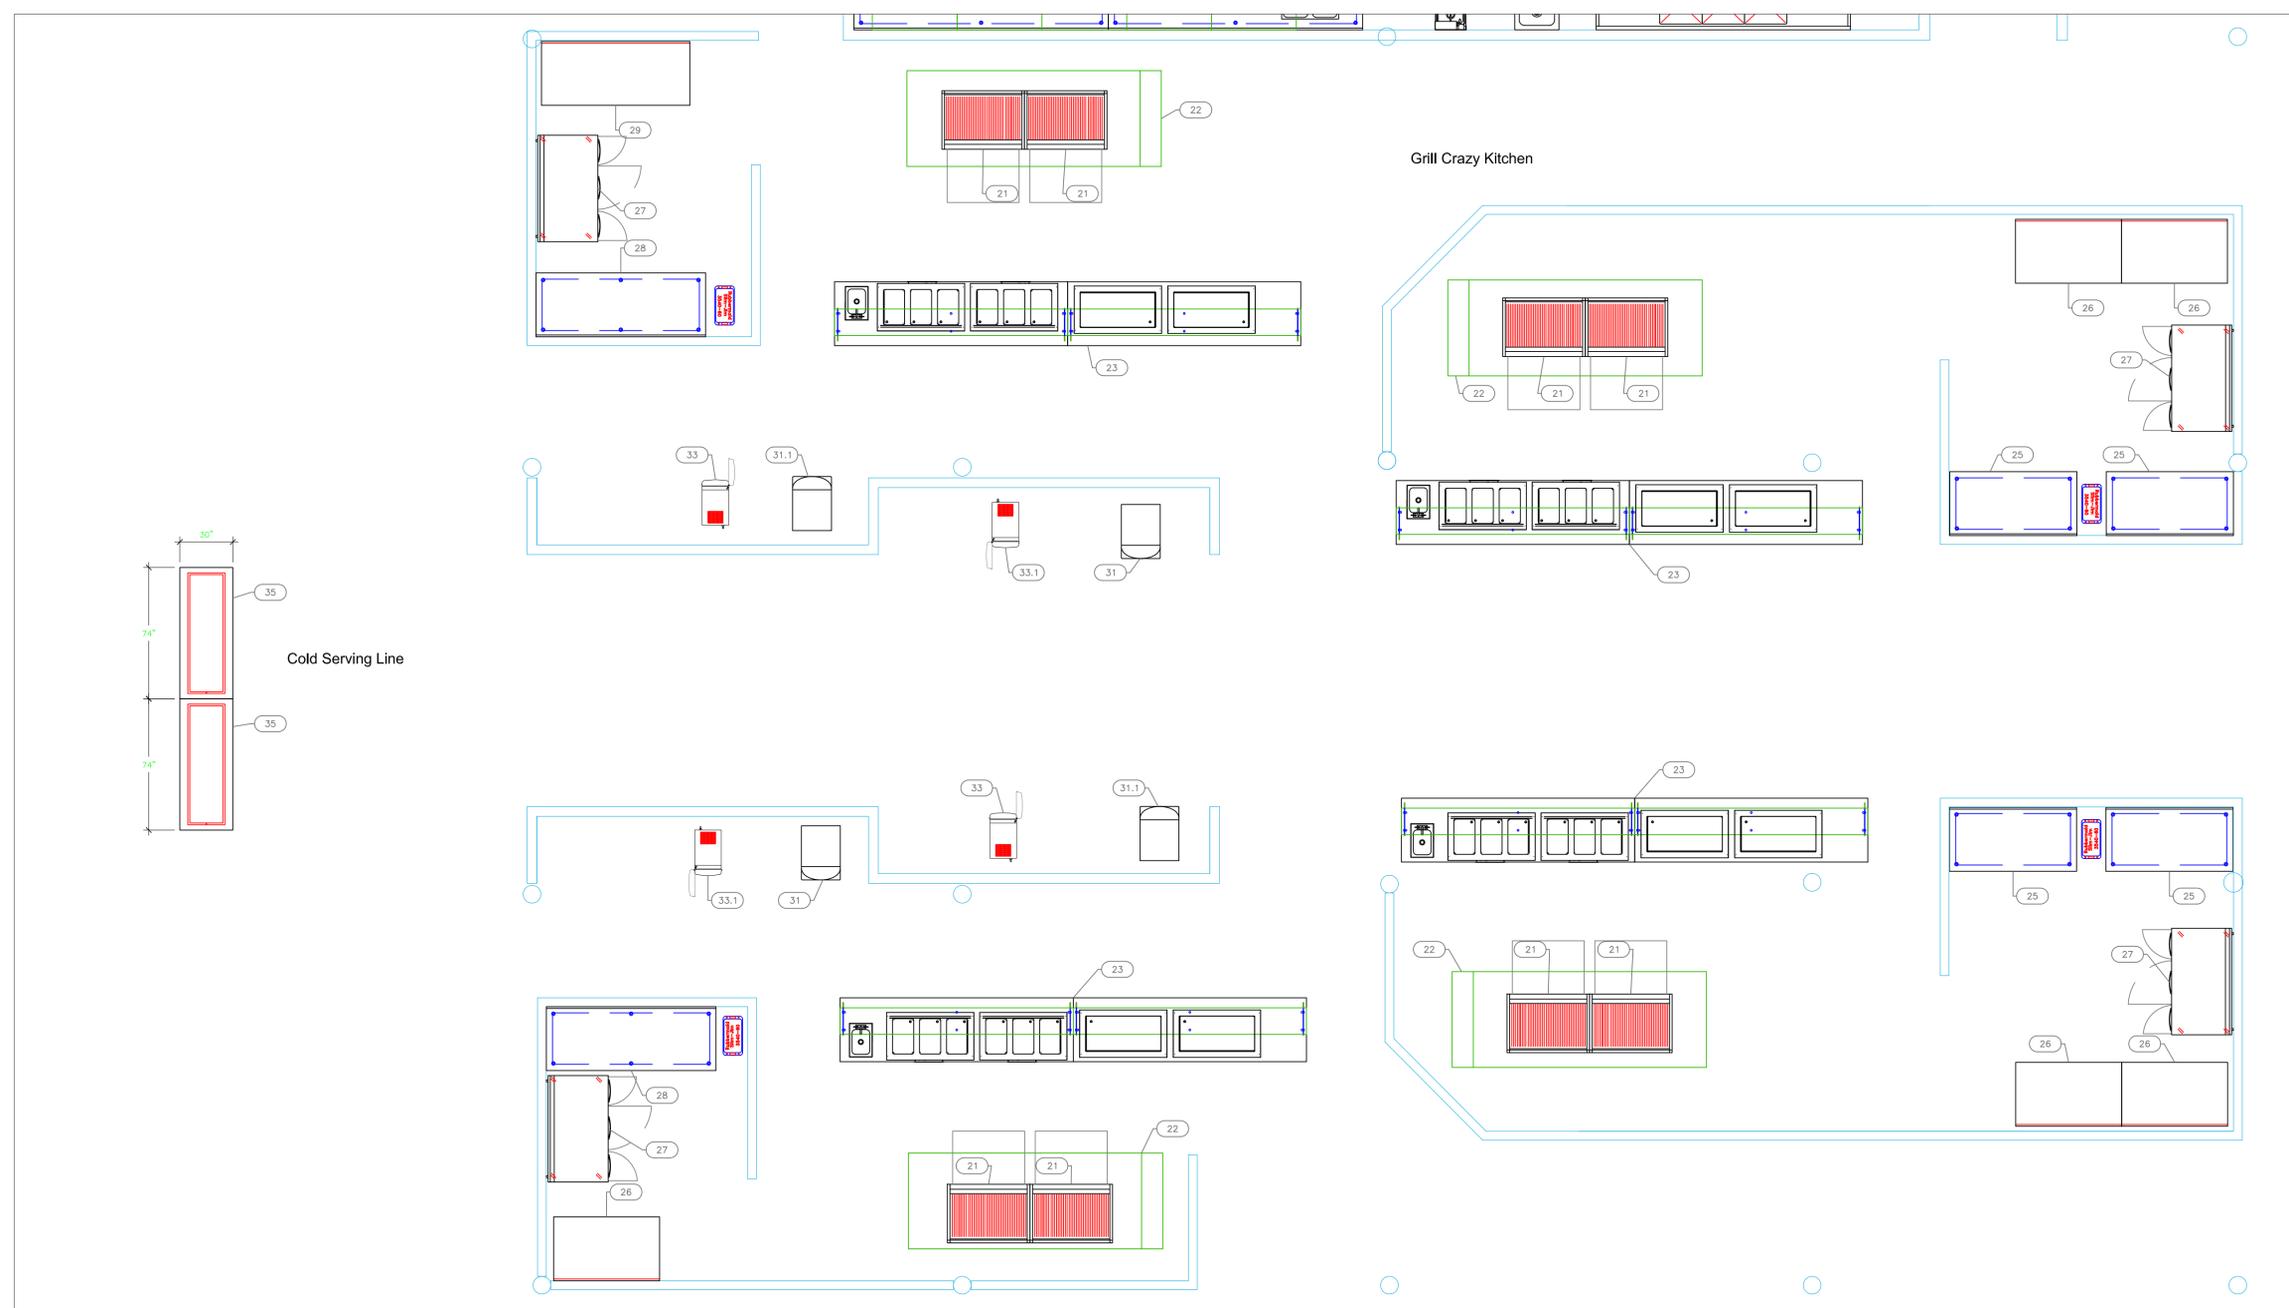

Grill Crazy BBQ Pavilion

EQUIPMENT SCHEDULE					
ItemNo	Category	Mfr	Model	Quantity	Equipment Remarks
21	Charbroiler, Gas, Countertop	Vulcan	VACB47	8	Existing
22	Main Hood	Captive-Aire	HOOD	4	Existing
22.1	Exhaust Fan	Captive-Aire	E FAN	4	Existing
23	Custom Serving Line	Randell	CUSTOM	4	Existing
25	Work Table, Stainless Steel Top	Advance Tabco	KSS-366	4	
26	Work Table, Cabinet Base Open Front	Advance Tabco	EK-SS-365	5	
27	Refrigerated Work Top	Continental Refrigerator	RA60NBS	4	
28	Work Table, Stainless Steel Top	Advance Tabco	KSS-368	2	
29	Work Table, Cabinet Base Open Front	Advance Tabco	EK-SS-367	1	
31	Ice Dispenser	Multiplex	2704811	2	Existing
31.1	Ice Dispenser	Hoshizaki	DM-4420N	2	
33	Juice Dispenser, Electric	BUNN	37300.0000	2	Existing
33.1	Juice Dispenser, Electric	BUNN	37300.0000	2	
35	Serving Counter, Frost Top	Piper Products	R5-FT	2	
	Sneeze Guard, Stationary	Piper Products	RBPGC-74	2	


EQUIPMENT LAYOUT

All Dimensions to be verified on the job site.
Actual locations for floor drains, and any ventilating equipment to be determined by Engineer.
Mechanical, Plumbing & Electrical to be checked and verified by Customers MEP Engineer.
Remote Condensing Units to be located by Architect.
Exhaust & Supply fans to be located by Architect.

1	Preliminary Layout	11-15-23
2	Updated dishroom back to old flight machine	1-26-24
3	Update after site visit Sept 2024	9-17-24
4	Added Ref to 4 corners of pavilion & Added EP	9-30-24
No.	Revision/Issue	Date


Date
Sept 30, 2024
 Drawn By
Dayne Gauntlett
 Scale
1/4" = 1'0"

Sheet
FS-1.3

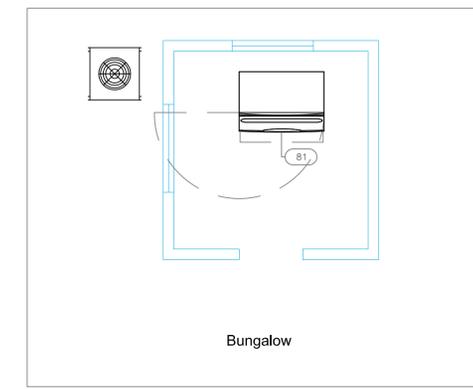


Bungalow
Hummingbird

EQUIPMENT SCHEDULE					
ItemNo	Category	Mfr	Model	Quantity	Equipment Remarks
81	Ice Maker, Cube-Style	Manitowoc	IDT1900N	1	
	Remote Condenser Unit	Manitowoc	JCT1500-261	1	
	Ice Bin for Ice Machines	Manitowoc	D970	1	

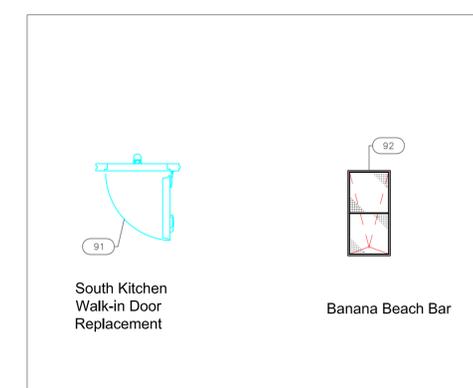


Miscellaneous

EQUIPMENT SCHEDULE					
ItemNo	Category	Mfr	Model	Quantity	Equipment Remarks
91	Boltover Door Sections	Kolpak	SO	1	Existing
92	Iced Beer Display	Glastender	MIB-48	1	
999	Freight	UNI	FREIGHT	1	

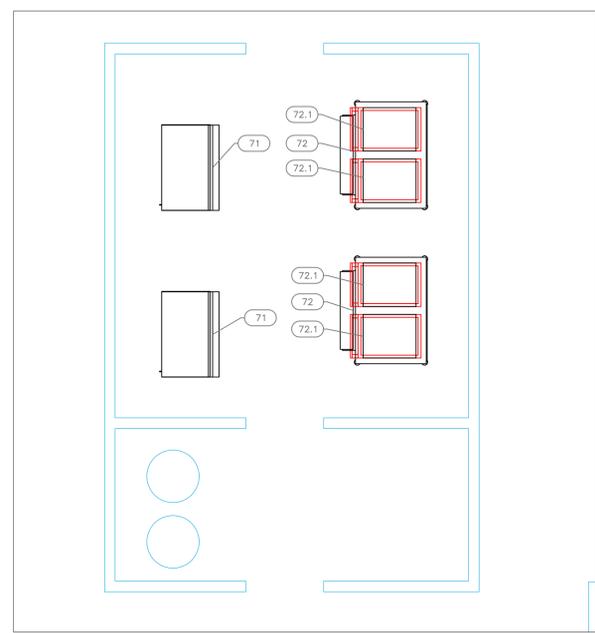

North Ice Room

EQUIPMENT SCHEDULE					
ItemNo	Category	Mfr	Model	Quantity	Equipment Remarks
71	Ice Maker, Cube-Style	Hoshizaki	KM-1900SRJZ	2	
	Ice Bin for Ice Machines	Hoshizaki	B-800SF	2	
72	Ice Bin Shuttle System	Follett Products (Middleby)	ITS1350SG-60	2	
72.1	Ice Maker, Cube-Style	Manitowoc	IDT1200N	4	
	Remote Condenser Unit	Manitowoc	JCT1200-261	4	

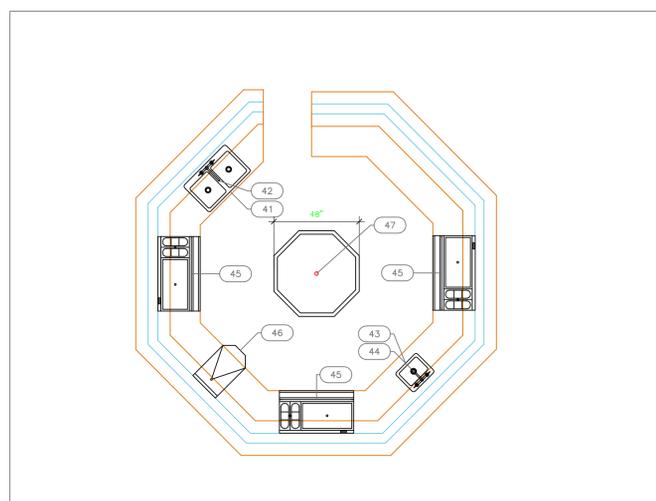


Reef Runner Bar

EQUIPMENT SCHEDULE					
ItemNo	Category	Mfr	Model	Quantity	Equipment Remarks
41	Drop-In Sink	Advance Tabco	SS-2-3321-10	1	
42	Deck Mount Faucet	Krowne	DX-910	1	
43	Drop-In Sink	Advance Tabco	SS-1-1715-10	1	
44	Deck Mount Faucet	Krowne	DX-908	1	
45	Ice Bin with Bottle Wells	Krowne	KR19-M42R	3	
46	Blender Station	Krowne	KR29-18FD	1	
47	Ice Bin / Ice Caddy, Mobile	Custom Fab	CUSTOM	1	

EQUIPMENT LAYOUT

All Dimensions to be verified on the job site.
 Actual locations for floor drains, and any ventilating equipment to be determined by Engineer.
 Mechanical, Plumbing & Electrical to be checked and verified by Customers MEP Engineer.
 Remote Condensing Units to be located by Architect.
 Exhaust & Supply fans to be located by Architect.

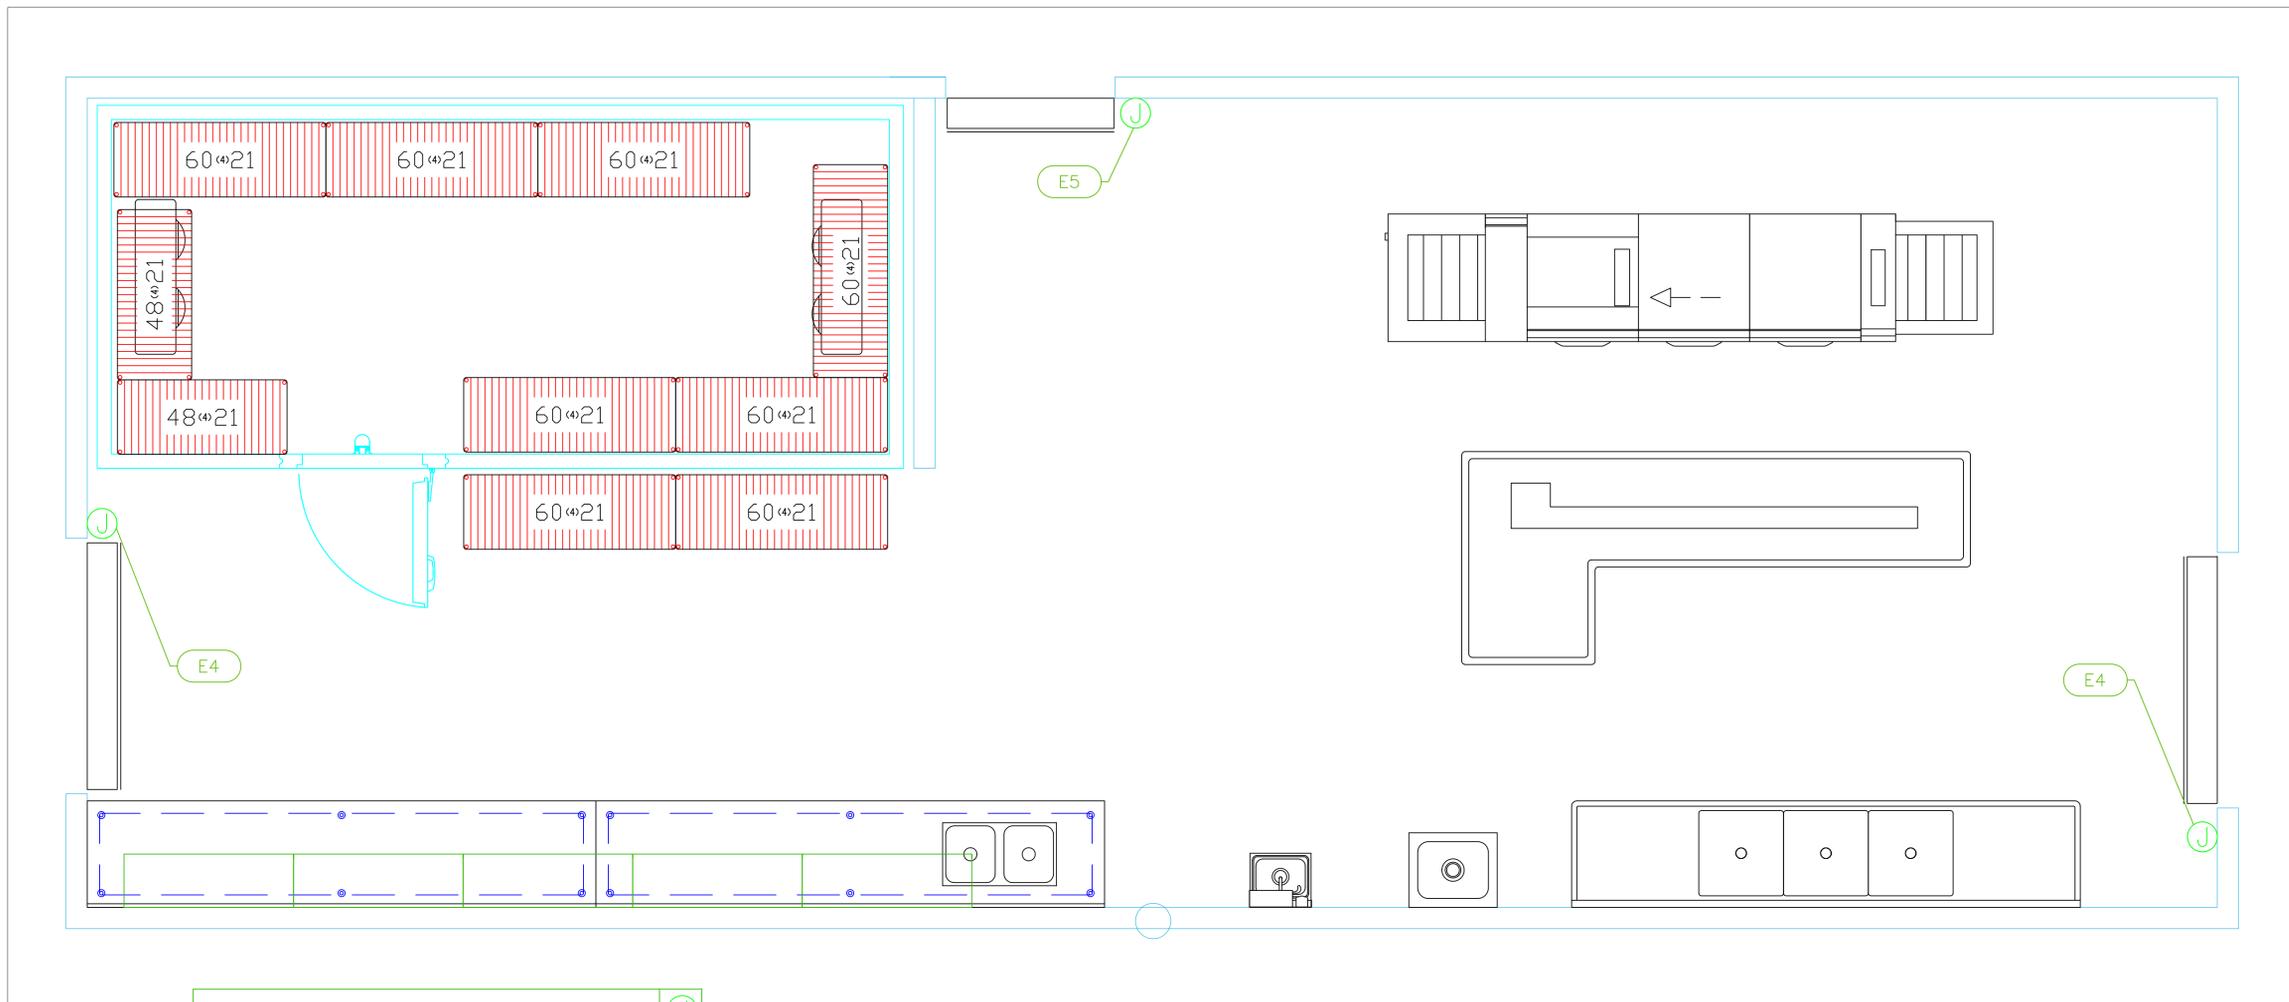


Grill Crazy Kitchen (North Kitchen)

ELECTRICAL SCHEDULE												
ItemNo	Category	Voltage	Cycle	Phase	Amps	Hp	NEMA	ConnectionType	Rough-In AFF	Quantity	Electrical Remarks	
1	Dishwasher, Flight Type	208	60	3	100.0				36"	1	Confirm Elec with Site	
4	Air Door	120	60	1	8.33	(2) 1/6		J-Box	86"	2		
5	Air Door	120	60	1	5.42	1/6		J-Box	86"	1		

LEGEND - ELECTRICAL CONNECTIONS

- DUPLEX RECEPT., 15-AMP, 120-VOLT, GROUND TYPE, HORIZONTAL MOUNT
- SIMPLEX RECEPT., 120-VOLT, GROUND TYPE, HORIZONTAL MOUNT
- SPECIAL PURPOSE OUTLET, GROUND TYPE, HORIZONTAL MOUNT
- JUNCTION BOX, DIRECT CONNECTION
- DISCONNECT SWITCH, DIRECT CONNECTION
- FLOOR/CEILING RECEPTACLE AS INDICATED
- (2) Telephone + (2) Data
- FIELD CONNECTIONS
- HARD WIRE CONNECTION POINT AT MACHINE

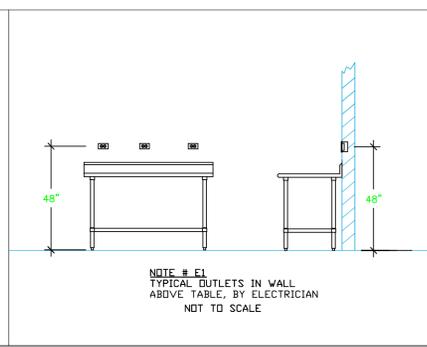

NOTE # E2
ALL NATIONAL, STATE, AND LOCAL CODES SHALL APPLY.

NOTE # E3
ALL ELECTRICAL CONNECTIONS AND HARDWARE REQUIRED TO BE PROVIDED BY ELECTRICAL CONTRACTOR.

NOTE # E4
ALL JUNCTION BOXES, OUTLETS, ETC. TO BE LOCATED SO AS TO NOT INTERFERE WITH EQUIPMENT.

NOTE # E5
ALL RELAYS, CONTRACTORS, STARTERS, AND SWITCHES REQUIRED FOR EXHAUST & SUPPLY FANS TO BE PROVIDED BY ELECTRICAL CONTRACTOR UNLESS SPECIFIED.

NOTE # E6
ELECTRICAL CONTRACTOR TO INTERCONNECT DISHMACHINE TO EXHAUST FAN FOR DISHMACHINE SO THAT THE FAN RUNS WHEN THE DISHMACHINE IS IN OPERATION.

NOTE # E7
ELECTRICAL CONTRACTOR TO INSTALL TABLE LIMIT SWITCH TO END OF CLEAN DISHTABLE TO THAT MACHINE STOPS WHEN SWITCH IS DEPRESSED.

NOTE # E8
ELECTRICAL CONTRACTOR TO CONNECT DRAIN LINE HEATER, PAN HEATER AND DDOR HEATER FOR WALK-IN FREEZER.

Equipment ELECTRICAL Service Requirements

All Dimensions to be verified on the job site. Actual locations for floor drains, and any ventilating equipment to be determined by Engineer. Mechanical, Plumbing & Electrical to be checked and verified by Customers MEP Engineer. Remote Condensing Units to be located by Architect. Exhaust & Supply fans to be located by Architect.

Carnival Cruise Lines
Princess Cays
Eleuthera, Bahamas

INTERNATIONAL INC.
2055 W 73rd Street, Miami, FL 33016
Ph: (305) 826-8696 Fax: (305) 826-9131

1	Preliminary Layout	11-15-23
2	Updated dishroom back to old flight machine	1-26-24
3	Update after site visit Sept 2024	9-17-24
4	Added Ref to 4 corners of pavilion & Added EP	9-30-24
No.	Revision/Issue	Date

Date
Sept 30, 2024

Drawn By
Dayne Gauntlett


Scale
1/2" = 1'0"

Sheet
FS-3.1

1	Preliminary Layout	11-15-23
2	Updated dishroom back to old flight machine	1-26-24
3	Update after site visit Sept 2024	9-17-24
4	Added Ref to 4 corners of pavilion & Added EP	9-30-24
No.	Revision/Issue	Date

Date
Sept 30, 2024
Drawn By
Dayne Gauntlett
Scale
1/4" = 1'0"


Sheet
FS-3.2

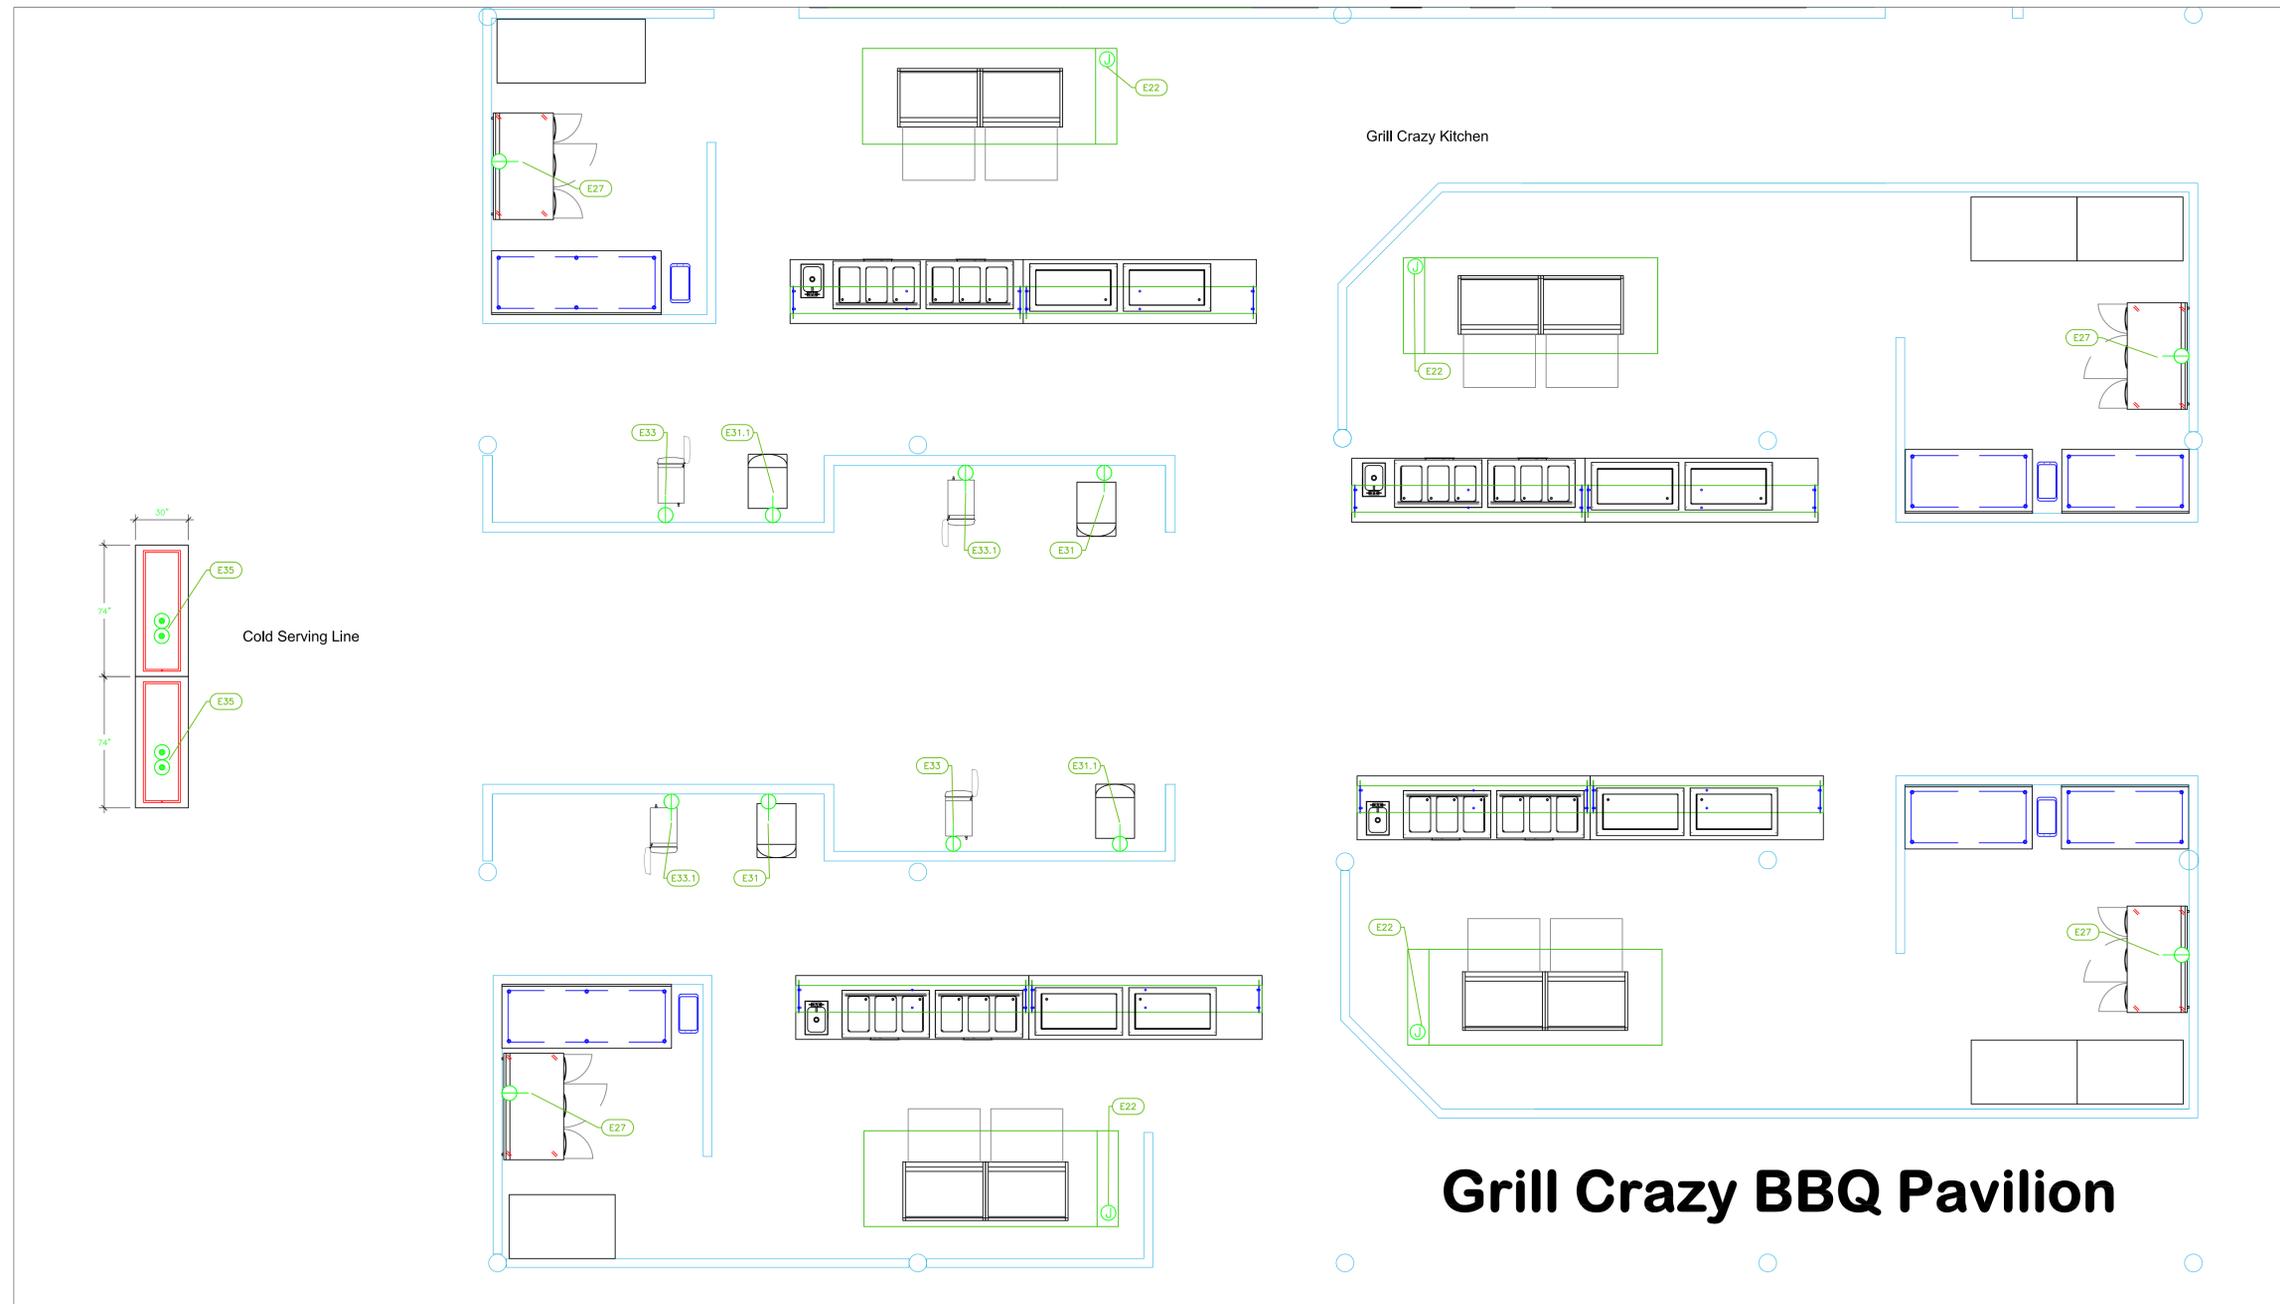

Grill Crazy BBQ Pavilion

ItemNo	Category	Voltage	Cycle	Phase	Amps	Hp	NEMA	ConnectionType	Rough-In AFF	Quantity	Electrical Remarks
22	Main Hood	115	60	1	15.0			J-BOX	108"	4	Confirm Elec with Site
22.1	Exhaust Fan	208	60	3	15	5		J-Box	108"	4	Confirm Elec with Site
27	Refrigerated Work Top	115	60	1	4.8	1/4	5-15P	Simplex	18"	4	
31	Ice Dispenser	120	60	1	2.8		5-15P	Simplex	48"	2	


ItemNo	Category	Voltage	Cycle	Phase	Amps	Hp	NEMA	ConnectionType	Rough-In AFF	Quantity	Electrical Remarks
31.1	Ice Dispenser	115	60	1	3		5-15P	Simplex	48"	2	
33	Juice Dispenser, Electric	120	60	1	6		5-15P	Simplex	48"	2	
33.1	Juice Dispenser, Electric	120	60	1	6		5-15P	Simplex	48"	2	
35	Serving Counter, Frost Top	120	60	1	6.3		5-15P	Floor	0"	2	See Note E9
		120	60	1			5-15P	Floor	0"	2	See Note E9

 

NOTE # E9
TYPICAL ELECTRICAL UTILITY CURB
NOT TO SCALE

LEGEND - ELECTRICAL CONNECTIONS

- DUPLEX RECEPT., 15-AMP, 120-VOLT, GROUND TYPE, HORIZONTAL MOUNT
- SIMPLEX RECEPT., 120-VOLT, GROUND TYPE, HORIZONTAL MOUNT
- SPECIAL PURPOSE OUTLET, GROUND TYPE, HORIZONTAL MOUNT
- JUNCTION BOX, DIRECT CONNECTION
- DISCONNECT SWITCH, DIRECT CONNECTION
- FLOOR/CEILING RECEPTACLE AS INDICATED
- (2) Telephone + (2) Data
- FIELD CONNECTIONS
- HARD WIRE CONNECTION POINT AT MACHINE

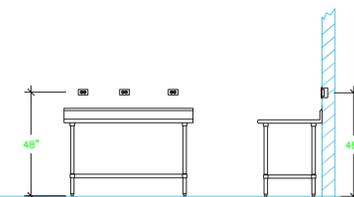

NOTE # E1
TYPICAL OUTLETS IN WALL ABOVE TABLE, BY ELECTRICIAN
NOT TO SCALE

NOTE # E2
ALL NATIONAL, STATE, AND LOCAL CODES SHALL APPLY

NOTE # E3
ALL ELECTRICAL CONNECTIONS AND HARDWARE REQUIRED TO BE PROVIDED BY ELECTRICAL CONTRACTOR

NOTE # E4
ALL JUNCTION BOXES, OUTLETS, ETC. TO BE LOCATED SO AS TO NOT INTERFERE WITH EQUIPMENT

NOTE # E5
ALL RELAYS, CONTRACTORS, STARTERS, AND SWITCHES REQUIRED FOR EXHAUST & SUPPLY FANS TO BE PROVIDED BY ELECTRICAL CONTRACTOR UNLESS SPECIFIED

NOTE # E6
ELECTRICAL CONTRACTOR TO INTERCONNECT DISHMACHINE TO EXHAUST FAN FOR DISHMACHINE SO THAT THE FAN RUNS WHEN THE DISHMACHINE IS IN OPERATION.

NOTE # E7
ELECTRICAL CONTRACTOR TO INSTALL TABLE LIMIT SWITCH TO END OF CLEAN DISHTABLE TO THAT MACHINE STOPS WHEN SWITCH IS DEPRESSED.

NOTE # E8
ELECTRICAL CONTRACTOR TO CONNECT DRAIN LINE HEATER, PAN HEATER AND DODR HEATER FOR WALK-IN FREEZER.


Equipment ELECTRICAL Service Requirements

All Dimensions to be verified on the job site. Actual locations for floor drains, and any ventilating equipment to be determined by Engineer. Mechanical, Plumbing & Electrical to be checked and verified by Customers MEP Engineer. Remote Condensing Units to be located by Architect. Exhaust & Supply fans to be located by Architect.

1	Preliminary Layout	11-15-23
2	Updated dishroom back to old flight machine	1-26-24
3	Update after site visit Sept 2024	9-17-24
4	Added Ref to 4 corners of pavilion & Added EP	9-30-24
No.	Revision/Issue	Date


Date
Sept 30, 2024
Drawn By
Dayne Gauntlett
Scale
1/4" = 1'0"

Sheet
FS-3.3

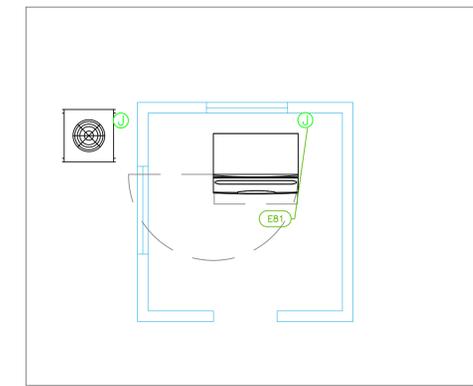


Hummingbird

ELECTRICAL SCHEDULE											
ItemNo	Category	Voltage	Cycle	Phase	Amps	Hp	NEMA	ConnectionType	Rough-In AFF	Quantity	Electrical Remarks
81	Ice Maker, Cube-Style	208-230	60	3	13.1			J-Box	36"	1	
	Remote Condenser Unit	208-230	60	1	1.0			J-Box	36"	1	

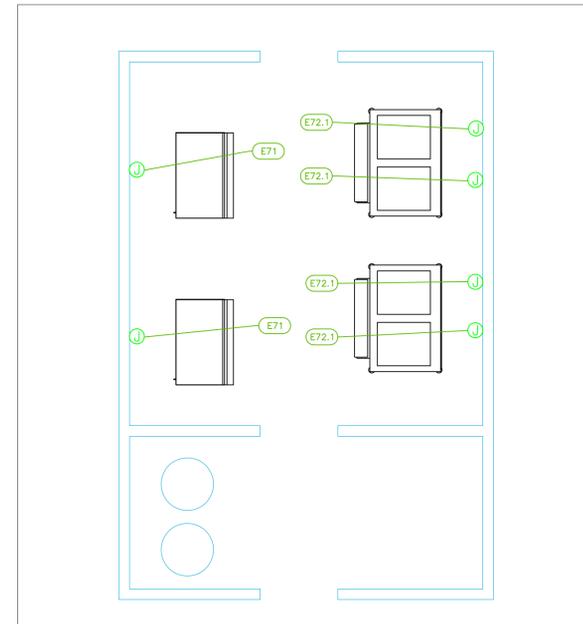


North Ice Room

ELECTRICAL SCHEDULE											
ItemNo	Category	Voltage	Cycle	Phase	Amps	Hp	NEMA	ConnectionType	Rough-In AFF	Quantity	Electrical Remarks
71	Ice Maker, Cube-Style	208-230	60	1	15.9			J-Box	36"	2	
72.1	Ice Maker, Cube-Style	208-230	60	1	11.0			J-Box	36"	4	
	Remote Condenser Unit	208-230	60	1	1.0			J-Box	36"	4	

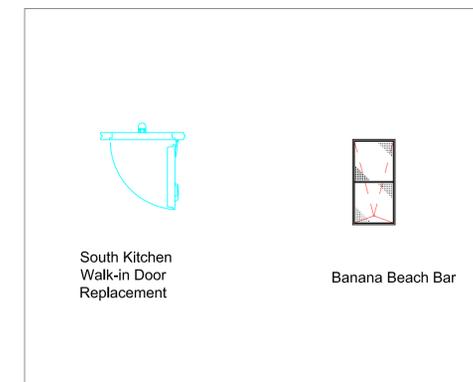


Miscellaneous

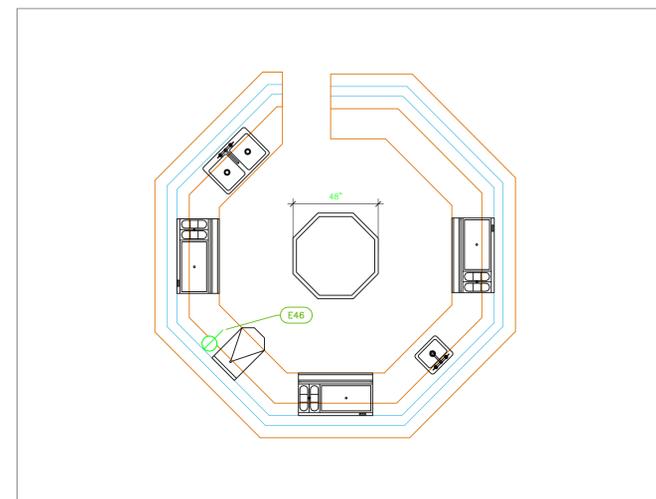

Reef Runner Bar


ELECTRICAL SCHEDULE											
ItemNo	Category	Voltage	Cycle	Phase	Amps	Hp	NEMA	ConnectionType	Rough-In AFF	Quantity	Electrical Remarks
46	Blender Station	115	60	1	15			Simplex	14"	1	

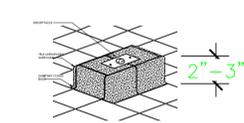

NOTE # E9
TYPICAL ELECTRICAL UTILITY CURB
NOT TO SCALE

LEGEND -- ELECTRICAL CONNECTIONS

- DUPLEX RECEPT., 15-AMP, 120-VOLT, GROUND TYPE, HORIZONTAL MOUNT
- SIMPLEX RECEPT., 120-VOLT, GROUND TYPE, HORIZONTAL MOUNT
- SPECIAL PURPOSE OUTLET, GROUND TYPE, HORIZONTAL MOUNT
- JUNCTION BOX, DIRECT CONNECTION
- DISCONNECT SWITCH, DIRECT CONNECTION
- FLOOR/CEILING RECEPTACLE AS INDICATED
- (2) Telephone + (2) Data
- FIELD CONNECTIONS
- HARD WIRE CONNECTION POINT AT MACHINE

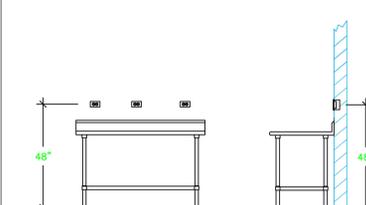

NOTE # E1
TYPICAL OUTLETS IN WALL ABOVE TABLE, BY ELECTRICIAN
NOT TO SCALE

NOTE # E2
ALL NATIONAL, STATE, AND LOCAL CODES SHALL APPLY

NOTE # E3
ALL ELECTRICAL CONNECTIONS AND HARDWARE REQUIRED TO BE PROVIDED BY ELECTRICAL CONTRACTOR

NOTE # E4
ALL JUNCTION BOXES, OUTLETS, ETC. TO BE LOCATED SO AS TO NOT INTERFERE WITH EQUIPMENT

NOTE # E5
ALL RELAYS, CONTRACTORS, STARTERS, AND SWITCHES REQUIRED FOR EXHAUST & SUPPLY FANS TO BE PROVIDED BY ELECTRICAL CONTRACTOR UNLESS SPECIFIED


NOTE # E6
ELECTRICAL CONTRACTOR TO INTERCONNECT DISHMACHINE TO EXHAUST FAN FOR DISHMACHINE SO THAT THE FAN RUNS WHEN THE DISHMACHINE IS IN OPERATION.

NOTE # E7
ELECTRICAL CONTRACTOR TO INSTALL TABLE LIMIT SWITCH TO END OF CLEAN DISHTABLE TO THAT MACHINE STOPS WHEN SWITCH IS DEPRESSED.

NOTE # E8
ELECTRICAL CONTRACTOR TO CONNECT DRAIN LINE HEATER, PAN HEATER AND DDDR HEATER FOR WALK-IN FREEZER.




Equipment ELECTRICAL Service Requirements

All Dimensions to be verified on the job site. Actual locations for floor drains, and any ventilating equipment to be determined by Engineer. Mechanical, Plumbing & Electrical to be checked and verified by Customers MEP Engineer. Remote Condensing Units to be located by Architect. Exhaust & Supply fans to be located by Architect.

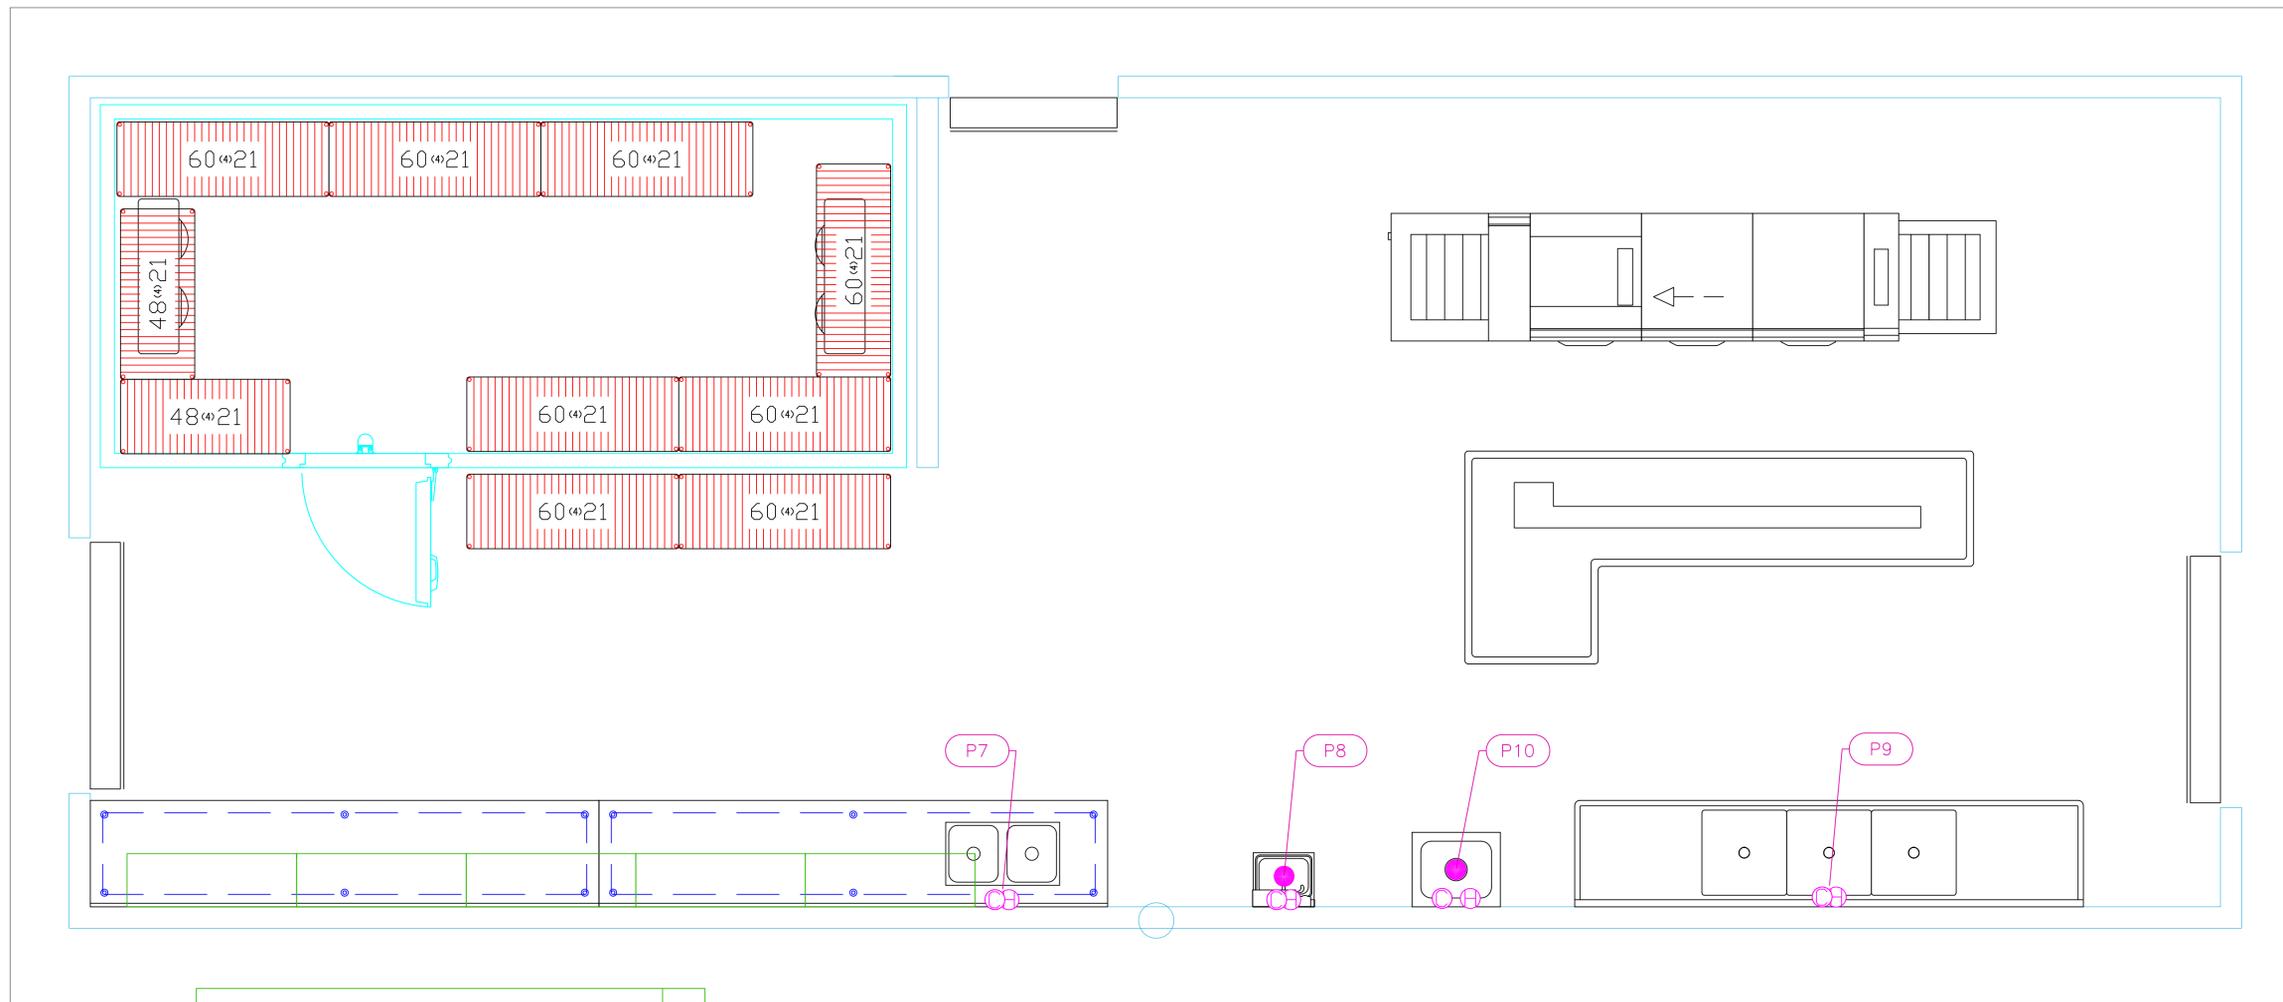

Grill Crazy Kitchen (North Kitchen)

PLUMBING SCHEDULE											
ITEM NO.	DESCRIPTION	COLD WATER SIZE	HOT WATER SIZE	H&C Rough-In	DIRECT WASTE SIZE	DIRECT WASTE WASTE AFF	INDIRECT WASTE SIZE	GAS SIZE(IN)	GAS MBTU	QTY	PLUMBING REMARKS
1	Dishwasher, Flight Type		1"	12"			2"			1	Waste to Floor Sink
7	Work Table, Stainless Steel Top Weld-in Sink						(2) 1-1/2"			2	Waste to Floor Sink
8	Hand Sink	1/2"	1/2"	12"	1-1/2"	24"				1	See Note P1
9	Three (3) Compartment Sink						(3) 1-1/2"			1	Waste to Floor Sink
10	Mop Sink				2"	0"				1	

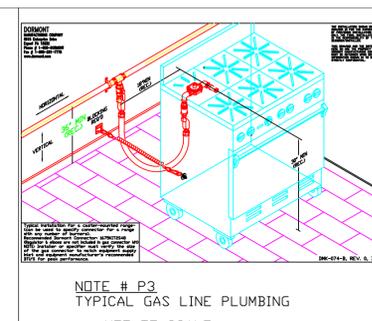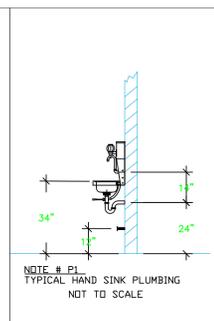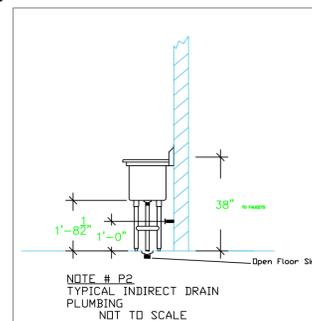

- LEGEND -- PLUMBING CONNECTIONS**
- HW--HOT WATER, OR CW--COLD WATER
 - ⊕ GAS
 - WASTE, DIRECT--CONNECTED
 - ⊕ WASTE, INDIRECT to Floor Sink, or Floor Drain
 - ⊕ FUNNEL FLOOR DRAIN Josam 30000-E3
 - ⊕ FLOOR DRAIN Josam 30000-A3
 - ⊕ FLOOR SINK Proflo PF42856 or similar
 - ⊕ FILTERED WATER, at machine.
- NOTE # P4.
ALL NATIONAL, STATE, AND LOCAL CODES SHALL APPLY
- NOTE # P5.
ALL PLUMBING CONNECTIONS TO BE EXTENDED AND INTERCONNECTED TO EQUIPMENT AND ALL HARDWARE REQUIRED TO BE PROVIDED BY PLUMBING CONTRACTOR
- NOTE # P6.
PLUMBING CONTRACTOR TO VERIFY THAT ALL EQUIPMENT IS INSTALLED WITH THE APPROPRIATE GAS PRESSURE AND REGULATORS
- NOTE # P7.
ALL WASTE LINES AND CONDENSATE LINES TO BE EXTEND FROM EQUIPMENT TO FLOOR DRAINS BY PLUMBING CONTRACTOR.

Equipment PLUMBING Service Requirements

All Dimensions to be verified on the job site. Actual locations for floor drains, and any ventilating equipment to be determined by Engineer. Mechanical, Plumbing & Electrical to be checked and verified by Customers MEP Engineer. Remote Condensing Units to be located by Architect. Exhaust & Supply fans to be located by Architect.

Carnival Cruise Lines
Princess Cays
Eleuthera, Bahamas

INTERNATIONAL INC.
2055 W 73rd Street, Miami, FL 33016
Ph:(305)826-8696 Fax:(305)826-9131

1	Preliminary Layout	11-15-23
2	Updated dishroom back to old flight machine	1-26-24
3	Update after site visit Sept 2024	9-17-24
4	Added Ref to 4 corners of pavilion & Added EP	9-30-24
No.	Revision/Issue	Date

Date
Sept 30, 2024
Drawn By
Dayne Gauntlett
Scale
1/2" = 1'0"

Sheet
FS-4.1



INTERNATIONAL INC.
2055 W 73rd Street, Miami, FL 33016
Ph:(305)826-8696 Fax:(305)826-9131

1	Preliminary Layout	11-15-23
2	Updated dishroom back to old flight machine	1-26-24
3	Update after site visit Sept 2024	9-17-24
4	Added Ref to 4 corners of pavilion & Added EP	9-30-24
No.	Revision/Issue	Date

Date
Sept 30, 2024
Drawn By
Dayne Gauntlett
Scale
1/4" = 1'0"

Sheet
FS-4.2




Grill Crazy Kitchen

Grill Crazy BBQ Pavilion

Cold Serving Line

PLUMBING SCHEDULE								
ITEM NO.	DESCRIPTION	COLD WATER SIZE	HOT WATER SIZE	H&C Rough-In	DIRECT WASTE SIZE	DIRECT WASTE AFF	INDIRECT WASTE SIZE	PLUMBING REMARKS
21	Charbroiler, Gas, Countertop							See Note P3
31	Ice Dispenser	3/8"		48"			3/4"	Waste to Floor Sink
31.1	Ice Dispenser	3/8"		48"			3/4"	Waste to Floor Sink

PLUMBING SCHEDULE								
ITEM NO.	DESCRIPTION	COLD WATER SIZE	HOT WATER SIZE	H&C Rough-In	DIRECT WASTE SIZE	DIRECT WASTE AFF	INDIRECT WASTE SIZE	PLUMBING REMARKS
33	Juice Dispenser, Electric	3/8"		48"				
33.1	Juice Dispenser, Electric	3/8"		48"				

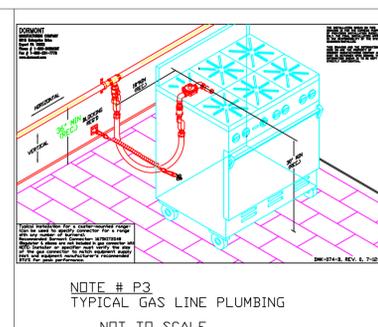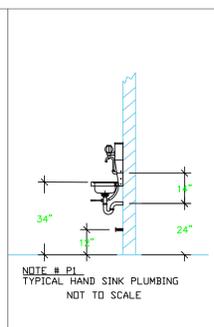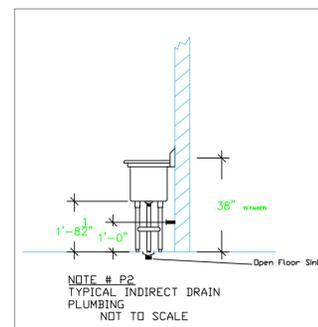

LEGEND -- PLUMBING CONNECTIONS

- HW-HOT WATER, OR CW-COLD WATER
- GAS
- WASTE, DIRECT-CONNECTED
- WASTE, INDIRECT to Floor Sink, or Floor Dr
- FLOOR DRAIN Josam 30000-E3
- FLOOR DRAIN Josam 30000-A3
- FLOOR SINK Proflo PF42856 or similar
- FILTERED WATER, at machine.

NOTE # P4
ALL NATIONAL, STATE, AND LOCAL CODES SHALL APPLY


NOTE # P5
ALL PLUMBING CONNECTIONS TO BE EXTENDED AND INTERCONNECTED TO EQUIPMENT AND ALL HARDWARE REQUIRED TO BE PROVIDED BY PLUMBING CONTRACTOR

NOTE # P6
PLUMBING CONTRACTOR TO VERIFY THAT ALL EQUIPMENT IS INSTALLED WITH THE APPROPRIATE GAS PRESSURE AND REGULATORS

NOTE # P7
ALL WASTE LINES AND CONDENSATE LINES TO BE EXTEND FROM EQUIPMENT TO FLOOR DRAINS BY PLUMBING CONTRACTOR.


Equipment PLUMBING Service Requirements

All Dimensions to be verified on the job site. Actual locations for floor drains, and any ventilating equipment to be determined by Engineer. Mechanical, Plumbing & Electrical to be checked and verified by Customers MEP Engineer. Remote Condensing Units to be located by Architect. Exhaust & Supply fans to be located by Architect.

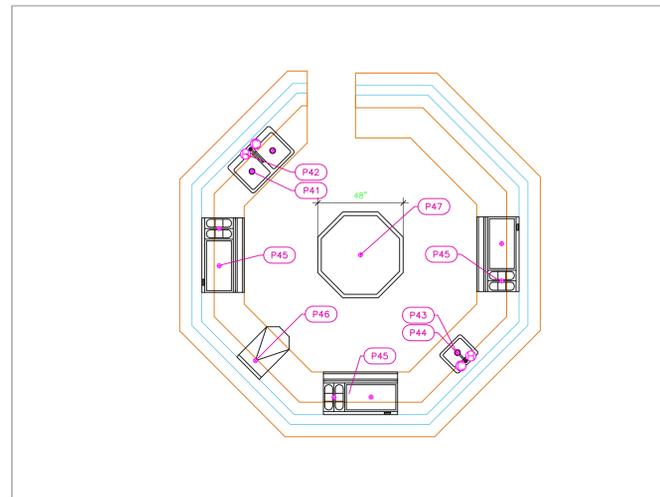


Reef Runner Bar

PLUMBING SCHEDULE											
ITEM NO.	DESCRIPTION	COLD WATER SIZE	HOT WATER SIZE	H&C Rough-In	DIRECT WASTE SIZE	DIRECT WASTE AFF.	INDIRECT WASTE SIZE	GAS SIZE (IN)	GAS MBTU	QTY	PLUMBING REMARKS
41	Drop-In Sink						(2) 1-1/2"			1	Waste to Floor Sink
42	Deck Mount Faucet	1/2"	1/2"	12"						1	
43	Drop-In Sink						1-1/2"			1	Waste to Floor Sink
44	Deck Mount Faucet	1/2"	1/2"	12"						1	
45	Ice Bin with Bottle Wells						1"			3	Waste to Floor Sink
							1"			3	Waste to Floor Sink
47	Ice Bin / Ice Caddy, Mobile						1"			1	Waste to Floor Sink

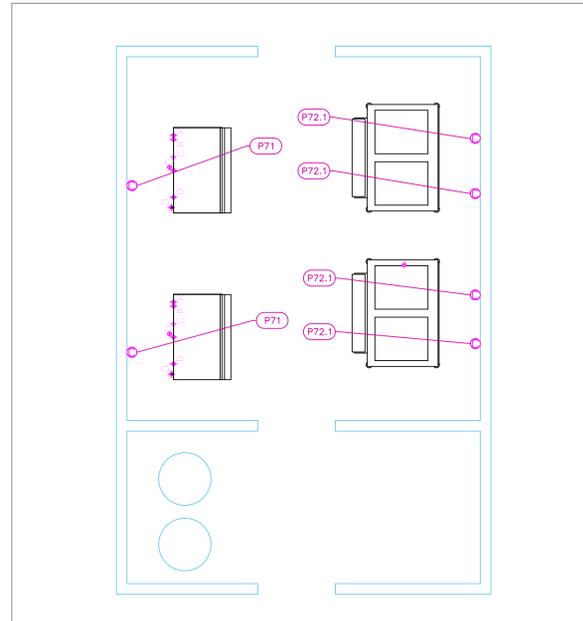


North Ice Room

PLUMBING SCHEDULE											
ITEM NO.	DESCRIPTION	COLD WATER SIZE	HOT WATER SIZE	H&C Rough-In	DIRECT WASTE SIZE	DIRECT WASTE AFF.	INDIRECT WASTE SIZE	GAS SIZE (IN)	GAS MBTU	QTY	PLUMBING REMARKS
71	Ice Maker, Cube-Style	1/2"		36"			3/4"			2	Waste to Floor Sink
	Ice Bin for Ice Machines						3/4"			2	Waste to Floor Sink
72	Ice Bin Shuttle System						1-1/4"			2	Waste to Floor Sink
72.1	Ice Maker, Cube-Style	3/8"		36"			1/2"			4	Waste to Floor Sink



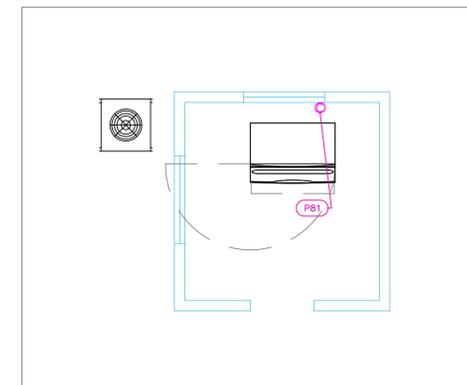


Hummingbird

PLUMBING SCHEDULE											
ITEM NO.	DESCRIPTION	COLD WATER SIZE	HOT WATER SIZE	H&C Rough-In	DIRECT WASTE SIZE	DIRECT WASTE AFF.	INDIRECT WASTE SIZE	GAS SIZE (IN)	GAS MBTU	QTY	PLUMBING REMARKS
81	Ice Maker, Cube-Style	3/8"		36"			1/2"			1	Waste to Floor Sink
	Ice Bin for Ice Machines						3/4"			1	Waste to Floor Sink

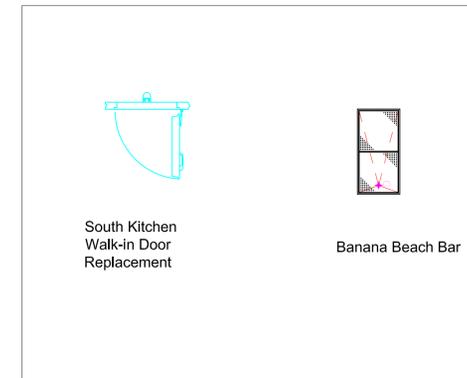

Miscellaneous

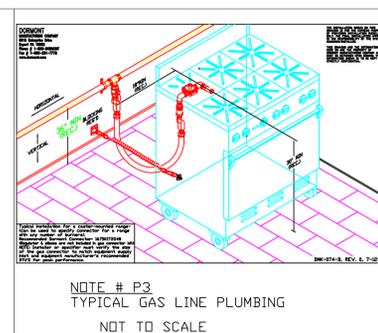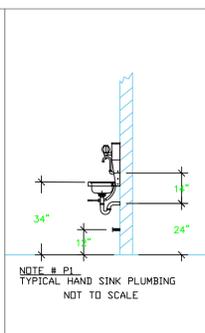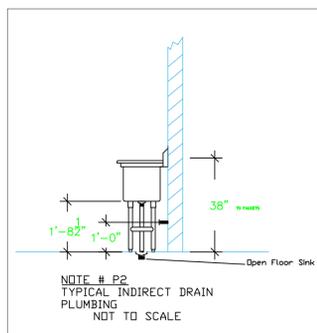

LEGEND -- PLUMBING CONNECTIONS

- HW-HOT WATER, OR CW-COLD WATER
- GAS
- WASTE, DIRECT-CONNECTED
- WASTE, INDIRECT to Floor Sink, or Floor Drain
- FLOOR DRAIN Josam 30000-E3
- FLOOR DRAIN Josam 30000-A3
- FLOOR SINK Proflo PF42856 or similar
- FILTERED WATER, at machine.

NOTE # P4
ALL NATIONAL, STATE, AND LOCAL CODES SHALL APPLY

NOTE # P5
ALL PLUMBING CONNECTIONS TO BE EXTENDED AND INTERCONNECTED TO EQUIPMENT AND ALL HARDWARE REQUIRED TO BE PROVIDED BY PLUMBING CONTRACTOR

NOTE # P6
PLUMBING CONTRACTOR TO VERIFY THAT ALL EQUIPMENT IS INSTALLED WITH THE APPROPRIATE GAS PRESSURE AND REGULATORS

NOTE # P7
ALL WASTE LINES AND CONDENSATE LINES TO BE EXTEND FROM EQUIPMENT TO FLOOR DRAINS BY PLUMBING CONTRACTOR.

Equipment PLUMBING Service Requirements

All Dimensions to be verified on the job site. Actual locations for floor drains, and any ventilating equipment to be determined by Engineer. Mechanical, Plumbing & Electrical to be checked and verified by Customers MEP Engineer. Remote Condensing Units to be located by Architect. Exhaust & Supply fans to be located by Architect.

Carnival Cruise Lines
Princess Cays
Eleuthera, Bahamas

INTERNATIONAL INC.
2055 W 73rd Street, Miami, FL 33016
Ph:(305)826-8696 Fax:(305)826-9131

No.	Revision/Issue	Date
1	Preliminary Layout	11-15-23
2	Updated dishroom back to old flight machine	1-26-24
3	Update after site visit Sept 2024	9-17-24
4	Added Ref to 4 corners of pavilion & Added EP	9-30-24

Date
Sept 30, 2024
Drawn By
Dayne Gauntlett
Scale
1/4" = 1'0"

Sheet
FS-4.3