


ITEM NO.	DESCRIPTION	COLD WATER SIZE	HOT WATER SIZE	H&C Rough-In	PLUMBING SCHEDULE			GAS SIZE(IN)	GAS MBTU	QTY	PLUMBING REMARKS	Unit
					DIRECT WASTE SIZE	DIRECT WASTE AFF.	INDIRECT WASTE SIZE					
401	Ice Bin						1-1/2"		1		Waste to Floor Sink	ea
402	Underbar Mixology Sink Unit	3/8"		12"			1-1/2"		1		Glass rinser, Sink waste	ea
407	Hand Sink	3/8"	3/8"	12"	1-1/2"	24"			1			ea
411	Shake Machine								1		Water Cooled, Plumber to Connect to 411.1 Chiller	ea
411.1	Cooling Tower								1		Plumber to connect to 411 (3/8" NPT)	ea
412	Drainboard						1/2"		1		Waste to Floor Sink	ea
N413	Corner Angle Filler						1/2"		1		Waste to Floor Sink	ea
N414	Corner Angle Filler						1/2"		1		Waste to Floor Sink	ea
N415	Ice Bin						3/4"		1		Waste to Floor Sink	ea
N416	Underbar Mixology Sink Unit	3/8"	3/8"	12"			1-1/2"		1		Glass rinser, Sink waste	ea
N420	Draft Beer Cooler								1		Waste to Floor Sink	ea
N421	Draft Beer / Wine Dispensing Tower						1/2"		1		Waste to Floor Sink	ea
N421.1	Dishable, Soiled "L" Shaped						1-1/2"		1		Waste to Floor Sink	ea
421.1	Pre-Rinse Faucet Assembly	1/2"	1/2"	12"					1		Waste to Floor Sink	ea
N423	Dishwasher, Door Type, Ventless	3/4"		12"			1-1/2"		1		Waste to Floor Sink	ea
432	Gas Floor Fryer							3/4"	105.0	1	See Note P3	ea
N432	Gas Floor Fryer							3/4"	105.0	1	See Note P3	ea
433	Griddle, Gas, Countertop							3/4"	56.6	1	See Note P3	ea
433.1	Salamander Broiler, Gas							3/4"	25.0	1	See Note P3	ea
434	Hotplate, Countertop, Gas							3/4"	100	1	See Note P3	ea
435	Charbroiler, Gas, Countertop							3/4"	80.0	1	See Note P3	ea
N440	Dishable, with Potsinks						1-1/2"		1		Waste to Floor Sink	ea
440.1	Wall / Splash Mount Faucet	1/2"	1/2"	12"					1		Waste to Floor Sink	ea
N447	Work Table, with Prep Sink(s)						1-1/2"		1		Waste to Floor Sink	ea
447.1	Deck Mount Faucet	1/2"	1/2"	12"					1		Installed by Plumber	ea
448	Grease Interceptor								1		Installed by Plumber	ea
449	Grease Interceptor								1		Installed by Plumber	ea

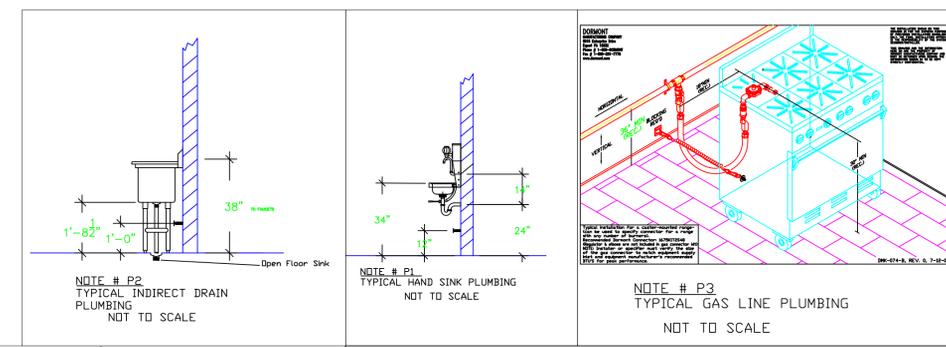

- LEGEND — PLUMBING CONNECTIONS**
- HW-HOT WATER, OR CW-COLD WATER
 - GAS
 - WASTE, DIRECT-CONNECTED
 - WASTE, INDIRECT to Floor Sink, or Floor Dr
 - ⊕ FUNNEL FLOOR DRAIN Josam 30000-E3
 - ⊙ FLOOR DRAIN Josam 30000-A3
 - ⊠ FLOOR SINK Zurn FD-2370-y-PV4-F
 - ⊙ FILTERED WATER, at machine.
 - ⊕ CHILL WATER SUPPLY & RETURN
- NOTE # P4.**
ALL NATIONAL, STATE, AND LOCAL CODES SHALL APPLY
- NOTE # P5.**
ALL PLUMBING CONNECTIONS TO BE EXTENDED AND INTERCONNECTED TO EQUIPMENT AND ALL HARDWARE REQUIRED TO BE PROVIDED BY PLUMBING CONTRACTOR
- NOTE # P6.**
PLUMBING CONTRACTOR TO VERIFY THAT ALL EQUIPMENT IS INSTALLED WITH THE APPROPRIATE GAS PRESSURE AND REGULATORS
- NOTE # P7.**
ALL WASTE LINES AND CONDENSATE LINES TO BE EXTEND FROM EQUIPMENT TO FLOOR DRAINS BY PLUMBING CONTRACTOR.

Equipment PLUMBING Service Requirements

Actual Dimensions to be verified on the job site. Actual locations for floor drains, and any ventilating equipment to be determined by Engineer. Mechanical, Plumbing & Electrical to be checked and verified by Customers MEP Engineer. Remote Condensing Units to be located by Architect. Exhaust & Supply fans to be located by Architect.

A N d A Z
Beach Bar & Restaurant
Providenciales T&C

uni-source SUPPLY
INTERNATIONAL INC.
2055 W 73rd Street, Miami, FL 33016
Ph:(305)826-8696 Fax:(305)826-9131

No.	Revision/Issue	Date
11	Moved wall & adj. items after review from Maximo	2-24-25
12	Minor adjustments, added elevations.	2-26-25
13	Minor adjustments from Maximo.	2-28-25
14	Added MEP Equipment Requirements	3-27-25

Date
March 27, 2025
Drawn By
Dayne Gauntlett
Scale
3/8" = 1'0"

Sheet
BB-4.1