

EQUIPMENT SCHEDULE					
ItemNo	Category	Mfr	Model	Quantity	Equipment Remarks
1	Reach-In Refrigerator	Turbo Air	M3R24-2-N(-L)	1	Existing
2	Ice Bin for Ice Machines	Manitowoc	D570	1	Existing
2.1	Ice Maker, Cube-Style	Manitowoc	QD0802A	1	Existing
3	Spare Number				
4	Hand Sink	AERO	HSEF	1	Existing
5	Work Table, Stainless Steel Top	Advance Tabco	KMS-305	2	Existing
6	Sandwich / Salad Preparation Refrigerator	Continental Refrigerator	SW60N16	1	Existing
7	Hot Food Serving Counter / Table	Advance Tabco	SW-3E-120	1	Existing
8	Reach-In Undercounter Freezer	Defield	407P-ES	1	Existing
9	Sandwich / Salad Preparation Refrigerator	True Mfg. - General Foodservice	TSSU-48-12-HC	1	Existing
10	Three (3) Compartment Sink	Advance Tabco	FC-3-1515-15L	1	Existing
10.1	Wall / Splash Mount Faucet	Krowne	14-810L	1	Existing
11	Charbroiler, Gas, Countertop	Southbend	HDC-48	1	Existing
12	Griddle, Gas, Countertop	Southbend	HDC-36	1	Existing
13	Hotplate, Countertop, Gas	Southbend	HDO-36	1	Existing
14	Gas Floor Fryer	ANETS	14GS	2	Existing
15	Pizza Bake Oven, Countertop, Gas	Bakers Pride	GP52	2	Existing
16	Back Bar Cabinet, Refrigerated	Glastender	C1FL60	1	Existing
17	Soda Beverage Post / Pre Mix Drink Dispenser	Lancer	85-9946S-2011M	1	Existing
18	Chest Freezer	Atosa USA, Inc.	MMF9110	1	Existing
19	Pass-Thru Shelf	Custom Fab	PA-18-144-2	1	Existing
19.1	Heat Lamp	Nemco	6151-36	2	Existing
20	Cold Food Well Unit, Drop-In, Refrigerated	Atlas Metal	WCM-BT-3	1	Existing
21	Ice Bin for Ice Machines	Manitowoc	D970	1	Existing
21.1	Ice Maker, Cube-Style	Manitowoc	IDT0900A	1	Existing
23	Worktable with Sink	Custom Fab	TABLE	1	Existing
	Sink	Custom Fab	TA-11J	1	Existing
23.1	Deck Mount Faucet	Krowne	15-810L	1	Existing
24	Cabinet, Cook / Hold / Oven	Alto-Shaam	500-TH	1	Existing
25	Chef Base	True Mfg. - General Foodservice	TRCB-52-60	1	Existing
26	Equipment Stand, Refrigerated Base	Truelsen	TE060HR	1	Existing
27	Salamander Broiler, Gas	Wolf	C36IRB	1	Existing
99	Floor Sink	Zurn	FD-2370-Y-PV4-F	1	Existing

EQUIPMENT LAYOUT

All Dimensions to be verified on the job site. Actual locations for floor drains, and any ventilating equipment to be determined by Engineer. Mechanical, Plumbing & Electrical to be checked and verified by Customers MEP Engineer. Remote Condensing Units to be located by Architect. Exhaust & Supply fans to be located by Architect.

Coral Reef Yacht Club
Angler's Reef Grill
Miami, Florida




INTERNATIONAL INC.

2055 W 73rd Street, Miami, FL 33016
Ph: (305)826-8696 Fax: (305)826-9131

No.	Revision/Issue	Date
2	Update from meeting with operations.	7-15-21
3	Updated Background from Architect	9-2-21
4	Changed #16, #8, #6	9-10-21
5	Added MEP information	9-15-21

Date
Sept 15, 2021
Drawn By
Dayne Gauntlett
Scale
1/2" = 1'0"

Sheet
FS-1.0

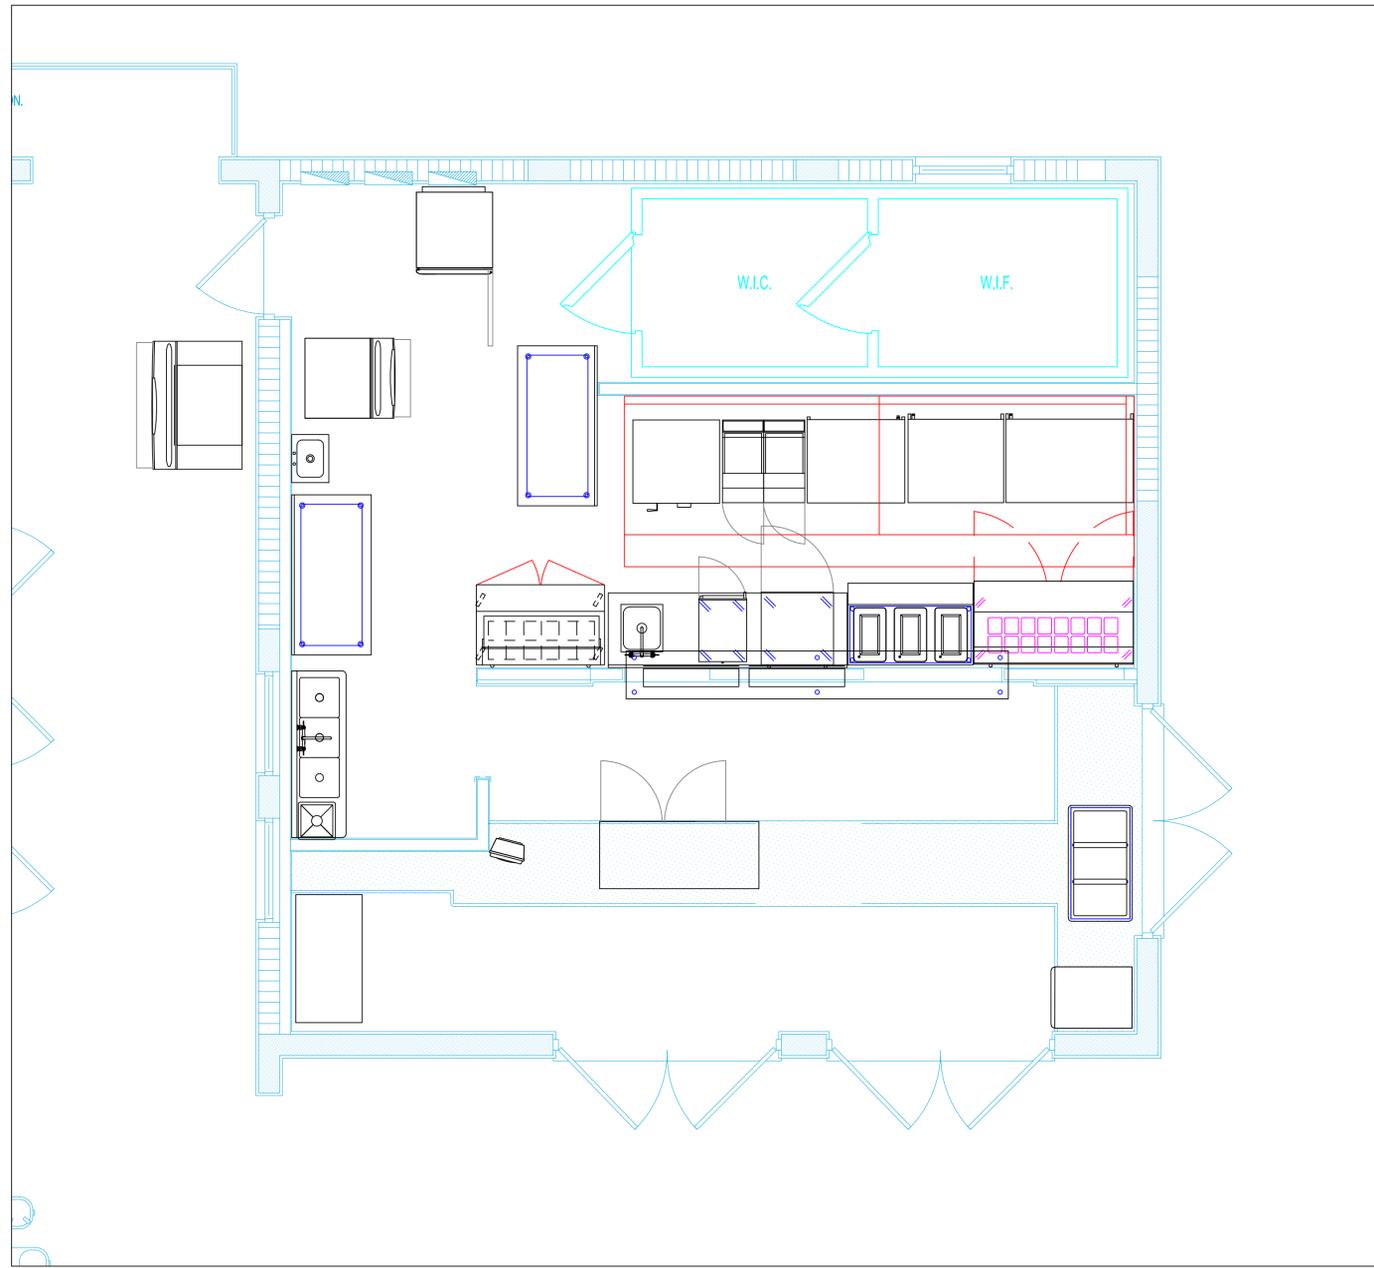

LEGEND — MECHANICAL

- EXHAUST DUCT COLLAR
- SUPPLY DUCT COLLAR
- INWALL BACKING FOR WALL SHELVES
- RECESSED FLOOR
- RAISED EQUIPMENT PAD

NOTE # M5
 ALL NATIONAL, STATE, AND LOCAL CODES SHALL APPLY.

NOTE # M6
 ARCHITECT OR ENGINEER TO SIZE AND LOCATE, CONTRACTOR TO PROVIDE ALL OPENINGS FOR DUCTS, PLUMBING LINES, ELECTRICAL LINES, AND REFRIGERATION LINES, AS REQUIRED BY EQUIPMENT.

NOTE # M7
 SUPPLY FANS TO BE LOCATED A MINIMUM OF 10' FROM EXHAUST FANS.

NOTE # M8
 SHOP DRAWING WILL BE PROVIDED BY MANUFACTURER FOR HOOD, EXHAUST FANS, & SUPPLY FANS, ONCE ORDER IS PLACE WITH.

NOTE # M9
 GENERAL CONTRACTOR TO PROVIDE 1/2" PLYWOOD WALL BACKING FROM 48" TO 78" AFF FOR ALL WALL MOUNTED EQUIPMENT.

NOTE # M10
 CEILING HEIGHTS TO BE VERIFIED FOR SUFFICIENT CLARENCE FOR EQUIPMENT.

NOTE # M11
 REFRIGERATION CONTRACTOR TO HANG EVAPORATORS FOR WALK-IN, RUN & CHARGE LINES BETWEEN EVAP. & CONDENSING UNIT.

Equipment MECHANICAL Service Requirements

All Dimensions to be verified on the job site. Actual locations for floor drains, and any ventilating equipment to be determined by Engineer. Mechanical, Plumbing & Electrical to be checked and verified by Customers MEP Engineer. Remote Condensing Units to be located by Architect. Exhaust & Supply Fans to be located by Architect.


Coral Reef Yacht Club
Angler's Reef Grill
 Miami, Florida

INTERNATIONAL INC.
 2055 W 73rd Street, Miami, FL 33016
 Ph:(305)826-8696 Fax:(305)826-9131

2	Update from meeting with operations.	7-15-21
3	Updated Background from Architect	9-2-21
4	Changed #16, #8, #6	9-10-21
5	Added MEP information	9-15-21
No.	Revision/Issue	Date

Date
Sept 15, 2021
 Drawn By
Dayne Gauntlett
 Scale
1/2" = 1'0"


Sheet
FS-2.0

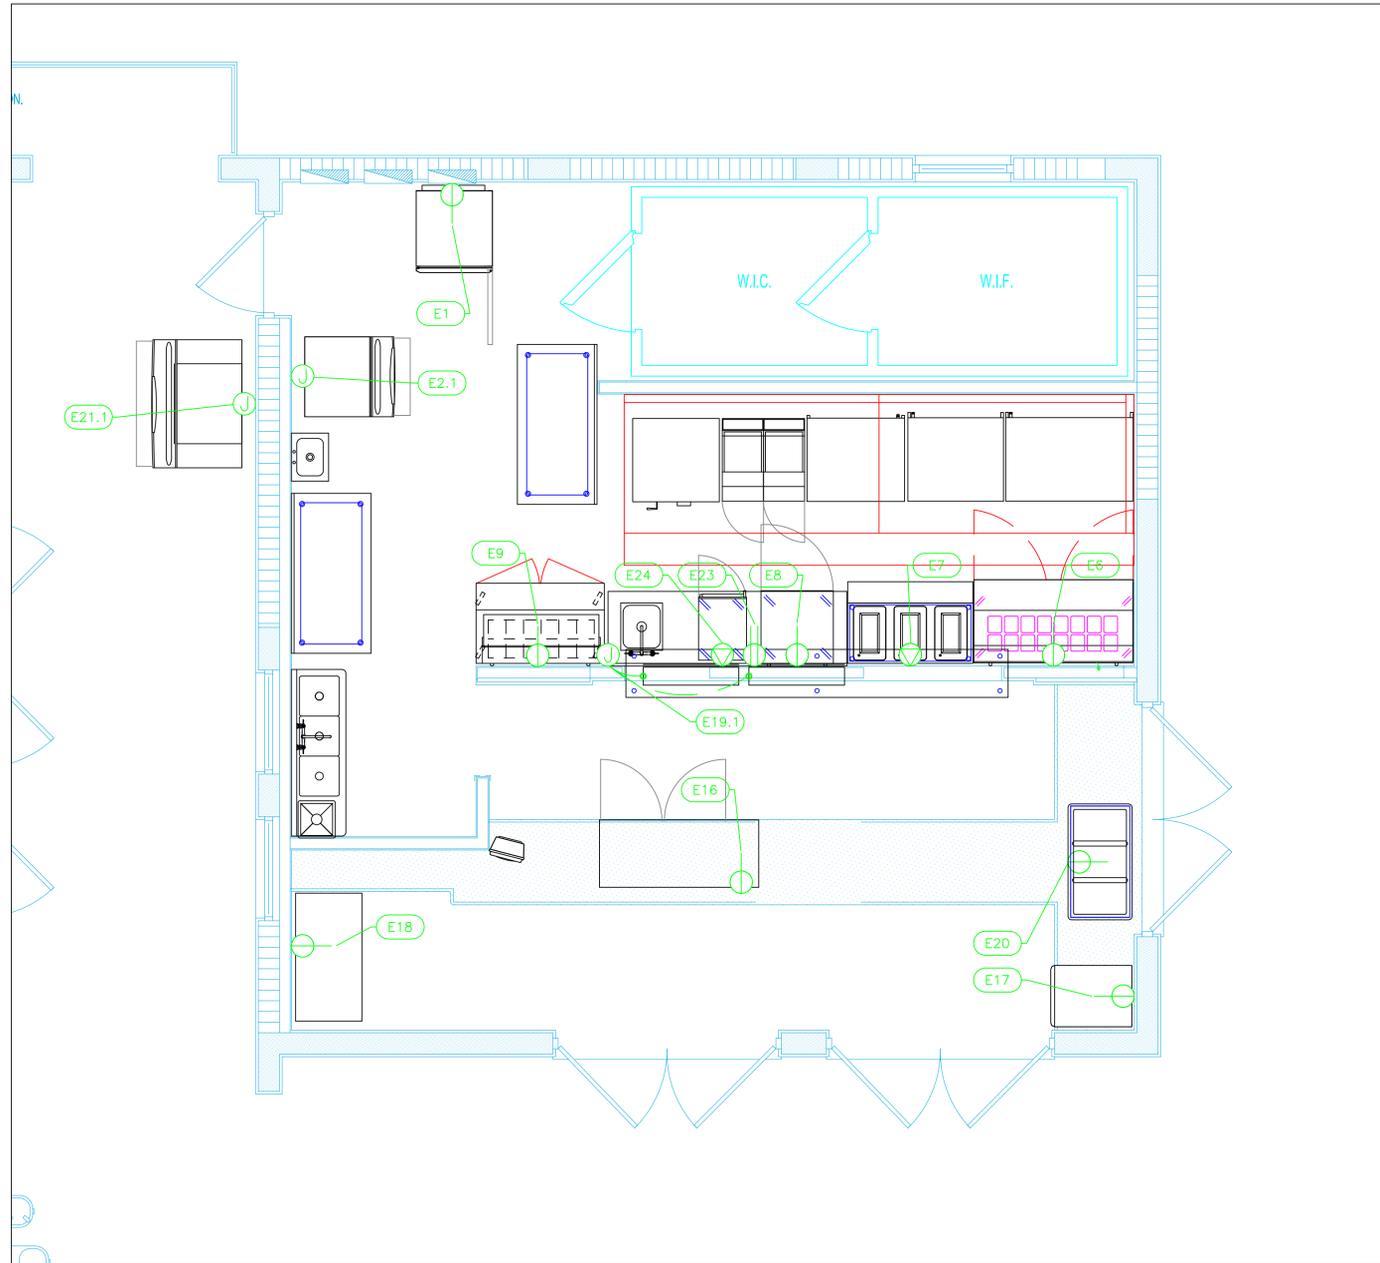

ELECTRICAL SCHEDULE											
ItemNo	Category	Voltage	Cycle	Phase	Amps	Hp	NEMA	ConnectionType	Rough-In AFF	Quantity	Electrical Remarks
1	Reach-In Refrigerator	115	60	1	2.5	1/4	5-15P	Simplex	12"	1	Existing
2.1	Ice Maker, Cube-Style	208	60	1	9.5			J-Box	48"	1	Existing
6	Sandwich / Salad Preparation Refrigerator	115	60	1	5.8	1/3	5-15P	Simplex	12"	1	
7	Hot Food Serving Counter / Table	120	60	1	16		5-20P	Special	12"	1	Existing
8	Reach-In Undercounter Freezer	115	60	1	4.5	1/5	5-15P	Simplex	12"	1	
9	Sandwich / Salad Preparation Refrigerator	115	60	1	5.8	1/3	5-15P	Simplex	12"	1	Existing
16	Back Bar Cabinet, Refrigerated	120	60	1	7	1/4	5-15P	Simplex	12"	1	
17	Soda Beverage Post / Pre Mix Drink Dispenser	120	60	1	15	1/3		Simplex	12"	1	Confirm Electrical with Vendor
18	Chest Freezer	115	60	1	1.6		5-15P	Simplex	12"	1	Existing, new Location
19.1	Heat Lamp	120	60	1	7.1			J-Box	62"	2	
20	Cold Food Well Unit, Drop-In, Refrigerated	120	60	1	6.8	1/4	5-15P	Simplex	12"	1	
21.1	Ice Maker, Cube-Style	208	60	1	9.5			J-Box		1	Existing
23	Worktable with Sink	115	60	1	15			Duplex	48"	1	See Note E1
24	Cabinet, Cook / Hold / Oven	120	60	1	16.0		5-20P	Special	12"	1	
25	Chef Base	115	60	1	8.1	1/3	5-15P	Simplex	12"	1	Existing
26	Equipment Stand, Refrigerated Base	115	60	1	5.4			Simplex	12"	1	Existing

LEGEND - ELECTRICAL CONNECTIONS

- DUPLEX RECEPT., 15-AMP, 120-VOLT, GROUND TYPE, HORIZONTAL MOUNT
- SIMPLEX RECEPT., 120-VOLT, GROUND TYPE, HORIZONTAL MOUNT
- SPECIAL PURPOSE OUTLET, GROUND TYPE, HORIZONTAL MOUNT
- JUNCTION BOX, DIRECT CONNECTION
- DISCONNECT SWITCH, DIRECT CONNECTION
- FLOOR/CEILING RECEPTACLE AS INDICATED
- (2) Telephone + (2) Data
- FIELD CONNECTIONS
- HARD WIRE CONNECTION POINT AT MACHINE

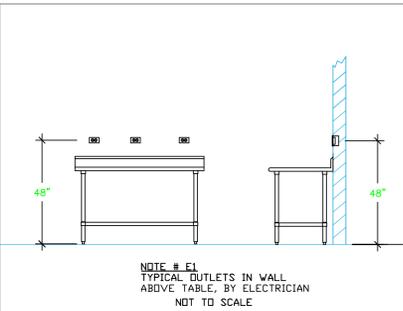

NOTE # E2
ALL NATIONAL, STATE, AND LOCAL CODES SHALL APPLY

NOTE # E3
ALL ELECTRICAL CONNECTIONS AND HARDWARE REQUIRED TO BE PROVIDED BY ELECTRICAL CONTRACTOR

NOTE # E4
ALL JUNCTION BOXES, OUTLETS, ETC. TO BE LOCATED SO AS TO NOT INTERFERE WITH EQUIPMENT

NOTE # E5
ALL RELAYS, CONTRACTORS, STARTERS, AND SWITCHES REQUIRED FOR EXHAUST & SUPPLY FANS TO BE PROVIDED BY ELECTRICAL CONTRACTOR UNLESS SPECIFIED

NOTE # E6
ELECTRICAL CONTRACTOR TO INTERCONNECT DISHMACHINE TO EXHAUST FAN FOR DISHMACHINE SO THAT THE FAN RUNS WHEN THE DISHMACHINE IS IN OPERATION.

NOTE # E7
ELECTRICAL CONTRACTOR TO INSTALL TABLE LIMIT SWITCH TO END OF CLEAN DISHTABLE TO THAT MACHINE STOPS WHEN SWITCH IS DEPRESSED.

NOTE # E8
ELECTRICAL CONTRACTOR TO CONNECT DRAIN LINE HEATER, PAN HEATER AND DODR HEATER FOR WALK-IN FREEZER.

Equipment ELECTRICAL Service Requirements

All Dimensions to be verified on the job site. Actual locations for floor drains, and any ventilating equipment to be determined by Engineer. Mechanical, Plumbing & Electrical to be checked and verified by Customers MEP Engineer. Remote Condensing Units to be located by Architect. Exhaust & Supply fans to be located by Architect.

Coral Reef Yacht Club
Angler's Reef Grill
Miami, Florida



uni-source
SUPPLY


INTERNATIONAL INC.

2055 W 73rd Street, Miami, FL 33016
Ph: (305) 826-8696 Fax: (305) 826-9131

2	Update from meeting with operations.	7-15-21
3	Updated Background from Architect	9-2-21
4	Changed #16, #8, #6	9-10-21
5	Added MEP information	9-15-21
No.	Revision/Issue	Date

Date
Sept 15, 2021
Drawn By
Dayne Gauntlett
Scale
1/2" = 1'0"




Sheet
FS-3.0

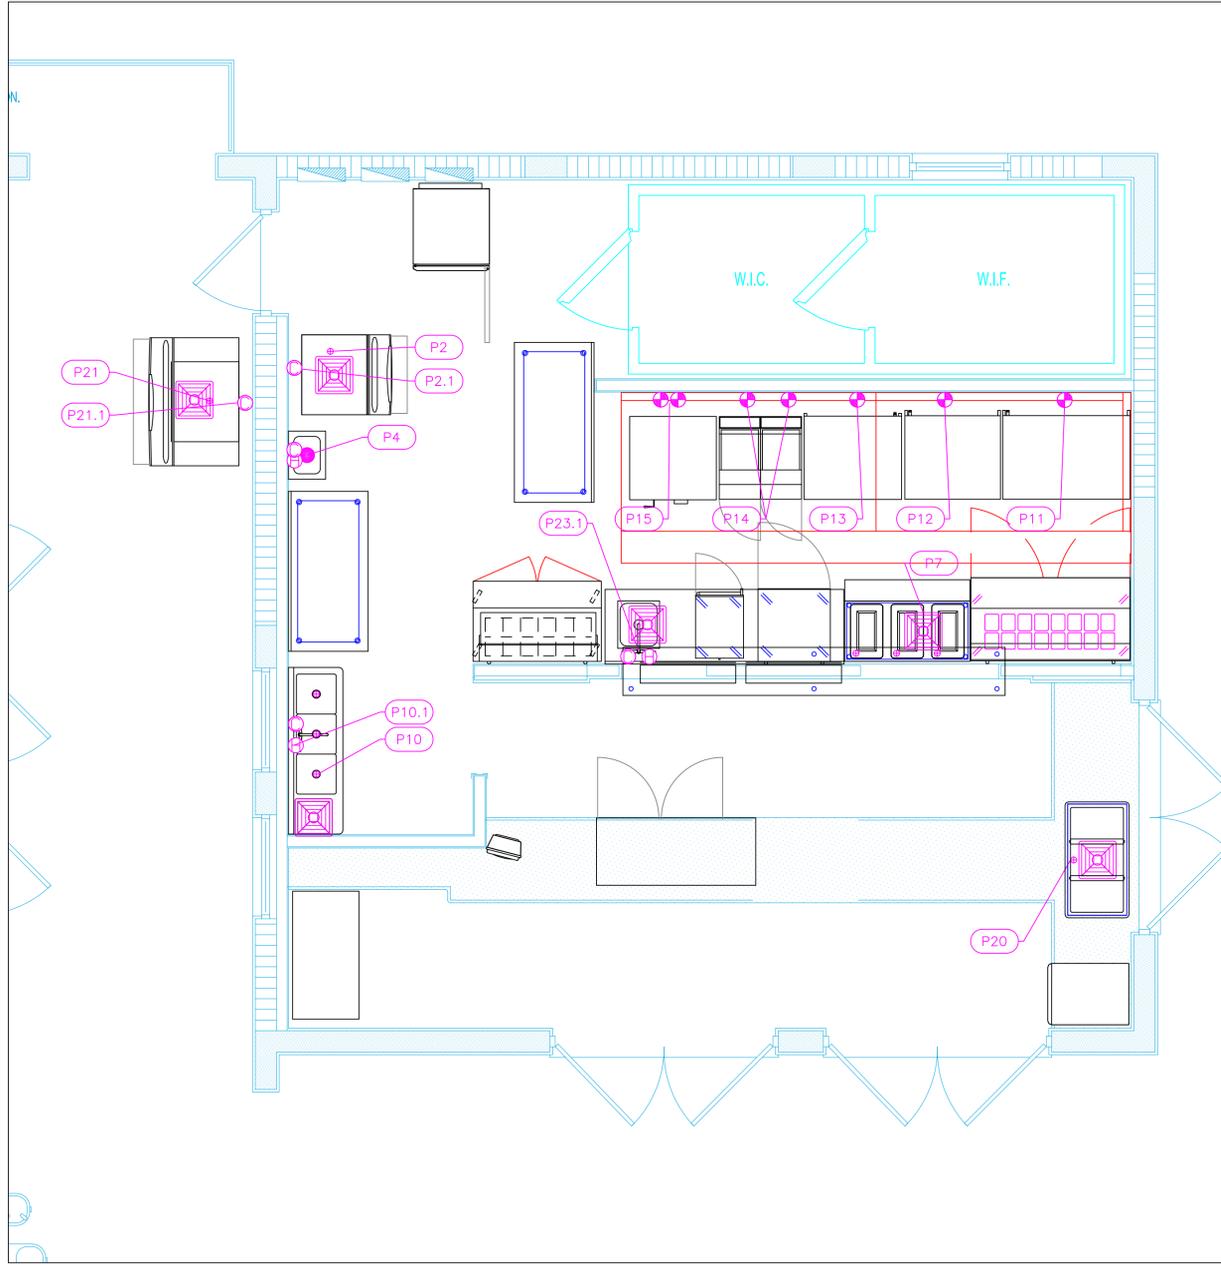

LEGEND - PLUMBING CONNECTIONS

- HW-HOT WATER, OR CW-COLD WATER
- GAS
- WASTE, DIRECT-CONNECTED
- WASTE, INDIRECT to Floor Sink
- ⊕ WASTE, INDIRECT to Funnel Floor Drain Jock
- ⊕ FLOOR DRAIN Josam 30000-A3
- ⊕ WASTE, INDIRECT to Floor Sink Zurn FD-23
- FILTERED WATER, at machine.

PLUMBING SCHEDULE											
ITEM NO.	DESCRIPTION	COLD WATER SIZE	HOT WATER SIZE	H&C Rough-In	DIRECT WASTE SIZE	DIRECT WASTE AFF	INDIRECT WASTE SIZE	GAS SIZE(IN)	GAS MBTU	QTY	PLUMBING REMARKS
2	Ice Bin for Ice Machines						3/4"			1	Waste to Floor Sink
2.1	Ice Maker, Cube-Style			48"			1/2"			1	Waste to Floor Sink
4	Hand Sink	3/8"		48"			1/2"			1	Existing
7	Hot Food Serving Counter / Table	1/2"	1/2"	12"	1-1/2"	24"	(3) 1"			1	Waste to Floor Sink
10	Three (3) Compartment Sink						(3) 1-1/2"			1	Waste to Floor Sink
10.1	Wall / Splash Mount Faucet	1/2"	1/2"	12"						1	
11	Charbroiler, Gas, Countertop							3/4"	160.0	1	Existing
12	Griddle, Gas, Countertop							3/4"	90.0	1	Existing
13	Hotplate, Countertop, Gas							3/4"	198.0	1	Existing
14	Gas Floor Fryer							3/4"	111.0	2	Existing
15	Pizza Bake Oven, Countertop, Gas							3/4"	40.0	2	Existing
								3/4"	40.0	2	Existing
17	Soda Beverage Post / Pre Mix Drink Dispenser									1	Confirm with Vendor
20	Cold Food Well Unit, Drop-In, Refrigerated						3/4"			1	Waste to Floor Sink
21	Ice Bin for Ice Machines						3/4"			1	Waste to Floor Sink
21.1	Ice Maker, Cube-Style	3/8"					1/2"			1	Waste to Floor Sink
23	Worktable with Sink									1	
	Sink						1-1/2"			1	Waste to Floor Sink
23.1	Deck Mount Faucet	1/2"	1/2"	12"						1	
27	Salamander Broiler, Gas							3/4"	30.0	1	Existing
99	Floor Sink				4"	Floor				1	Existing

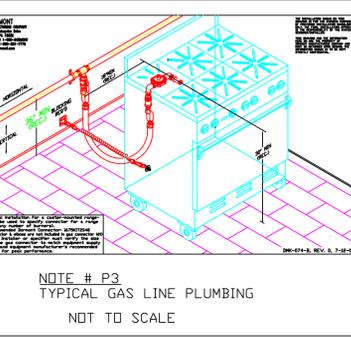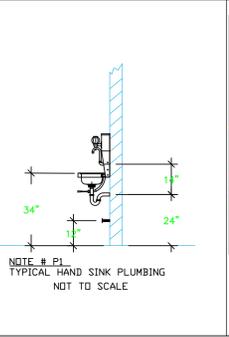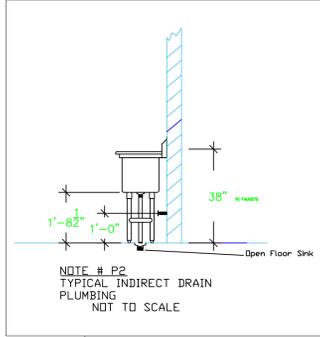

NOTE # P4.
ALL NATIONAL, STATE, AND LOCAL CODES SHALL APPLY

NOTE # P5.
ALL PLUMBING CONNECTIONS TO BE EXTENDED AND INTERCONNECTED TO EQUIPMENT AND ALL HARDWARE REQUIRED TO BE PROVIDED BY PLUMBING CONTRACTOR

NOTE # P6.
PLUMBING CONTRACTOR TO VERIFY THAT ALL EQUIPMENT IS INSTALLED WITH THE APPROPRIATE GAS PRESSURE AND REGULATORS

NOTE # P7.
ALL WASTE LINES AND CONDENSATE LINES TO BE EXTEND FROM EQUIPMENT TO FLOOR DRAINS BY PLUMBING CONTRACTOR.

Equipment PLUMBING Service Requirements

All Dimensions to be verified on the job site. Actual locations for floor drains, and any ventilating equipment to be determined by Engineer. Mechanical, Plumbing & Electrical to be checked and verified by Customers MEP Engineer. Remote Condensing Units to be located by Architect. Exhaust & Supply fans to be located by Architect.

Coral Reef Yacht Club
Angler's Reef Grill
Miami, Florida



INTERNATIONAL INC.
2055 W 73rd Street, Miami, FL 33016
Ph:(305)826-8696 Fax:(305)826-9131

2	Update from meeting with operations.	7-15-21
3	Updated Background from Architect	9-2-21
4	Changed #16, #8, #6	9-10-21
5	Added MEP information	9-15-21
No.	Revision/Issue	Date

Date
Sept 15, 2021
Drawn By
Dayne Gauntlett
Scale
1/4" = 1'0"

Sheet
FS-4.0