


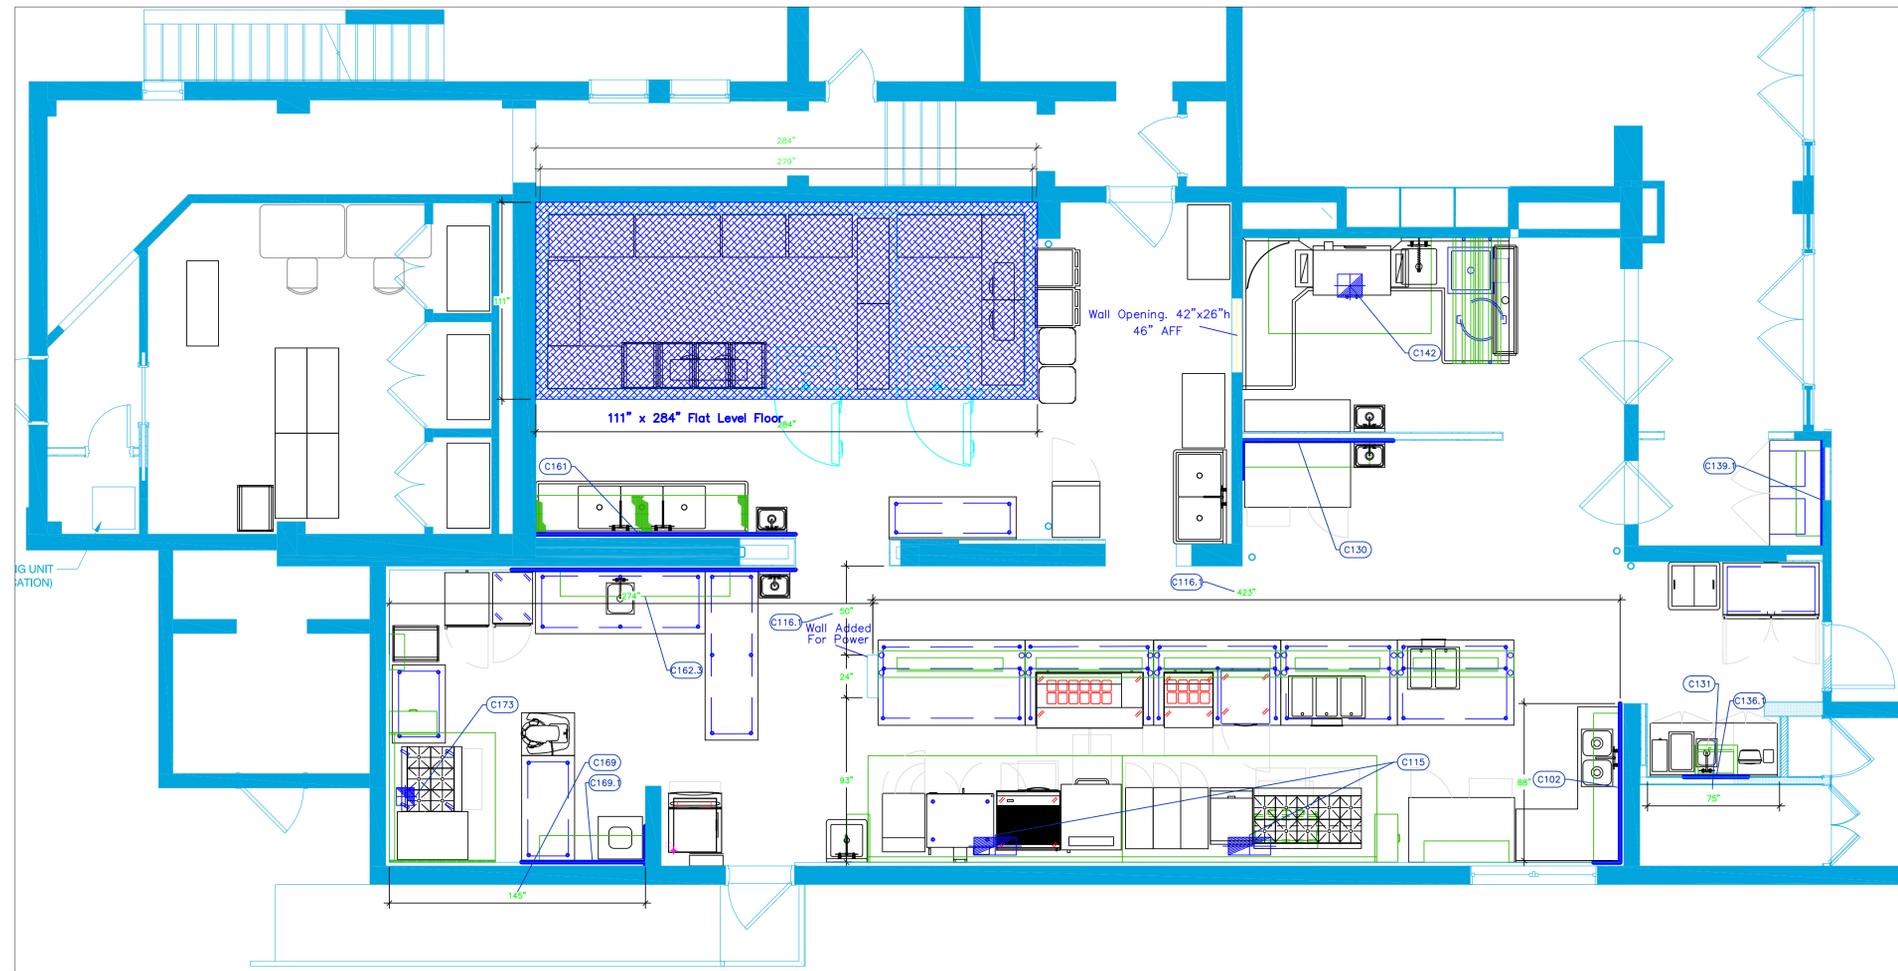

3	Updated Hood Shops with DBAS Supply	9-20-23
4	Update after meeting with Operations.	10-26-23
5	Update after meeting with Operations, and Design Team	11-1-23
6	PERMIT / BID	12-15-23
No.	Revision/Issue	Date

Date
Dec 15, 2023
 Drawn By
Dayne Gauntlett
 Scale
1/4" = 1'0"


Sheet
FS-2.1



LEGEND – MECHANICAL

- EXHAUST DUCT COLLAR
- SUPPLY DUCT COLLAR
- INWALL BACKING FOR WALL SHELVES
- RECESSED FLOOR
- RAISED EQUIPMENT PAD

Mechanical Schedule								
ITEM NO.	QTY	DISCRIPTION	EXHAUST (L X W)	EXHAUST (CFM)	Makeup Vent Width	SUPPLY (CFM)	Ventilation Remarks	Unit
101.1	1	Wall / Splash Mount Faucet					Wall Backing, See Note M9	ea
115	1	Main Hood	(2) 10"x24"				Critical Hold To Dimension	ea
115.1	2	Exhaust Fan	26"x26"	2520			Dim is Roof Opening	ea
115.2	1	Supply Fan DOAS				5789	See Shops for Roof Opening Info	ea
116.1	1	Chef's Table E					Critical Hold To Dimension	ea
118	4	Hand Sink					Wall Backing, See Note M9	ea
121.1	1	Water Filtration System, Parts & Accessories					Wall Backing, See Note M9	ea
131	1	Work Table, Stainless Steel Top					Critical Hold To Dimension	ea
136.1	1	Microwave Oven, Shelf					Wall Backing, See Note M9	ea
142	1	Exhaust Hood	13"x14"				Extend wall as shown	ea
142.1	1	Exhaust Fan	19"x19"	1533			Dim is Roof Opening	ea
161	2	Shelving, Wall Mounted					Wall Backing, See Note M9	ea
162.3	1	Shelving, Wall Mounted					Wall Backing, See Note M9	ea
169	1	Work Table, Stainless Steel Top					Critical Hold To Dimension	ea
173	1	Hood - Prep	10"x10"				Dim is Roof Opening	ea
173.1	1	Exhaust Fan	22.5"x22.5"	1050			Dim is Roof Opening	ea

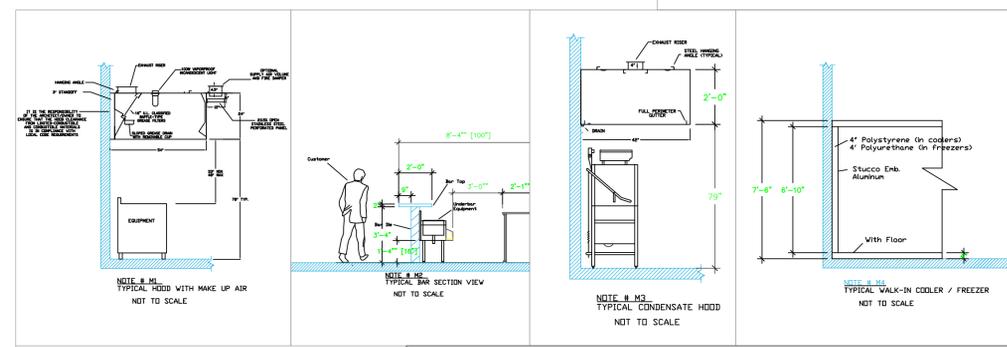

NOTE # M5
 ALL NATIONAL, STATE, AND LOCAL CODES SHALL APPLY.

NOTE # M6
 ARCHITECT OR ENGINEER TO SIZE AND LOCATE, CONTRACTOR TO PROVIDE ALL OPENINGS FOR DUCTS, PLUMBING LINES, ELECTRICAL LINES, AND REFRIGERATION LINES, AS REQUIRED BY EQUIPMENT.

NOTE # M7
 SUPPLY FANS TO BE LOCATED A MINIMUM OF 10' FROM EXHAUST FANS.

NOTE # M8
 SHOP DRAWING WILL BE PROVIDED BY MANUFACTURER FOR HOOD, EXHAUST FANS, & SUPPLY FANS, UNCE ORDER IS PLACE WITH.

NOTE # M9
 GENERAL CONTRACTOR TO PROVIDE 2" PLYWOOD WALL BACKING FROM 30" TO 78" AFF FOR ALL WALL MOUNTED EQUIPMENT.

NOTE # M10
 CEILING HEIGHTS TO BE VERIFIED FOR SUFFICIENT CLARENCE FOR EQUIPMENT.

NOTE # M11
 REFRIGERATION CONTRACTOR TO HANG EVAPORATORS FOR WALK-IN, RUN & CHARGE LINES BETWEEN EVAP. & CONDENSING UNIT.

Equipment MECHANICAL Service Requirements

All Dimensions to be verified on the job site. Actual locations for floor drains, and any ventilating equipment to be determined by Engineer. Mechanical, Plumbing & Electrical to be checked and verified by Customers MEP Engineer. Remote Condensing Units to be located by Architect. Exhaust & Supply Fans to be located by Architect.

