
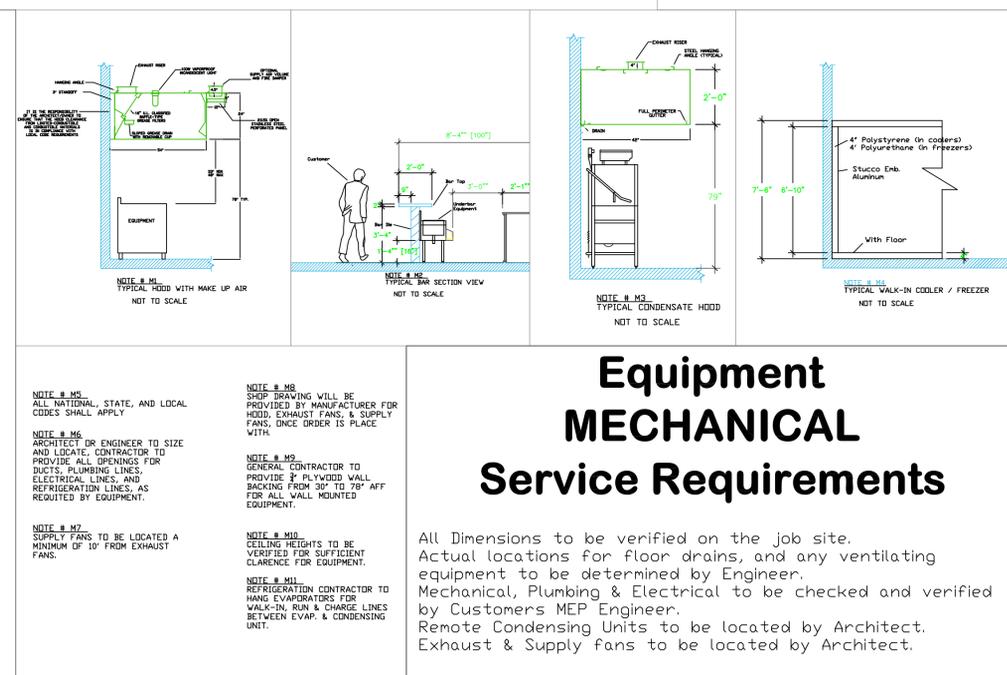


Mechanical Schedule								
ITEM NO.	QTY	DISCRIPTION	EXHAUST (L X W)	EXHAUST (CFM)	SUPPLY (L X W)	SUPPLY (CFM)	Ventilation Remarks	Unit
L3	4	Cabinet Hard Mount Washer Extractor					Reinforced Concrete Pad	ea
L4	1	Stacke Washer Dryer	4"	220			Venting Location by Engineer	ea
L8	4	Electric Dryer	8"	800			Venting Location by Engineer	ea
S1	5	Stacke Washer Dryer	4"	220			Venting Location by Engineer	ea

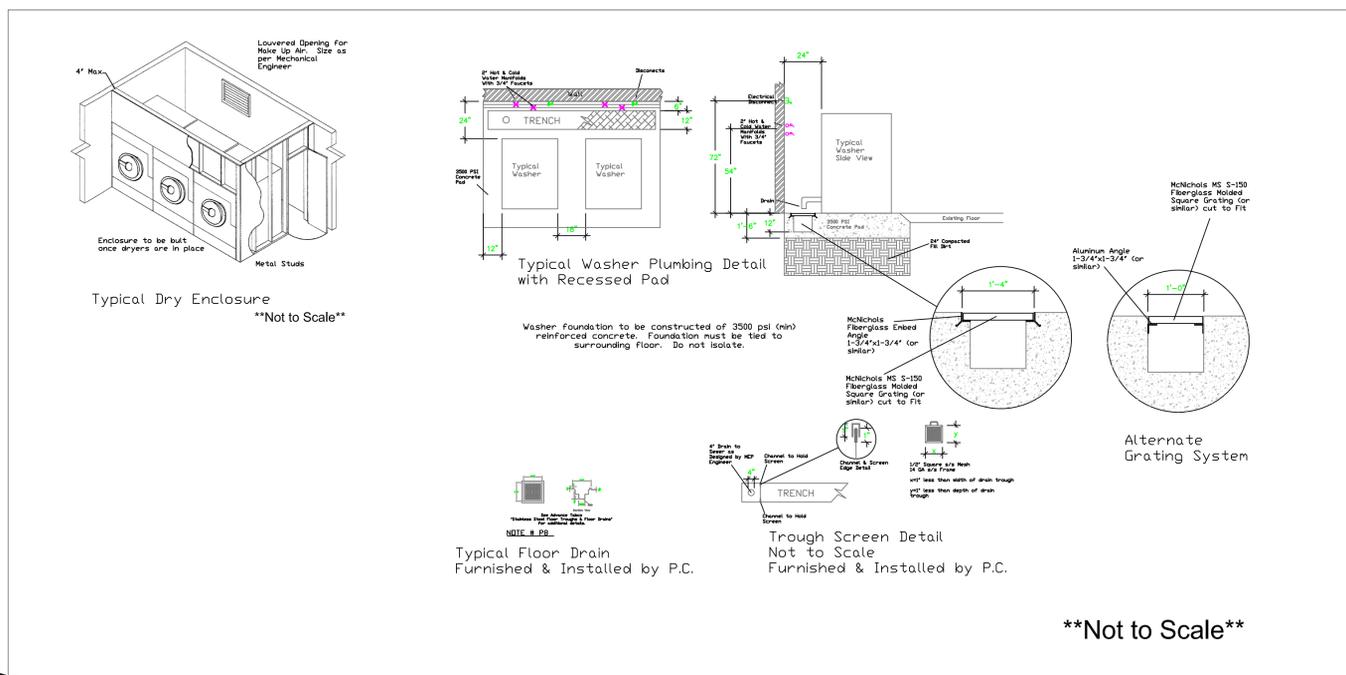

Molo Resorts Laundry
Providenciales, T&C

MOLO HOTEL GROUP

uni-source SUPPLY
 INTERNATIONAL INC.

2055 W 73rd Street, Miami, FL 33016
 Ph:(305)826-8696 Fax:(305)826-9131

2	Update after ownership comments.	5-1-25
3	Update after ownership comments.	6-27-25
4	Adeed Modifications	6-30-25
5	Adeed MEP	01-12-26
No.	Revision/Issue	Date

Date
Jan 12, 2026

Drawn By
Dayne Gauntlett

Scale
3/8" = 1'0"

Sheet
L-2.2