 


ELECTRICAL PACKAGE -- JOB#6328705							
NO	TAG	PACKAGE #	LOCATION	SWITCHES	OPTION	FANS CONTROLLED	
			LOCATION	QUANTITY			
1	1	DCV-1111	WALL MOUNT IN SS BOX	SS WALL MOUNT BOX	SMART CONTROLS DCV	FAN TAG TYPE # HP VOLT FLA #12 SUPPLY 3 1500 208 6.6 PCU-1 EXHAUST 3 17500 208 20.5	








CASlink Monitor and Control

— Hood control panel to support communications to cloud-based Building Management System.
— Hood Control Panel to allow cloud-based Building Management System to monitor real time parameters outlined as MONITOR on the points list.
— Hood Control Panel to allow cloud-based Building Management System to control parameters outlined as CONTROL on the points list.
— Hood Control Panel to allow cloud-based Building Management System to implement SYSTEM ECONOMIZER control strategies for fully integrated Building Management.

MONITORING AND CONTROL POINTS LIST

DCV Package	Function	DC Function	Function
Room Temperature	MONITOR	Room Temperature(s)	MONITOR
Duct Temperature(s)	MONITOR	Duct Temperature(s)	MONITOR
Make Discharge Temperature	MONITOR	Make Discharge Temperature	MONITOR
Blowers RTU Discharge Temperature	MONITOR	Blowers RTU Discharge Temperature	MONITOR
Fan Speed	MONITOR	Compressor Faults	MONITOR
Fan Amperage	MONITOR	Fan Faults	MONITOR
Fan Power	MONITOR	PCU Faults	MONITOR
RTU Faults	MONITOR	PCU Filter Cap Percentage	MONITOR
Compressor Faults	MONITOR	Fan Condition	MONITOR
Fan Condition	MONITOR	COSE Fire System	MONITOR
Fan Status	MONITOR	Building Pressure	MONITOR
PCU Faults	MONITOR	Fane Pull-in(s)	MONITOR & CONTROL
PCU Filter Cap Percentage	MONITOR	Light Pull-in(s)	MONITOR & CONTROL
Fan Condition	MONITOR	COSE Fire System	MONITOR
COSE Fire System	MONITOR	Push Button	MONITOR & CONTROL
Building Pressure	MONITOR		
Prep Time Button	MONITOR & CONTROL		
Fane Pull-in	MONITOR & CONTROL		
Light Pull-in	MONITOR & CONTROL		
Push Button	MONITOR & CONTROL		

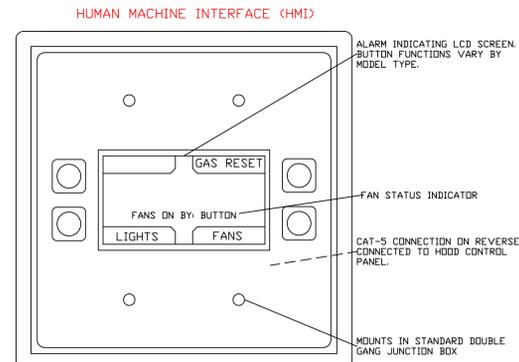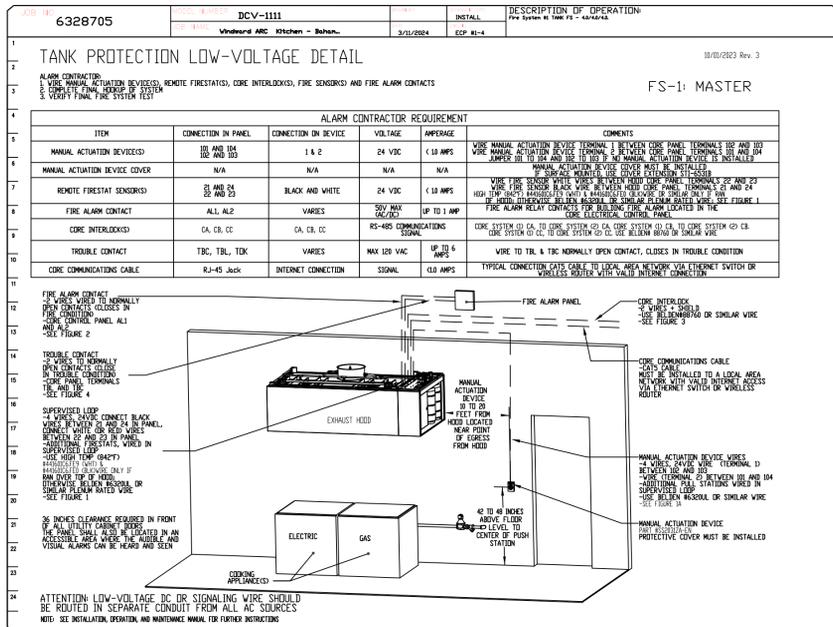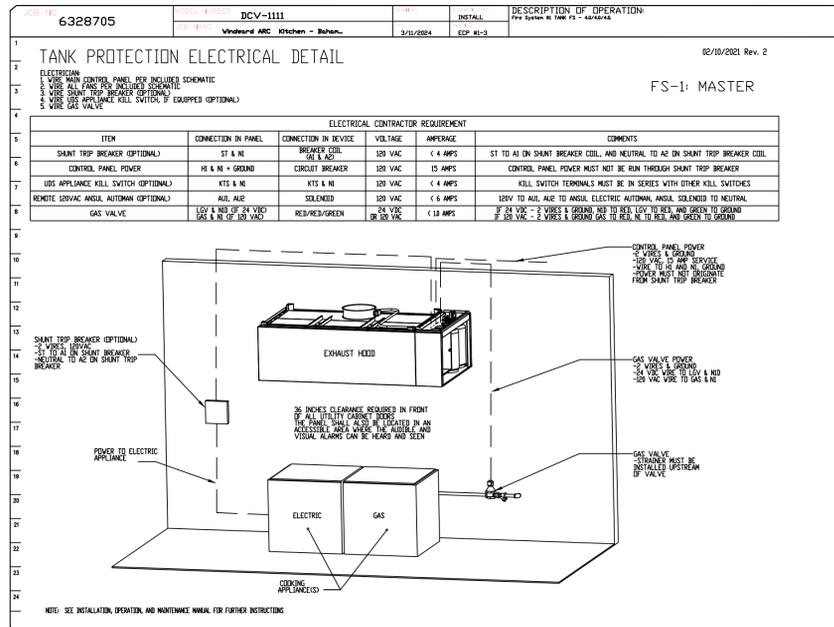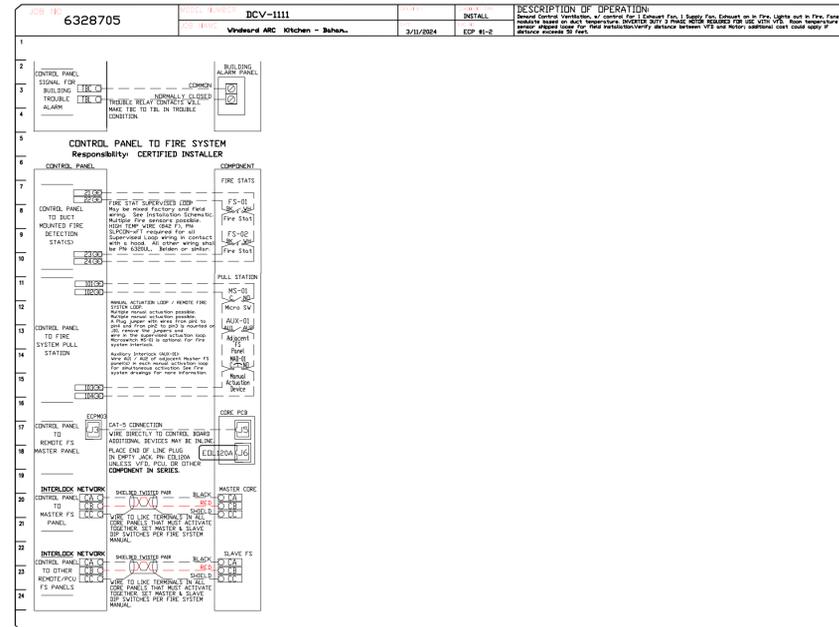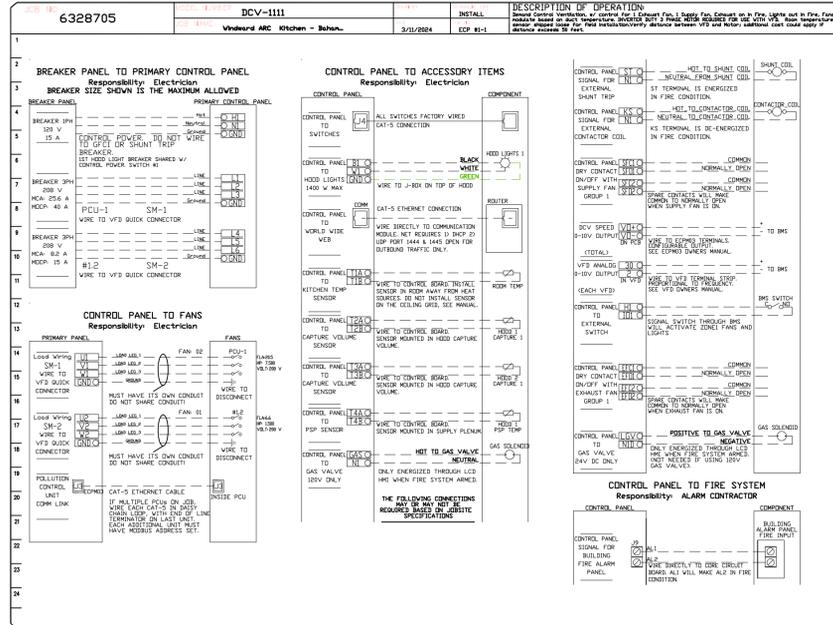

REVISIONS	
NO.	DESCRIPTION

DATE: 3/11/2024
DWG.#: 6328705
DRAWN BY: jseward
SCALE: 3/4" = 1'-0"
MASTER DRAWING

SHEET NO. 8

Windward ARC
Kitchen & Bar
Nassau, Bahamas

uni-source SUPPLY
INTERNATIONAL INC.
2055 W 73rd Street, Miami, FL 33016
Ph: (305)826-8696 Fax: (305)826-9131

No.	Revision/Issue	Date
5	Added MEP & Hood Shops	3-12-24
6	Moved Bev Table, adjusted hot line. Added Chef Desk.	4-4-25
7	Changed #9 Refrigerators, moved sink #117	4-20-25
8	Added modifications to #61-#21-#31	01-14-26

Date
Jan 14, 2026
Drawn By
Dayne Gauntlett
Scale
NTS

Sheet
FS-6.8

Windward ARC Kitchen - Bahamas
Hialeah, FL,