
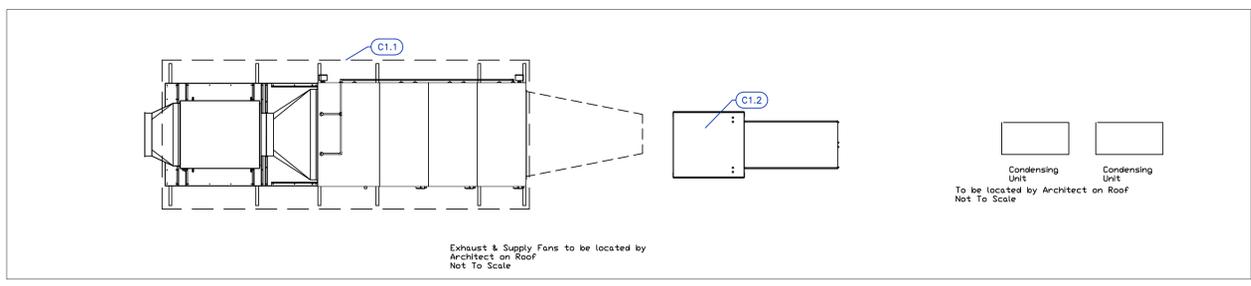
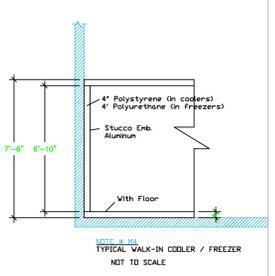
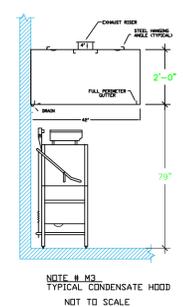
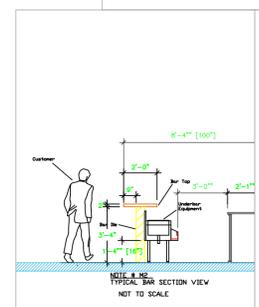


Mechanical Schedule								
ITEM NO.	QTY	DESCRIPTION	EXHAUST (L X W)	EXHAUST (CFM)	Makeup Vent Width	SUPPLY (CFM)	Ventilation Remarks	Unit
1	1	Mash Hood	10x18, 10x19	1925, 2062	(4) 12"x28"	1540, 1650		ea
1.1	1	Exhaust Fan - PCU		3987				ea
1.2	1	Supply Fan				3190		ea
21	1	Dishable, Solled "L" Shaped					Critical Hold To Dimensions	ea
24	1	Three (3) Compartment Sink					Critical Hold To Dimensions	ea
24.2	1	Overshelf					Wall Backing, See Note M9	ea
43.2	1	Shelving, Wall Mounted					Wall Backing, See Note M9	ea
61	1	Walk-in Combo					Critical Hold To Dimensions	ea
72.1	2	Water Filtration System, Parts & Accessories					Wall Backing, See Note M9	ea
75.1	1	Water Filtration System, Parts & Accessories					Wall Backing, See Note M9	ea
76.1	1	Water Filtration System, Parts & Accessories					Wall Backing, See Note M9	ea
81	1	Table with Sink - Sushi					Critical Hold To Dimensions	ea
83	1	Shelving, Wall Mounted					Wall Backing, See Note M9	ea
88	1	Dishable Sorting Table					Critical Hold To Dimensions	ea
112	1	Work Table, Stainless Steel Top					Critical Hold To Dimensions	ea

LEGEND - MECHANICAL

- EXHAUST DUCT COLLAR
- SUPPLY DUCT COLLAR
- INWALL BACKING FOR WALL SHELVES
- RECESSED FLOOR
- RAISED EQUIPMENT PAD

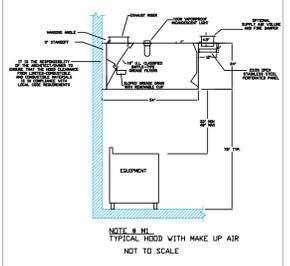

NOTE # M5
ALL NATIONAL, STATE, AND LOCAL CODES SHALL APPLY.

NOTE # M6
ARCHITECT OR ENGINEER TO SIZE AND LOCATE, CONTRACTOR TO PROVIDE ALL OPENINGS FOR DUCTS, PLUMBING LINES, ELECTRICAL LINES, AND REFRIGERATION LINES, AS REQUIRED BY EQUIPMENT.

NOTE # M7
SUPPLY FANS TO BE LOCATED A MINIMUM OF 10' FROM EXHAUST FANS.

NOTE # M8
SHOP DRAWING WILL BE PROVIDED BY MANUFACTURER FOR HOOD, EXHAUST FANS, & SUPPLY FANS, UNCE ORDER IS PLACE WITH.

NOTE # M9
GENERAL CONTRACTOR TO PROVIDE 2" FLYWOOD WALL BACKING FROM 30" TO 78" AFF FOR ALL WALL MOUNTED EQUIPMENT.

NOTE # M10
CEILING HEIGHTS TO BE VERIFIED FOR SUFFICIENT CLEARANCE FOR EQUIPMENT.

NOTE # M11
REFRIGERATION CONTRACTOR TO HANG EVAPORATORS FOR WALK-IN, RUN & CHARGE LINES BETWEEN EVAP. & CONDENSING UNIT.

Equipment MECHANICAL Service Requirements

All Dimensions to be verified on the job site. Actual locations for floor drains, and any ventilating equipment to be determined by Engineer. Mechanical, Plumbing & Electrical to be checked and verified by Customers MEP Engineer. Remote Condensing Units to be located by Architect. Exhaust & Supply Fans to be located by Architect.

Windward ARC
Kitchen & Bar
Nassau, Bahamas



INTERNATIONAL INC.
2055 W 73rd Street, Miami, FL 33016
Ph:(305)826-8696 Fax:(305)826-9131

No.	Revision/Issue	Date
5	Added MEP & Hood Shops	3-12-24
6	Moved Bev Table, adjusted hot line. Added Chef Desk.	4-4-25
7	Changed #9 Refrigerators, moved sink #117	4-20-25
8	Added modifications to #61-#21-#31	01-14-26

Date
Jan 14, 2026
Drawn By
Dayne Gauntlett
Scale
1/4" = 1'0"

Sheet
FS-2.1