
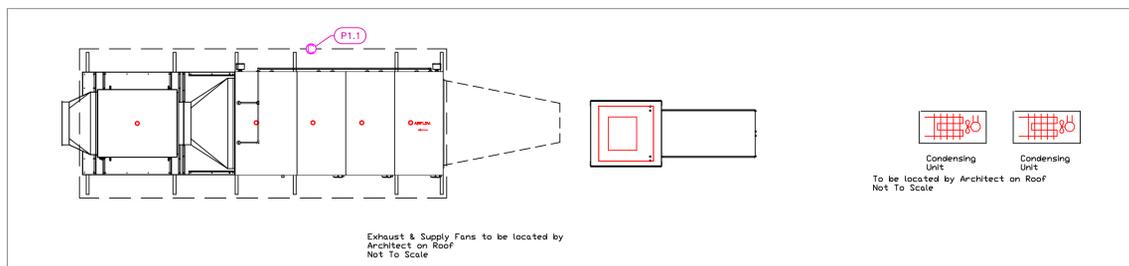
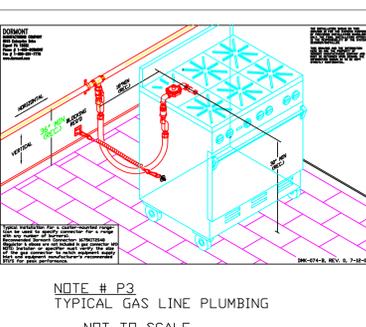
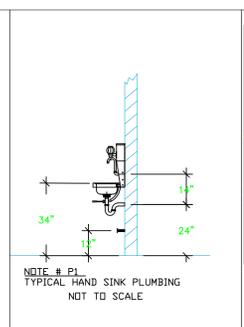


PLUMBING SCHEDULE											
ITEM NO.	DESCRIPTION	COLD WATER SIZE	HOT WATER SIZE	H&C Rough-In	DIRECT WASTE SIZE	DIRECT WASTE AFF.	INDIRECT WASTE SIZE	GAS SIZE(IN)	GAS MBTU	QTY	PLUMBING REMARKS
1.1	Exhaust Fan - PCU									1	See Shops for Additional Details
2	Gas Floor Fryer	1-1/2"	12"					3/4"	110.0	2	See Note P3
4	HD Range, 30" Plancha							3/4"	17.5	1	See Note P3
5	HD Range, 36", 6 Open Burners							1"	245.0	1	See Note P3
6	Salamander Broiler, Gas							3/4"	35.0	1	See Note P3
6	Charbroiler, Gas, Floor Model							3/4"	120.0	1	See Note P3
7	Pasta Cooker, Gas	3/4"	12"					3/4"	32.4	1	See Note P3
8	Chef's Table						1-1/2"			1	Waste to Floor Sink
8.2	Deck Mount Faucet	1/2"	1/2"	12"						1	
16.2	Deck Mount Faucet	1/2"	1/2"	12"						1	
21	Dishwasher, Solved "L" Shaped						1-1/2"			1	Waste to Floor Sink
21.2	Pre-Rinse Faucet Assembly	1/2"	1/2"	12"						1	
22	Dishwasher, Door Type, Ventless	3/4"	12"				1-1/2"			1	Waste to Floor Sink
24	Three (3) Compartment Sink						(3) 1-1/2"			1	Waste to Floor Sink
24.1	Wall / Splash Mount Faucet	1/2"	1/2"	12"						1	
25	Soak Sink	2"								1	
31	Beverage Counter	1/2"	1/2"	12"			1-1/2"			1	Waste to Floor Sink
43	Work Table	1/2"	1/2"	12"			1-1/2"			1	Waste to Floor Sink
43.1	Deck Mount Faucet	1/2"	1/2"	12"						1	
51	Work Table, with Prep Sink(s)	1/2"	1/2"	12"			1-1/2"			2	Waste to Floor Sink
51.1	Deck Mount Faucet	1/2"	1/2"	12"						2	
61.1	Evaporator for Cooler						1"			1	condensate drain to FFD
61.2	Evaporator for Freezer						1"			1	condensate drain to FFD
61.3	Remote Condenser Unit for Cooler									1	interconnect refig with Evap
61.4	Remote Condenser Unit for Freezer									1	interconnect refig with Evap
72	Ice Maker, Cube-Style	1/2"		n/a			3/4"			2	Water from Filter
72.1	Ice Bin for Ice Machines						3/4"			1	Waste to Floor Sink
72.1	Water Filtration System, Parts & Accessories	3/4"		36"						2	
73	Floor Trough					4"	Floor			2	Installed by Plumber
75	Ice Flaker	1/2"		n/a			3/4"			1	Water from Filter
75.1	Ice Bin for Ice Machines						3/4"			1	Waste to Floor Sink
75.1	Water Filtration System, Parts & Accessories	3/4"		36"						1	
76	Ice Maker with Bin, Cube-Style	1/2"		n/a			3/4"			1	Water from Filter
76.1	Water Filtration System, Parts & Accessories	3/4"		36"						1	
81	Table with Sink - Sushi						1-1/2"			1	Waste to Floor Sink
81.1	Deck Mount Faucet	1/2"	1/2"	12"						1	
88	Dishable Sorting Table						1-1/2"			1	Waste to Floor Sink
88.1	Pre-Rinse Faucet Assembly, with Add On Faucet	1/2"	1/2"	12"	1-1/2"	24"				1	
90	Hand Sink	1/2"	1/2"	12"						1	See Note P1
110	Sushi Case	1/2"	1/2"	12"			1/2"			1	Waste to Floor Sink
115	Sushi Case	1/2"	1/2"	12"			1/2"			1	Waste to Floor Sink
117	Work Table, Stainless Steel Top						1-1/2"			1	Waste to Floor Sink
117.1	Deck Mount Faucet	1/2"	1/2"	12"						3	Waste to Floor Sink
134	Ice Bin with Bottle Wells						1/2"			3	Dippenwell
135	Underbar Sink Units	1/2"	1/2"	12"			1-1/2"			3	Rinser, Dippenwell
137	Blender Station	1/2"	1/2"	12"			1-1/2"			3	4" faucet, Sink
138	Dishwasher, Undercounter	3/4"	12"				1"			1	Water size note: 3/4" male GHT (connect to true 1/2" ID Line)
139	Waste Cabinet	1/2"	1/2"	12"	1"		1-3/8" OD			1	Waste to Floor Sink
140	Drainboard						1"			1	

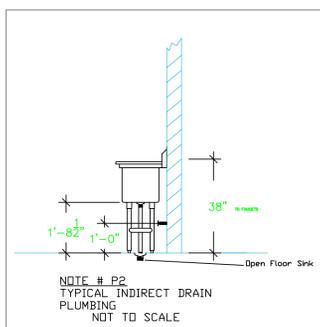

LEGEND -- PLUMBING CONNECTIONS

- HW-HOT WATER, OR CW-COLD WATER
- GAS
- WASTE, DIRECT-CONNECTED
- WASTE, INDIRECT to Floor Sink, or Floor Dr
- FUNNEL FLOOR DRAIN Josam 30000-E3
- FLOOR DRAIN Josam 30000-A3
- FLOOR SINK Proflo PF42856 or similar
- FILTERED WATER, at machine.

NOTE # P4
ALL NATIONAL, STATE, AND LOCAL CODES SHALL APPLY

NOTE # P5
ALL PLUMBING CONNECTIONS TO BE EXTENDED AND INTERCONNECTED TO EQUIPMENT AND ALL HARDWARE REQUIRED TO BE PROVIDED BY PLUMBING CONTRACTOR

NOTE # P6
PLUMBING CONTRACTOR TO VERIFY THAT ALL EQUIPMENT IS INSTALLED WITH THE APPROPRIATE GAS PRESSURE AND REGULATORS

NOTE # P7
ALL WASTE LINES AND CONDENSATE LINES TO BE EXTEND FROM EQUIPMENT TO FLOOR DRAINS BY PLUMBING CONTRACTOR.

Equipment PLUMBING Service Requirements

All Dimensions to be verified on the job site. Actual locations for floor drains, and any ventilating equipment to be determined by Engineer. Mechanical, Plumbing & Electrical to be checked and verified by Customers MEP Engineer. Remote Condensing Units to be located by Architect. Exhaust & Supply fans to be located by Architect.

**Windward ARC
Kitchen & Bar
Nassau, Bahamas**



2055 W 73rd Street, Miami, FL 33016
Ph:(305)826-8696 Fax:(305)826-9131

No.	Revision/Issue	Date
5	Added MEP & Hood Shops	3-12-24
6	Moved Bev Table, adjusted hot line. Added Chef Desk.	4-4-25
7	Changed #9 Refrigerators, moved sink #117	4-20-25
8	Added modifications to #61-#21-#31	01-14-26

Date
Jan 14, 2026
Drawn By
Dayne Gauntlett
Scale
1/4" = 1'0"

Sheet
FS-4.1